

1	2	3	4	5	6	7	8																																																																																																																																																												
<table><tr><th>DRAWING NO.</th><th>REVISION</th><th>DESCRIPTION</th></tr><tr><td>1294P-E01-01</td><td>0</td><td>MASTER DRAWING LIST</td></tr><tr><td>1294P-E01-02</td><td>0</td><td>SYMBOLS</td></tr><tr><td>1294P-E01-03</td><td>0</td><td>ELECTRICAL ONE LINE DIAGRAM</td></tr><tr><td>1294P-E01-04</td><td>0</td><td>DATA COMMUNICATION DIAGRAM</td></tr><tr><td>1294P-E02-01</td><td>0</td><td>PLC PANEL CABINET LAYOUT</td></tr><tr><td>1294P-E02-02</td><td>0</td><td>PLC PANEL LAYOUT</td></tr><tr><td>1294P-E02-03</td><td>0</td><td>PLC PANEL SCHEMATIC - SHEET 1</td></tr><tr><td>1294P-E02-04</td><td>0</td><td>PLC PANEL SCHEMATIC - SHEET 2</td></tr><tr><td>1294P-E02-05</td><td>0</td><td>PLC PANEL SCHEMATIC - SHEET 3</td></tr><tr><td>1294P-E02-06</td><td>0</td><td>PLC PANEL SCHEMATIC - SHEET 4</td></tr><tr><td>1294P-E02-07</td><td>0</td><td>PLC PANEL SCHEMATIC - SHEET 5</td></tr><tr><td>1294P-E02-08</td><td>0</td><td>PLC PANEL SCHEMATIC - SHEET 6</td></tr><tr><td>1294P-E02-09</td><td>0</td><td>PLC PANEL SCHEMATIC - SHEET 7</td></tr><tr><td>1294P-E02-10</td><td>0</td><td>PLC PANEL SCHEMATIC - SHEET 8</td></tr><tr><td>1294P-E02-11</td><td>0</td><td>PLC PANEL SCHEMATIC - SHEET 9</td></tr><tr><td>1294P-E02-12</td><td>0</td><td>PLC PANEL SCHEMATIC - SHEET 10</td></tr><tr><td>1294P-E02-13</td><td>0</td><td>PLC PANEL SCHEMATIC - SHEET 11</td></tr><tr><td>1294P-E02-14</td><td>0</td><td>PLC PANEL SCHEMATIC - SHEET 12</td></tr><tr><td>1294P-E02-15</td><td>0</td><td>PLC PANEL FUTURE</td></tr><tr><td>1294P-E02-16</td><td>0</td><td>PLC PANEL FUTURE</td></tr><tr><td>1294P-E02-17</td><td>0</td><td>PLC PANEL BILL OF MATERIAL</td></tr><tr><td>1294P-E02-18</td><td>0</td><td>PLC PANEL INTERCONNECTION W/D - SHEET 1</td></tr><tr><td>1294P-E02-19</td><td>0</td><td>PLC PANEL INTERCONNECTION W/D - SHEET 2</td></tr><tr><td>1294P-E02-20</td><td>0</td><td>PLC PANEL INTERCONNECTION W/D - SHEET 3</td></tr><tr><td>1294P-E02-21</td><td>0</td><td>PLC PANEL CABLE LISTING</td></tr><tr><td>1294P-E03-01</td><td>0</td><td>HEATER PANEL CABINET LAYOUT</td></tr><tr><td>1294P-E03-02</td><td>0</td><td>HEATER PANEL PANEL LAYOUT</td></tr><tr><td>1294P-E03-03</td><td>0</td><td>HEATER PANEL SCHEMATIC - SHEET 1</td></tr><tr><td>1294P-E03-04</td><td>0</td><td>HEATER PANEL SCHEMATIC - SHEET 2</td></tr><tr><td>1294P-E03-05</td><td>0</td><td>HEATER PANEL FUTURE</td></tr><tr><td>1294P-E03-06</td><td>0</td><td>HEATER PANEL BILL OF MATERIAL</td></tr><tr><td>1294P-E03-07</td><td>0</td><td>HEATER PANEL INTERCONNECTION W/D</td></tr><tr><td>1294P-E03-08</td><td>0</td><td>HEATER PANEL CABLE LISTING</td></tr></table>			DRAWING NO.	REVISION	DESCRIPTION	1294P-E01-01	0	MASTER DRAWING LIST	1294P-E01-02	0	SYMBOLS	1294P-E01-03	0	ELECTRICAL ONE LINE DIAGRAM	1294P-E01-04	0	DATA COMMUNICATION DIAGRAM	1294P-E02-01	0	PLC PANEL CABINET LAYOUT	1294P-E02-02	0	PLC PANEL LAYOUT	1294P-E02-03	0	PLC PANEL SCHEMATIC - SHEET 1	1294P-E02-04	0	PLC PANEL SCHEMATIC - SHEET 2	1294P-E02-05	0	PLC PANEL SCHEMATIC - SHEET 3	1294P-E02-06	0	PLC PANEL SCHEMATIC - SHEET 4	1294P-E02-07	0	PLC PANEL SCHEMATIC - SHEET 5	1294P-E02-08	0	PLC PANEL SCHEMATIC - SHEET 6	1294P-E02-09	0	PLC PANEL SCHEMATIC - SHEET 7	1294P-E02-10	0	PLC PANEL SCHEMATIC - SHEET 8	1294P-E02-11	0	PLC PANEL SCHEMATIC - SHEET 9	1294P-E02-12	0	PLC PANEL SCHEMATIC - SHEET 10	1294P-E02-13	0	PLC PANEL SCHEMATIC - SHEET 11	1294P-E02-14	0	PLC PANEL SCHEMATIC - SHEET 12	1294P-E02-15	0	PLC PANEL FUTURE	1294P-E02-16	0	PLC PANEL FUTURE	1294P-E02-17	0	PLC PANEL BILL OF MATERIAL	1294P-E02-18	0	PLC PANEL INTERCONNECTION W/D - SHEET 1	1294P-E02-19	0	PLC PANEL INTERCONNECTION W/D - SHEET 2	1294P-E02-20	0	PLC PANEL INTERCONNECTION W/D - SHEET 3	1294P-E02-21	0	PLC PANEL CABLE LISTING	1294P-E03-01	0	HEATER PANEL CABINET LAYOUT	1294P-E03-02	0	HEATER PANEL PANEL LAYOUT	1294P-E03-03	0	HEATER PANEL SCHEMATIC - SHEET 1	1294P-E03-04	0	HEATER PANEL SCHEMATIC - SHEET 2	1294P-E03-05	0	HEATER PANEL FUTURE	1294P-E03-06	0	HEATER PANEL BILL OF MATERIAL	1294P-E03-07	0	HEATER PANEL INTERCONNECTION W/D	1294P-E03-08	0	HEATER PANEL CABLE LISTING	<table><tr><th>DRAWING NO.</th><th>REVISION</th><th>DESCRIPTION</th></tr><tr><td>1294P-E04-01</td><td>0</td><td>BLOWER PANEL CABINET LAYOUT</td></tr><tr><td>1294P-E04-02</td><td>0</td><td>BLOWER PANEL PANEL LAYOUT</td></tr><tr><td>1294P-E04-03</td><td>0</td><td>BLOWER PANEL SCHEMATIC - SHEET 1</td></tr><tr><td>1294P-E04-04</td><td>0</td><td>BLOWER PANEL FUTURE</td></tr><tr><td>1294P-E04-05</td><td>0</td><td>BLOWER PANEL BILL OF MATERIAL</td></tr><tr><td>1294P-E04-06</td><td>0</td><td>BLOWER PANEL INTERCONNECTION W/D</td></tr><tr><td>1294P-E04-07</td><td>0</td><td>BLOWER PANEL CABLE LISTING</td></tr><tr><td></td><td></td><td></td></tr><tr><td></td><td></td><td></td></tr><tr><td></td><td></td><td></td></tr><tr><td></td><td></td><td></td></tr><tr><td></td><td></td><td></td></tr><tr><td></td><td></td><td></td></tr><tr><td></td><td></td><td></td></tr><tr><td></td><td></td><td></td></tr><tr><td></td><td></td><td></td></tr><tr><td></td><td></td><td></td></tr></table>					DRAWING NO.	REVISION	DESCRIPTION	1294P-E04-01	0	BLOWER PANEL CABINET LAYOUT	1294P-E04-02	0	BLOWER PANEL PANEL LAYOUT	1294P-E04-03	0	BLOWER PANEL SCHEMATIC - SHEET 1	1294P-E04-04	0	BLOWER PANEL FUTURE	1294P-E04-05	0	BLOWER PANEL BILL OF MATERIAL	1294P-E04-06	0	BLOWER PANEL INTERCONNECTION W/D	1294P-E04-07	0	BLOWER PANEL CABLE LISTING																														
DRAWING NO.	REVISION	DESCRIPTION																																																																																																																																																																	
1294P-E01-01	0	MASTER DRAWING LIST																																																																																																																																																																	
1294P-E01-02	0	SYMBOLS																																																																																																																																																																	
1294P-E01-03	0	ELECTRICAL ONE LINE DIAGRAM																																																																																																																																																																	
1294P-E01-04	0	DATA COMMUNICATION DIAGRAM																																																																																																																																																																	
1294P-E02-01	0	PLC PANEL CABINET LAYOUT																																																																																																																																																																	
1294P-E02-02	0	PLC PANEL LAYOUT																																																																																																																																																																	
1294P-E02-03	0	PLC PANEL SCHEMATIC - SHEET 1																																																																																																																																																																	
1294P-E02-04	0	PLC PANEL SCHEMATIC - SHEET 2																																																																																																																																																																	
1294P-E02-05	0	PLC PANEL SCHEMATIC - SHEET 3																																																																																																																																																																	
1294P-E02-06	0	PLC PANEL SCHEMATIC - SHEET 4																																																																																																																																																																	
1294P-E02-07	0	PLC PANEL SCHEMATIC - SHEET 5																																																																																																																																																																	
1294P-E02-08	0	PLC PANEL SCHEMATIC - SHEET 6																																																																																																																																																																	
1294P-E02-09	0	PLC PANEL SCHEMATIC - SHEET 7																																																																																																																																																																	
1294P-E02-10	0	PLC PANEL SCHEMATIC - SHEET 8																																																																																																																																																																	
1294P-E02-11	0	PLC PANEL SCHEMATIC - SHEET 9																																																																																																																																																																	
1294P-E02-12	0	PLC PANEL SCHEMATIC - SHEET 10																																																																																																																																																																	
1294P-E02-13	0	PLC PANEL SCHEMATIC - SHEET 11																																																																																																																																																																	
1294P-E02-14	0	PLC PANEL SCHEMATIC - SHEET 12																																																																																																																																																																	
1294P-E02-15	0	PLC PANEL FUTURE																																																																																																																																																																	
1294P-E02-16	0	PLC PANEL FUTURE																																																																																																																																																																	
1294P-E02-17	0	PLC PANEL BILL OF MATERIAL																																																																																																																																																																	
1294P-E02-18	0	PLC PANEL INTERCONNECTION W/D - SHEET 1																																																																																																																																																																	
1294P-E02-19	0	PLC PANEL INTERCONNECTION W/D - SHEET 2																																																																																																																																																																	
1294P-E02-20	0	PLC PANEL INTERCONNECTION W/D - SHEET 3																																																																																																																																																																	
1294P-E02-21	0	PLC PANEL CABLE LISTING																																																																																																																																																																	
1294P-E03-01	0	HEATER PANEL CABINET LAYOUT																																																																																																																																																																	
1294P-E03-02	0	HEATER PANEL PANEL LAYOUT																																																																																																																																																																	
1294P-E03-03	0	HEATER PANEL SCHEMATIC - SHEET 1																																																																																																																																																																	
1294P-E03-04	0	HEATER PANEL SCHEMATIC - SHEET 2																																																																																																																																																																	
1294P-E03-05	0	HEATER PANEL FUTURE																																																																																																																																																																	
1294P-E03-06	0	HEATER PANEL BILL OF MATERIAL																																																																																																																																																																	
1294P-E03-07	0	HEATER PANEL INTERCONNECTION W/D																																																																																																																																																																	
1294P-E03-08	0	HEATER PANEL CABLE LISTING																																																																																																																																																																	
DRAWING NO.	REVISION	DESCRIPTION																																																																																																																																																																	
1294P-E04-01	0	BLOWER PANEL CABINET LAYOUT																																																																																																																																																																	
1294P-E04-02	0	BLOWER PANEL PANEL LAYOUT																																																																																																																																																																	
1294P-E04-03	0	BLOWER PANEL SCHEMATIC - SHEET 1																																																																																																																																																																	
1294P-E04-04	0	BLOWER PANEL FUTURE																																																																																																																																																																	
1294P-E04-05	0	BLOWER PANEL BILL OF MATERIAL																																																																																																																																																																	
1294P-E04-06	0	BLOWER PANEL INTERCONNECTION W/D																																																																																																																																																																	
1294P-E04-07	0	BLOWER PANEL CABLE LISTING																																																																																																																																																																	
</																																																																																																																																																																			

DRAWING NO.	REVISION	DESCRIPTION
1294P-E01-01	0	MASTER DRAWING LIST
1294P-E01-02	0	SYMBOLS
1294P-E01-03	0	ELECTRICAL ONE LINE DIAGRAM
1294P-E01-04	0	DATA COMMUNICATION DIAGRAM
1294P-E02-01	0	PLC PANEL CABINET LAYOUT
1294P-E02-02	0	PLC PANEL LAYOUT
1294P-E02-03	0	PLC PANEL SCHEMATIC - SHEET 1
1294P-E02-04	0	PLC PANEL SCHEMATIC - SHEET 2
1294P-E02-05	0	PLC PANEL SCHEMATIC - SHEET 3
1294P-E02-06	0	PLC PANEL SCHEMATIC - SHEET 4
1294P-E02-07	0	PLC PANEL SCHEMATIC - SHEET 5
1294P-E02-08	0	PLC PANEL SCHEMATIC - SHEET 6
1294P-E02-09	0	PLC PANEL SCHEMATIC - SHEET 7
1294P-E02-10	0	PLC PANEL SCHEMATIC - SHEET 8
1294P-E02-11	0	PLC PANEL SCHEMATIC - SHEET 9
1294P-E02-12	0	PLC PANEL SCHEMATIC - SHEET 10
1294P-E02-13	0	PLC PANEL SCHEMATIC - SHEET 11
1294P-E02-14	0	PLC PANEL SCHEMATIC - SHEET 12
1294P-E02-15	0	PLC PANEL FUTURE
1294P-E02-16	0	PLC PANEL FUTURE
1294P-E02-17	0	PLC PANEL BILL OF MATERIAL
1294P-E02-18	0	PLC PANEL INTERCONNECTION W/D - SHEET 1
1294P-E02-19	0	PLC PANEL INTERCONNECTION W/D - SHEET 2
1294P-E02-20	0	PLC PANEL INTERCONNECTION W/D - SHEET 3
1294P-E02-21	0	PLC PANEL CABLE LISTING
1294P-E03-01	0	HEATER PANEL CABINET LAYOUT
1294P-E03-02	0	HEATER PANEL PANEL LAYOUT
1294P-E03-03	0	HEATER PANEL SCHEMATIC - SHEET 1
1294P-E03-04	0	HEATER PANEL SCHEMATIC - SHEET 2
1294P-E03-05	0	HEATER PANEL FUTURE
1294P-E03-06	0	HEATER PANEL BILL OF MATERIAL
1294P-E03-07	0	HEATER PANEL INTERCONNECTION W/D
1294P-E03-08	0	HEATER PANEL CABLE LISTING

DRAWING NO.	REVISION	DESCRIPTION
1294P-E04-01	0	BLOWER PANEL CABINET LAYOUT
1294P-E04-02	0	BLOWER PANEL PANEL LAYOUT
1294P-E04-03	0	BLOWER PANEL SCHEMATIC - SHEET 1
1294P-E04-04	0	BLOWER PANEL FUTURE
1294P-E04-05	0	BLOWER PANEL BILL OF MATERIAL
1294P-E04-06	0	BLOWER PANEL INTERCONNECTION W/D
1294P-E04-07	0	BLOWER PANEL CABLE LISTING

					 FUEL TECH, INC. 27601 BELLA VISTA PKWY, WARRENVILLE, IL 60555 UC DAVIS MEDICAL CENTER SACRAMENTO, CA	APPROVED BY: SMM	
						CHECKED BY: FJS	
						DRAWN BY: JMA	
						DATE: 8/5/22	
0	2/12/23	RELEASE FOR CONSTRUCTION	ARM	FJS		SCALE: NONE	SIZE: D
NO.	DATE	REVISIONS	DRAWN BY	CHECKED BY	ULTRA 20 CONTROL PANEL DRAWING LIST	DRAWING NO. 1294P-E01-01	

FRONT VIEW

RIGHT SIDE VIEW


THT-19-413-1-PR

NAMEPLATE SCHEDULE


LAM-7.50-1.50-902

FUEL TECH
PLC PANEL

LP-30MM-ESTOP

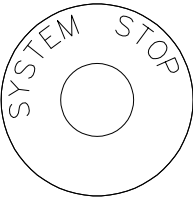

LP-30MM-902

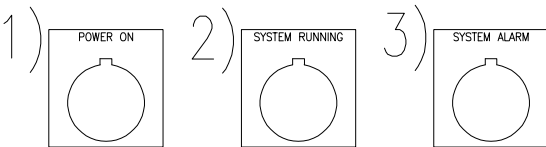

The Industrial Controls Company, Inc. BETTER THINKING. INSIDE THE BOX. N56 W24842 Corporate Circle Sussex, WI 53089			
120	VOLTS	N/A	FLA (LARGEST MOTOR)
60	CYCLES	9.1	FLA (TOTAL)
1	PHASE	1294P-E02	DRWG. NO.
TYPE 4 ENCLOSURE			

Fuse ID	MP#	Fuse# or Equivalent	Volts
FL503-642	BUSSMANN	AGC-1/2-R	250
FL429-433	BUSSMANN	MDL-2-R	250

USE COPPER CONDUCTORS ONLY			
PART ID	PART NUMBER	TORQUE (N/IN)	TEMP (C)
CB103	1489-M1C300	17.7	90
TB's	1492-J4	9.0	90
TB's	1492-JG4	9.0	90
TB's	1492-JTC3K	3.5-5.3	90
TB's	1492-JG3	4.5-7.1	90
GND BAR	PK12GTA	20 (14-100A)	90
GND BAR	PK12GTA	25 (80A)	90
GND BAR	PK12GTA	35 (6-40A)	90

USE COPPER CONDUCTORS ONLY			
PART ID	PART NUMBER	TORQUE (N/IN)	TEMP (C)
GND LUG	L70	35 (14-100A)	90
GND LUG	L70	40 (80A)	90
GND LUG	L70	45 (4-60A)	90

THT-19-435-1-HFC


WARNING RISK OF FIRE OR ELECTRICAL SHOCK	
THE OPENING OF THE BRANCH-CIRCUIT PROTECTIVE DEVICE MAY BE AN INDICATION THAT A FAULT CURRENT HAS BEEN INTERRUPTED. ALL CURRENT-CARRYING PARTS AND OTHER COMPONENTS PROTECTED BY THIS DEVICE SHOULD BE EXAMINED AND REPLACED IF DAMAGED. IF BURNOUT OF A CURRENT ELEMENT OF AN OVERLOAD RELAY OCCURS, THE COMPLETE OVERLOAD RELAY MUST BE REPLACED.	

99454

WARNING Arc Flash Hazard Appropriate PPE Required Do not operate controls or open covers without appropriate personal protection equipment. Failure to comply may result in injury or death! Refer to NFPA 70E for minimum PPE requirements.

NOTES:
1) CENTERLINE OF HMI (OIT340) IS 52" ABOVE GRADE.

						FUEL TECH Technologies to enable clean efficient energy FUEL TECH, INC. 27601 BELLA VISTA PKWY, WARRENVILLE, IL 60555 UC DAVIS MEDICAL CENTER SACRAMENTO, CA	APPROVED BY: SMM	
							CHECKED BY: FJS	
							DRAWN BY: JMA	
							DATE: 8/5/22	
0	2/12/23	RELEASE FOR CONSTRUCTION	ARM	FJS			SCALE: NONE	SIZE: D
NO.	DATE	REVISIONS	DRAWN BY	CHECKED BY	PLC PANEL CABINET LAYOUT		DRAWING NO. 1294P-E02-01	

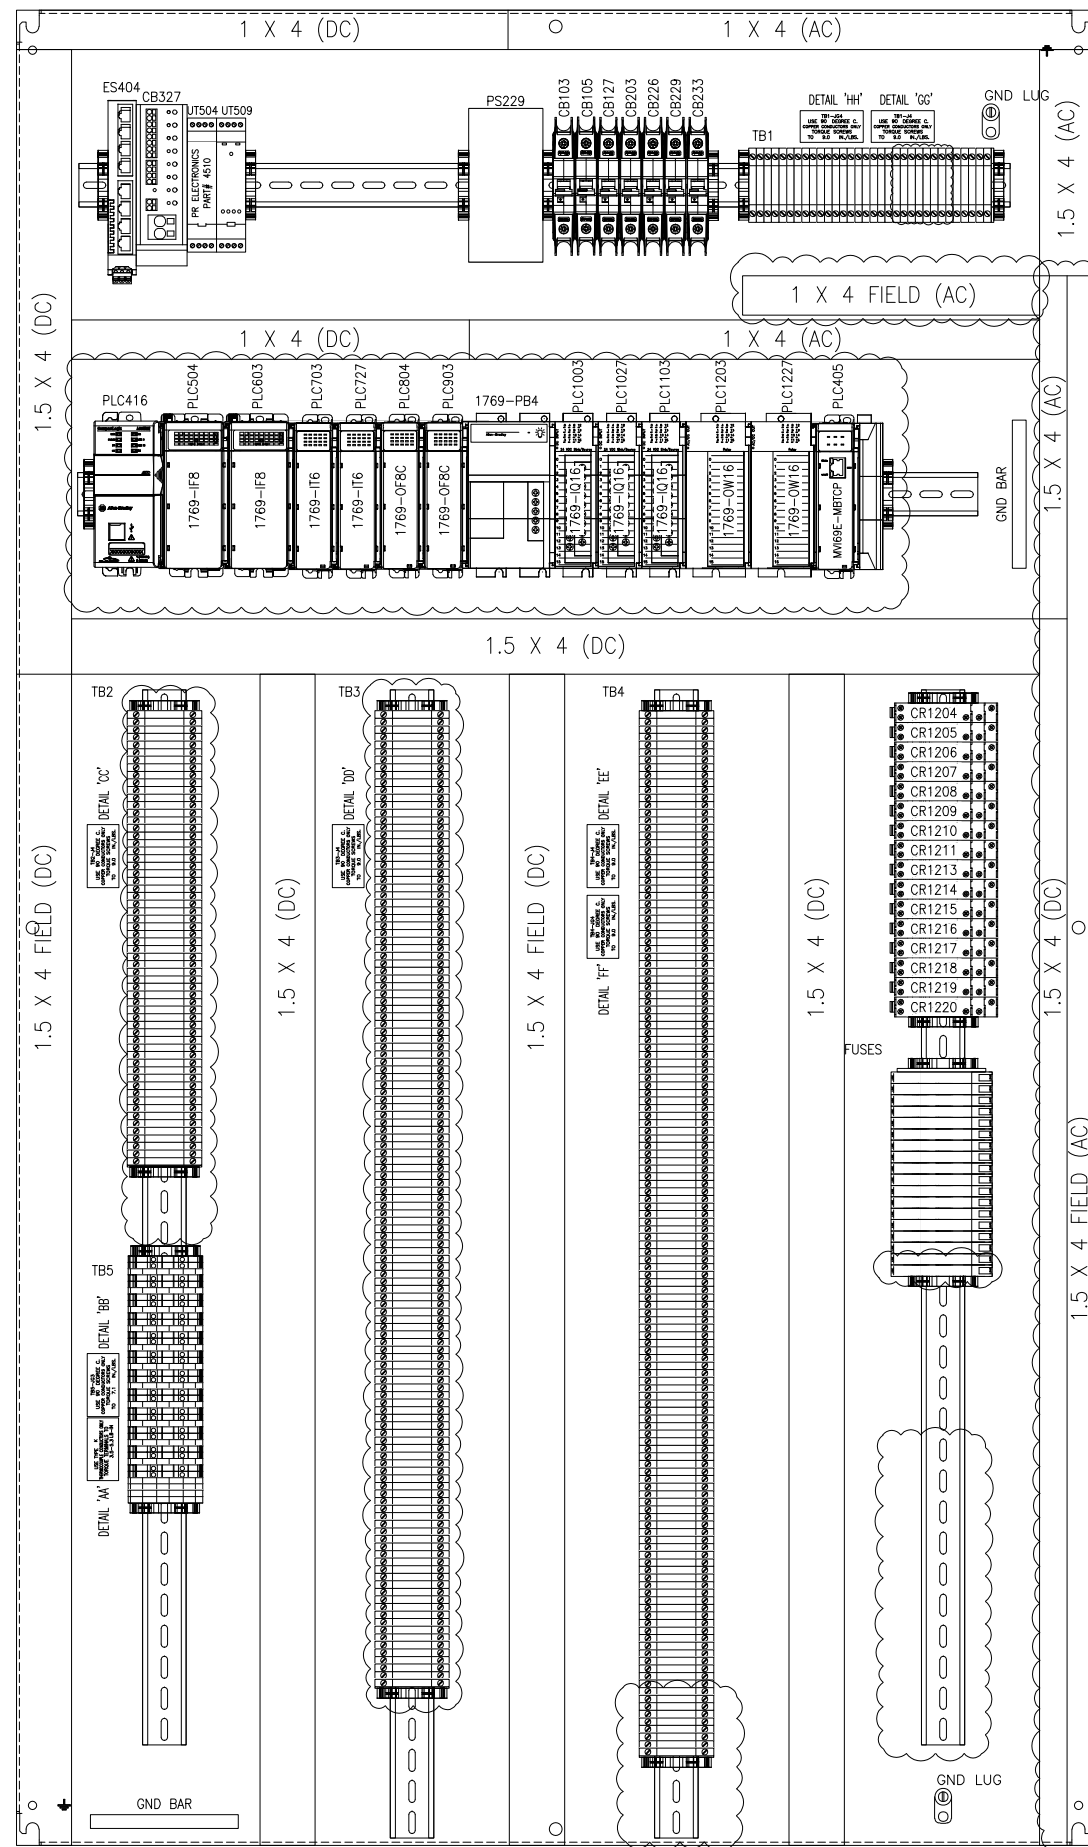

DETAIL 'AA'

USE TYPE K
THERMOCOUPLE CONDUCTORS ONLY
TORQUE TERMINALS TO
3.5-5.3 LB-IN

DETAIL 'BB'

TB5-JG3
USE 90 DEGREE C.
COPPER CONDUCTORS ONLY
TORQUE SCREWS
TO 7.1 IN./LBS.

DETAIL 'CC'

TB2-J4
USE 90 DEGREE C.
COPPER CONDUCTORS ONLY
TORQUE SCREWS
TO 9.0 IN./LBS.

DETAIL 'DD'

TB3-J4
USE 90 DEGREE C.
COPPER CONDUCTORS ONLY
TORQUE SCREWS
TO 9.0 IN./LBS.

DETAIL 'EE'

TB4-J4
 USE 90 DEGREE C.
 COPPER CONDUCTORS ONLY
 TORQUE SCREWS
 TO 9.0 IN./LBS.

DETAIL 'FF'

TB4-JG4
 USE 90 DEGREE C.
 COPPER CONDUCTORS ONLY
 TORQUE SCREWS
 TO 9.0 IN./LBS.

DETAIL 'GG'

TB1-J4
USE 90 DEGREE C.
COPPER CONDUCTORS ONLY
TORQUE SCREWS
TO 9.0 IN./LBS.

DETAIL 'HH'

TB1-JG4
USE 90 DEGREE C.
COPPER CONDUCTORS ONLY
TORQUE SCREWS
TO 9.0 IN./LBS.

FUSES
FU429
FU430
FU431
FU432
FU433
FU502
FU507
FU514
FU519
FU527
FU532
FU537
FU542
FU603
FU608
FU613
FU618
FU1109

120VAC TB1		
1	1041	
2	1041	
3	1041	
4	1041	
5	1041	
6	N	
7	N	
8	N	
9	N	
10	1051	
11	N	
12	GND	
13	1271	
14	N	
15	GND	
16	2031	
17	N	
18	GND	
19	2261	
20	4381	
21	4391	
22	4401	
23	4411	
24	4421	
25	4431	
26	4441	
27	4451	
28	SPARE	
29	SPARE	
30	SPARE	
31	SPARE	
32	SPARE	

* 19 to 1492-J4
* 3 to 1492-JG4

24VDC	
TB2	
1	2332
2	2332
3	2332
4	2332
5	2332
6	2333
7	2333
8	2333
9	2333
10	2333
11	2333
12	2333
13	2333
14	2333
15	2333
16	2333
17	2333
18	2333
19	2333
20	2333
21	2333
22	2333
23	2333
24	2333
25	2333
26	2333
27	2333
28	2333
29	2333
30	2333
31	2333
32	2333
33	2333
34	2333
35	2333
36	2333
37	2333
38	3271
39	3271
40	3401
41	4271
42	4281
43	4292
44	4302
45	4312
46	4322
47	4332
48	4341
49	4351
50	4361
51	4371
52	SPARE
53	SPARE
54	SPARE
55	SPARE
56	SPARE
57	SPARE
58	SPARE
59	SPARE
60	SPARE
	60 @ 1492-14

DIGITAL	
T83	
1	3311
2	3311
3	3311
4	3311
5	3311
6	3311
7	3311
8	3311
9	3311
10	3311
11	3311
12	3311
13	3311
14	3311
15	3311
16	3311
17	3311
18	3311
19	3311
20	3311
21	3311
22	3311
23	3311
24	3311
25	3311
26	3311
27	3311
28	3311
29	3311
30	3311
31	3311
32	3311
33	3311
34	3311
35	3311
36	3311
37	3311
38	3311
39	3311
40	3311
41	3311
42	3311
43	3311
44	3311
45	3361
46	07/00
47	07/01
48	07/02
49	07/03
50	07/04
51	07/05
52	07/06
53	07/07
54	07/08
55	07/09
56	07/10
57	07/11
58	07/12
59	07/13
60	07/14
61	07/15
62	08/00
63	08/01
64	08/02
65	08/03

DIGITAL T83 CONT.	
66	08/04
67	08/05
68	08/06
69	08/07
70	08/08
71	08/09
72	08/10
73	08/11
74	08/12
75	08/13
76	08/14
77	08/15
78	09/00
79	09/01
80	09/02
81	09/03
82	09/04
83	09/05
84	09/06
85	09/07
86	09/08
87	09/09
88	09/10
89	09/11
90	09/12
91	09/13
92	09/14
93	09/15
94	010/08
95	011/00
96	011/01
97	011/02
98	011/03
99	011/04
100	011/05
101	011/06
102	011/07
103	011/08
104	011/09
105	011/10
106	011/11
107	011/12
108	011/13
109	011/14
110	011/15
111	12131
112	SPARE
113	SPARE
114	SPARE
115	SPARE
116	SPARE
117	SPARE
118	SPARE
119	SPARE
120	SPARE
121	SPARE
122	SPARE
123	SPARE
124	SPARE
125	SPARE
126	SPARE
127	SPARE
128	SPARE
129	SPARE
130	SPARE

ANALOG TB4	
1	5051
2	5061
3	SHLD
4	5101
5	5111
6	SHLD
7	5141
8	1012/+
9	1012/-
10	2333
11	SHLD
12	5191
13	1013/+
14	1013/-
15	2333
16	SHLD
17	5271
18	1014/+
19	1014/-
20	2333
21	SHLD
22	5321
23	1015/+
24	1015/-
25	2333
26	SHLD
27	5371
28	1016/+
29	1016/-
30	2333
31	SHLD
32	5421
33	1017/+
34	1017/-
35	2333
36	SHLD
37	6031
38	1020/+
39	1020/-
40	2333
41	SHLD
42	6081
43	1021/+
44	1021/-
45	2333
46	SHLD
47	6131
48	1022/+
49	1022/-
50	2333
51	SHLD
52	6181
53	1023/+
54	1023/-
55	2333
56	SHLD
57	1024/+
58	1024/-
59	SHLD
60	1025/+
61	1025/-
62	SHLD
63	1026/+
64	1026/-
65	SHLD
66	1027/+
67	1027/-
68	SHLD
69	005/0+
70	005/0-
71	8081
72	SHLD
73	005/1+
74	005/1-
75	8121
76	SHLD
77	005/2+
78	005/2-
79	SHLD
80	005/3+
81	005/3-
82	SHLD
83	005/4+
84	005/4-
85	SHLD

ANALOG	
T84 CONT.	
86	005/5+
* 87	005/5-
88	SHLD
89	005/6+
90	005/6-
* 91	SHLD
92	005/7+
93	005/7-
94	SHLD
95	006/0+
* 96	006/0-
97	SHLD
98	006/1+
99	006/1-
* 100	SHLD
101	006/2+
102	006/2-
103	SHLD
104	006/3+
105	006/3-
* 106	SHLD
107	006/4+
108	006/4-
109	SHLD
110	006/5+
* 111	006/5-
112	SHLD
113	006/6+
114	006/6-
115	SHLD
* 116	006/7+
117	006/7-
118	SHLD
119	SPARE
120	SPARE
121	SHLD
* 122	SPARE
123	SPARE
124	SHLD
125	SPARE
* 126	SPARE
127	SHLD
128	SPARE
129	SPARE
130	SHLD
* 131	SPARE
132	SPARE
133	SHLD
134	SPARE
* 135	SPARE
136	SHLD
137	SPARE
138	SPARE


100 to 1492-J
**38 to 1492-J


	T/C	
	TB5	
1	I03/0+	**
	I03/0-	***
2	S_HLD	***
3	I03/+	**
	I03/-	***
* 4	S_HLD	**
5	I03/+	***
	I03/-	***
6	S_HLD	***
7	I03/+	**
	I03/-	***
8	S_HLD	***
9	I03/+	**
	I03/-	***
10	S_HLD	***
11	I03/+	***
	I03/-	***
12	S_HLD	***
13	I04/0+	**
	I04/0-	***
* 14	S_HLD	***
15	I04/+	**
	I04/-	***
* 16	S_HLD	***
17	I04/+	***
	I04/-	***
18	S_HLD	***
19	I04/+	**
	I04/-	***
20	S_HLD	***
21	I04/+	**
	I04/-	***
22	S_HLD	***
23	I04/+	**
	I04/-	***
24	S_HLD	**
25	S_HLD	***
26	S_HLD	***
27	S_HLD	***


**12 @ 1492-JTCK
**15@ 1492-JG3


						APPROVED BY: SMM	
						CHECKED BY: FJS	
						DRAWN BY: JMA	
						DATE: 8/5/22	
O	2/12/23	RELEASE FOR CONSTRUCTION	ARM	FJS	FUEL TECH, INC. 27601 BELLA VISTA PKWY, WARRENVILLE, IL 60555 UC DAVIS MEDICAL CENTER SACRAMENTO, CA		
					SCALE: NONE		SIZE: D
NO.	DATE	REVISIONS	DRAWN BY	CHECKED BY	PLC PANEL PANEL LAYOUT		DRAWING NO. 1294P-E02-02


DESIGNS REPRESENTED ON THIS DRAWING ARE THE PROPERTY OF FUEL TECH AND ARE CONFIDENTIAL. ALL RIGHTS ARE RESERVED. ANY USE OTHER THAN THAT DESCRIBED IN THE CUSTOMER CONTRACT REQUIRES WRITTEN PERMISSION.

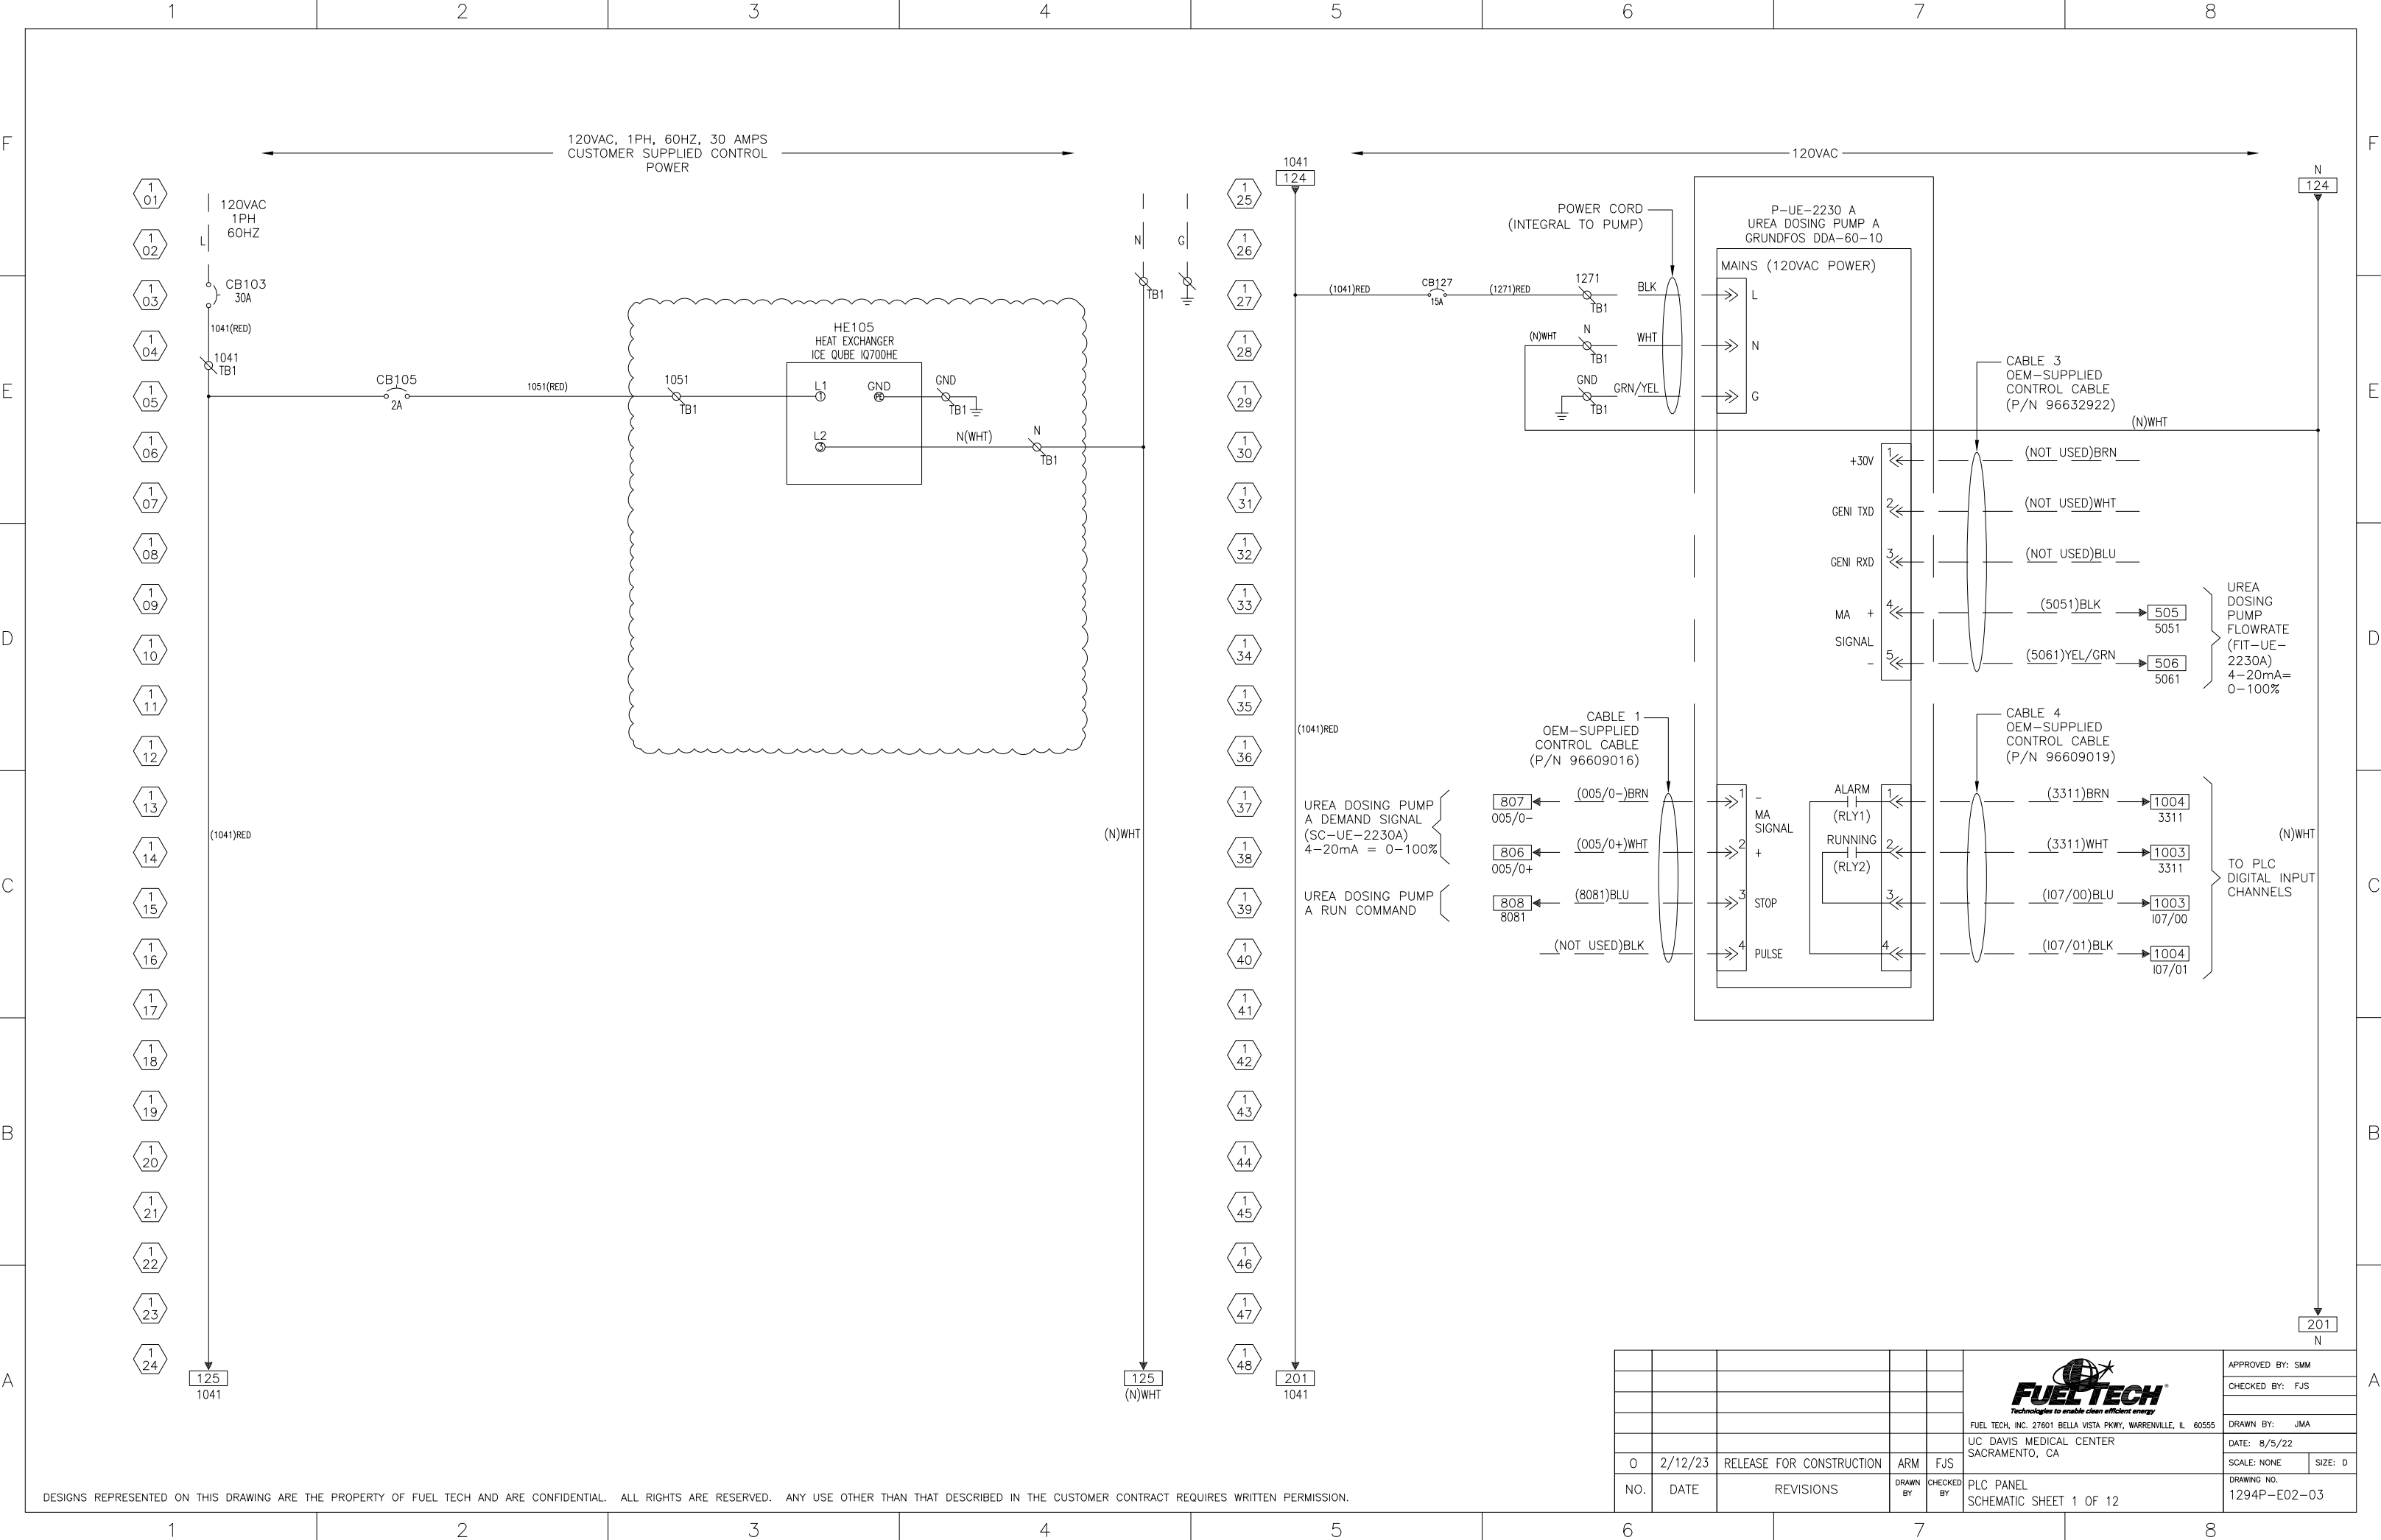


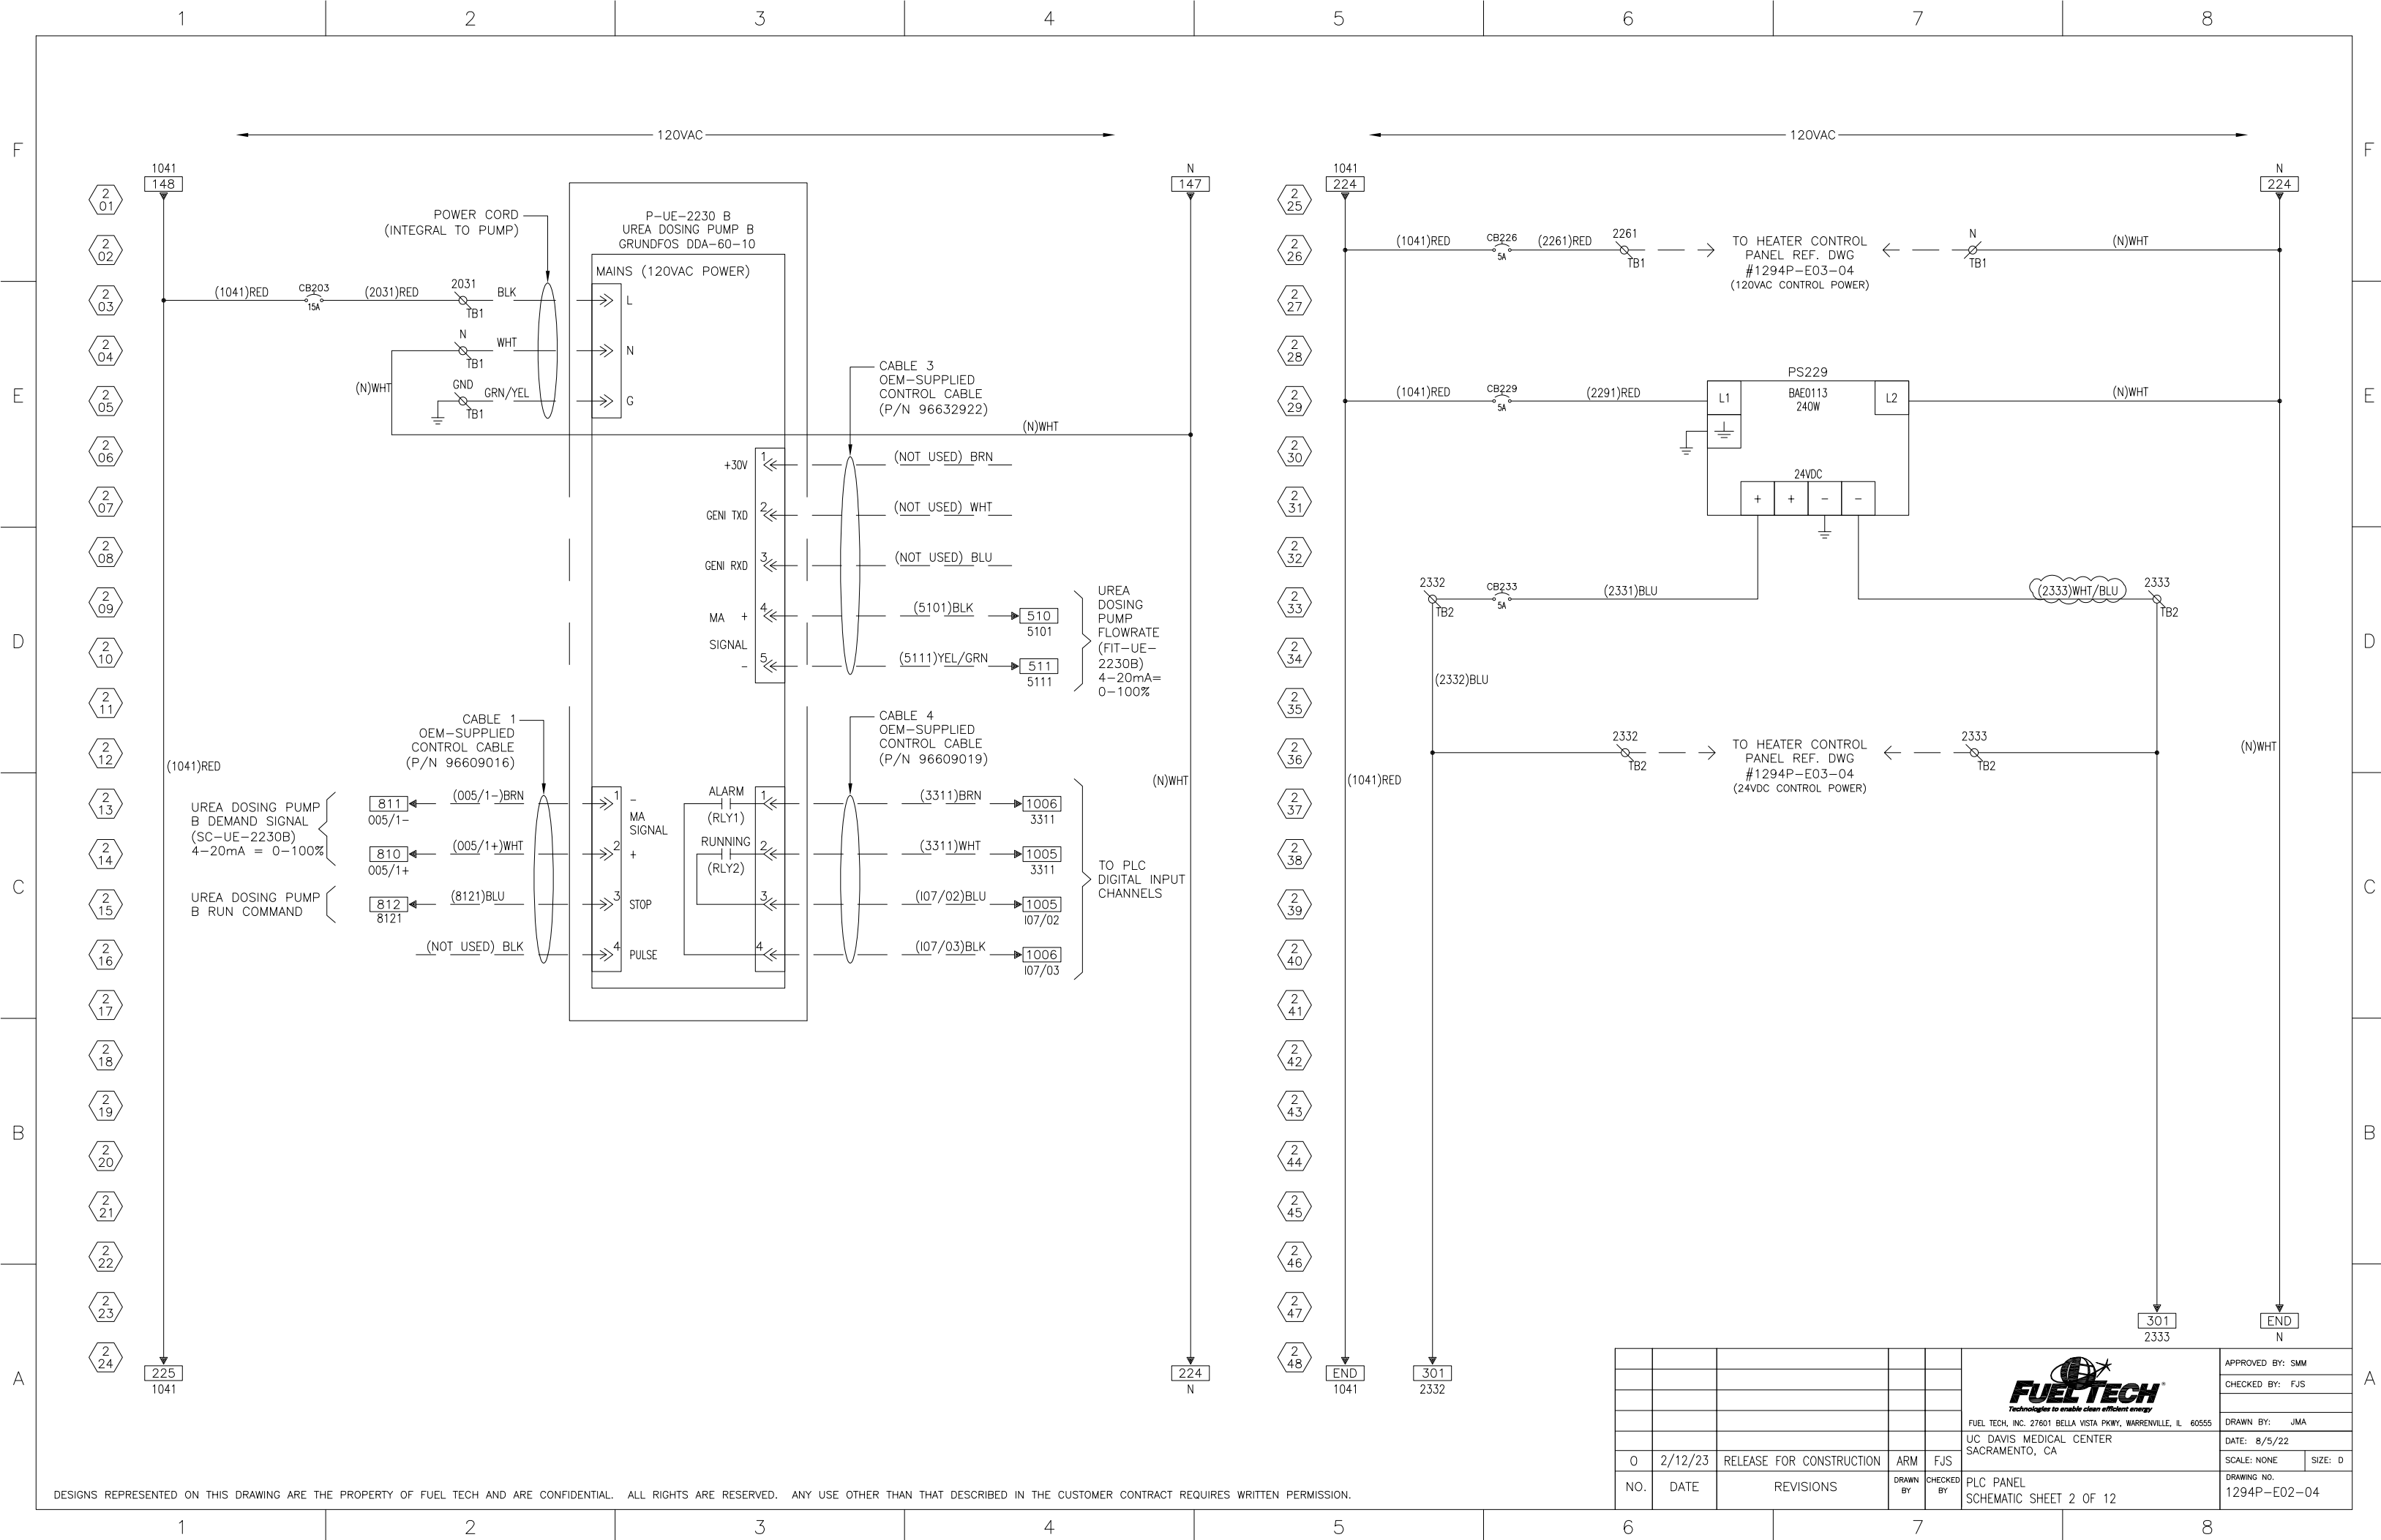


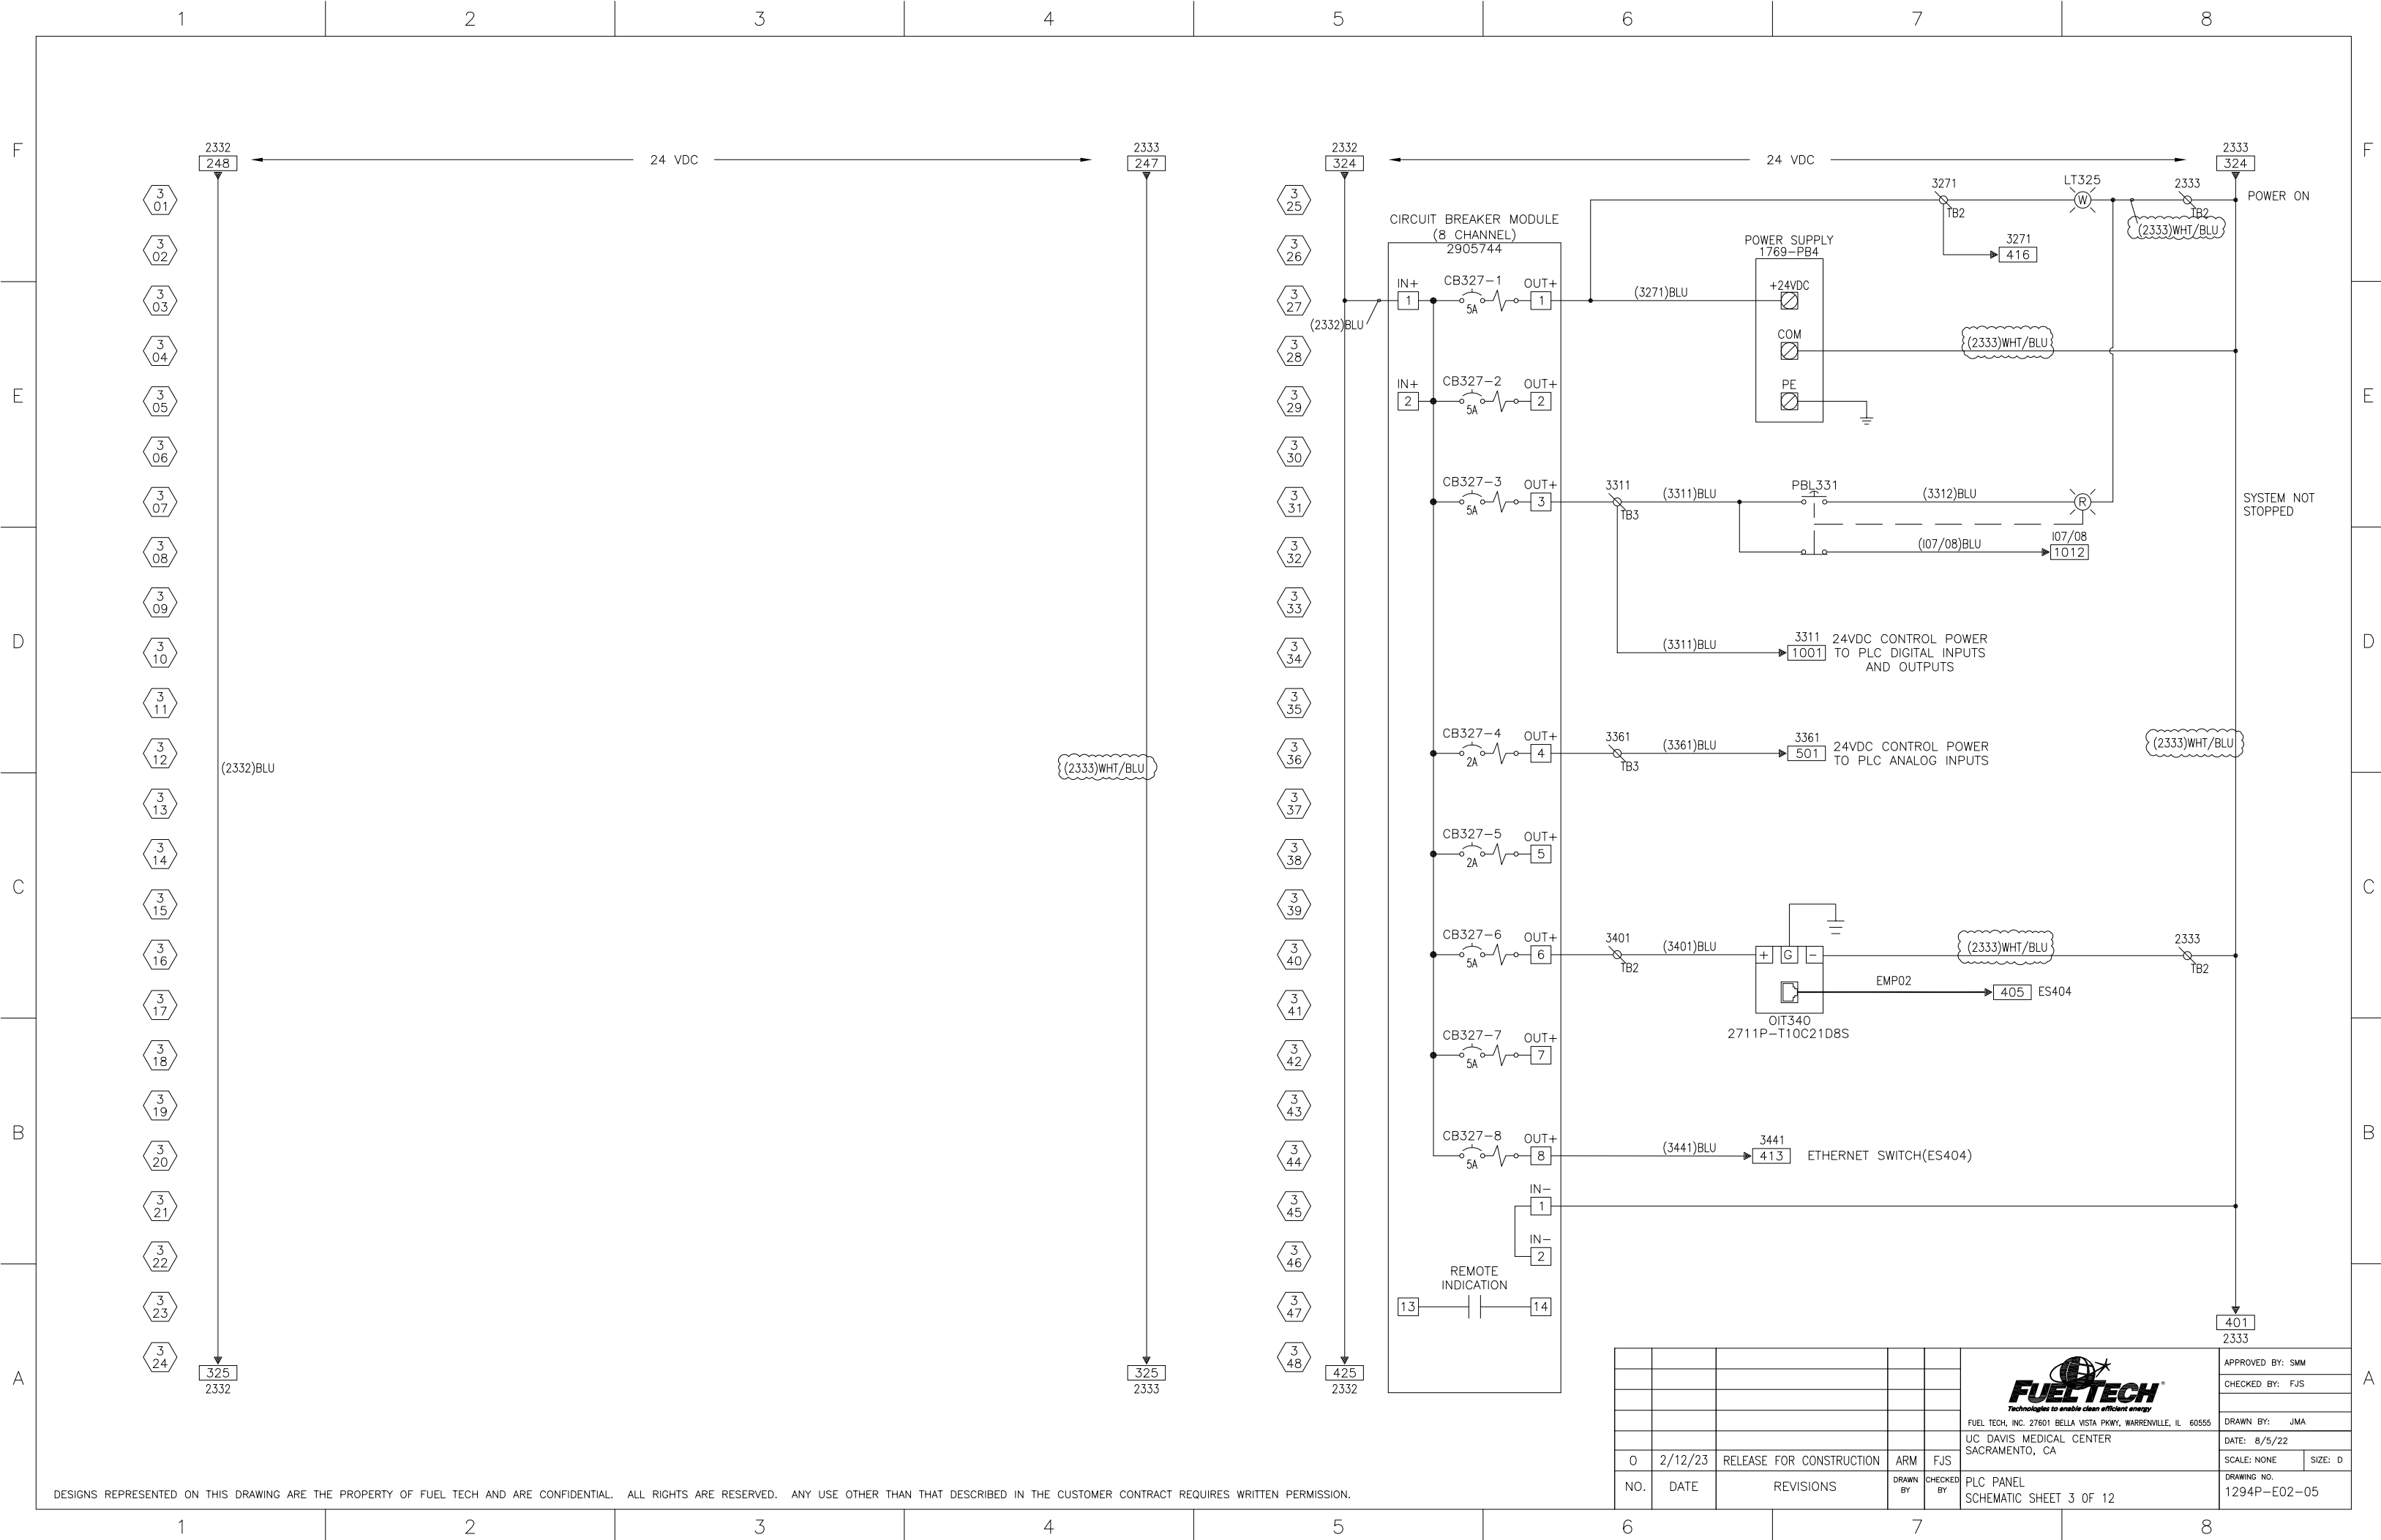


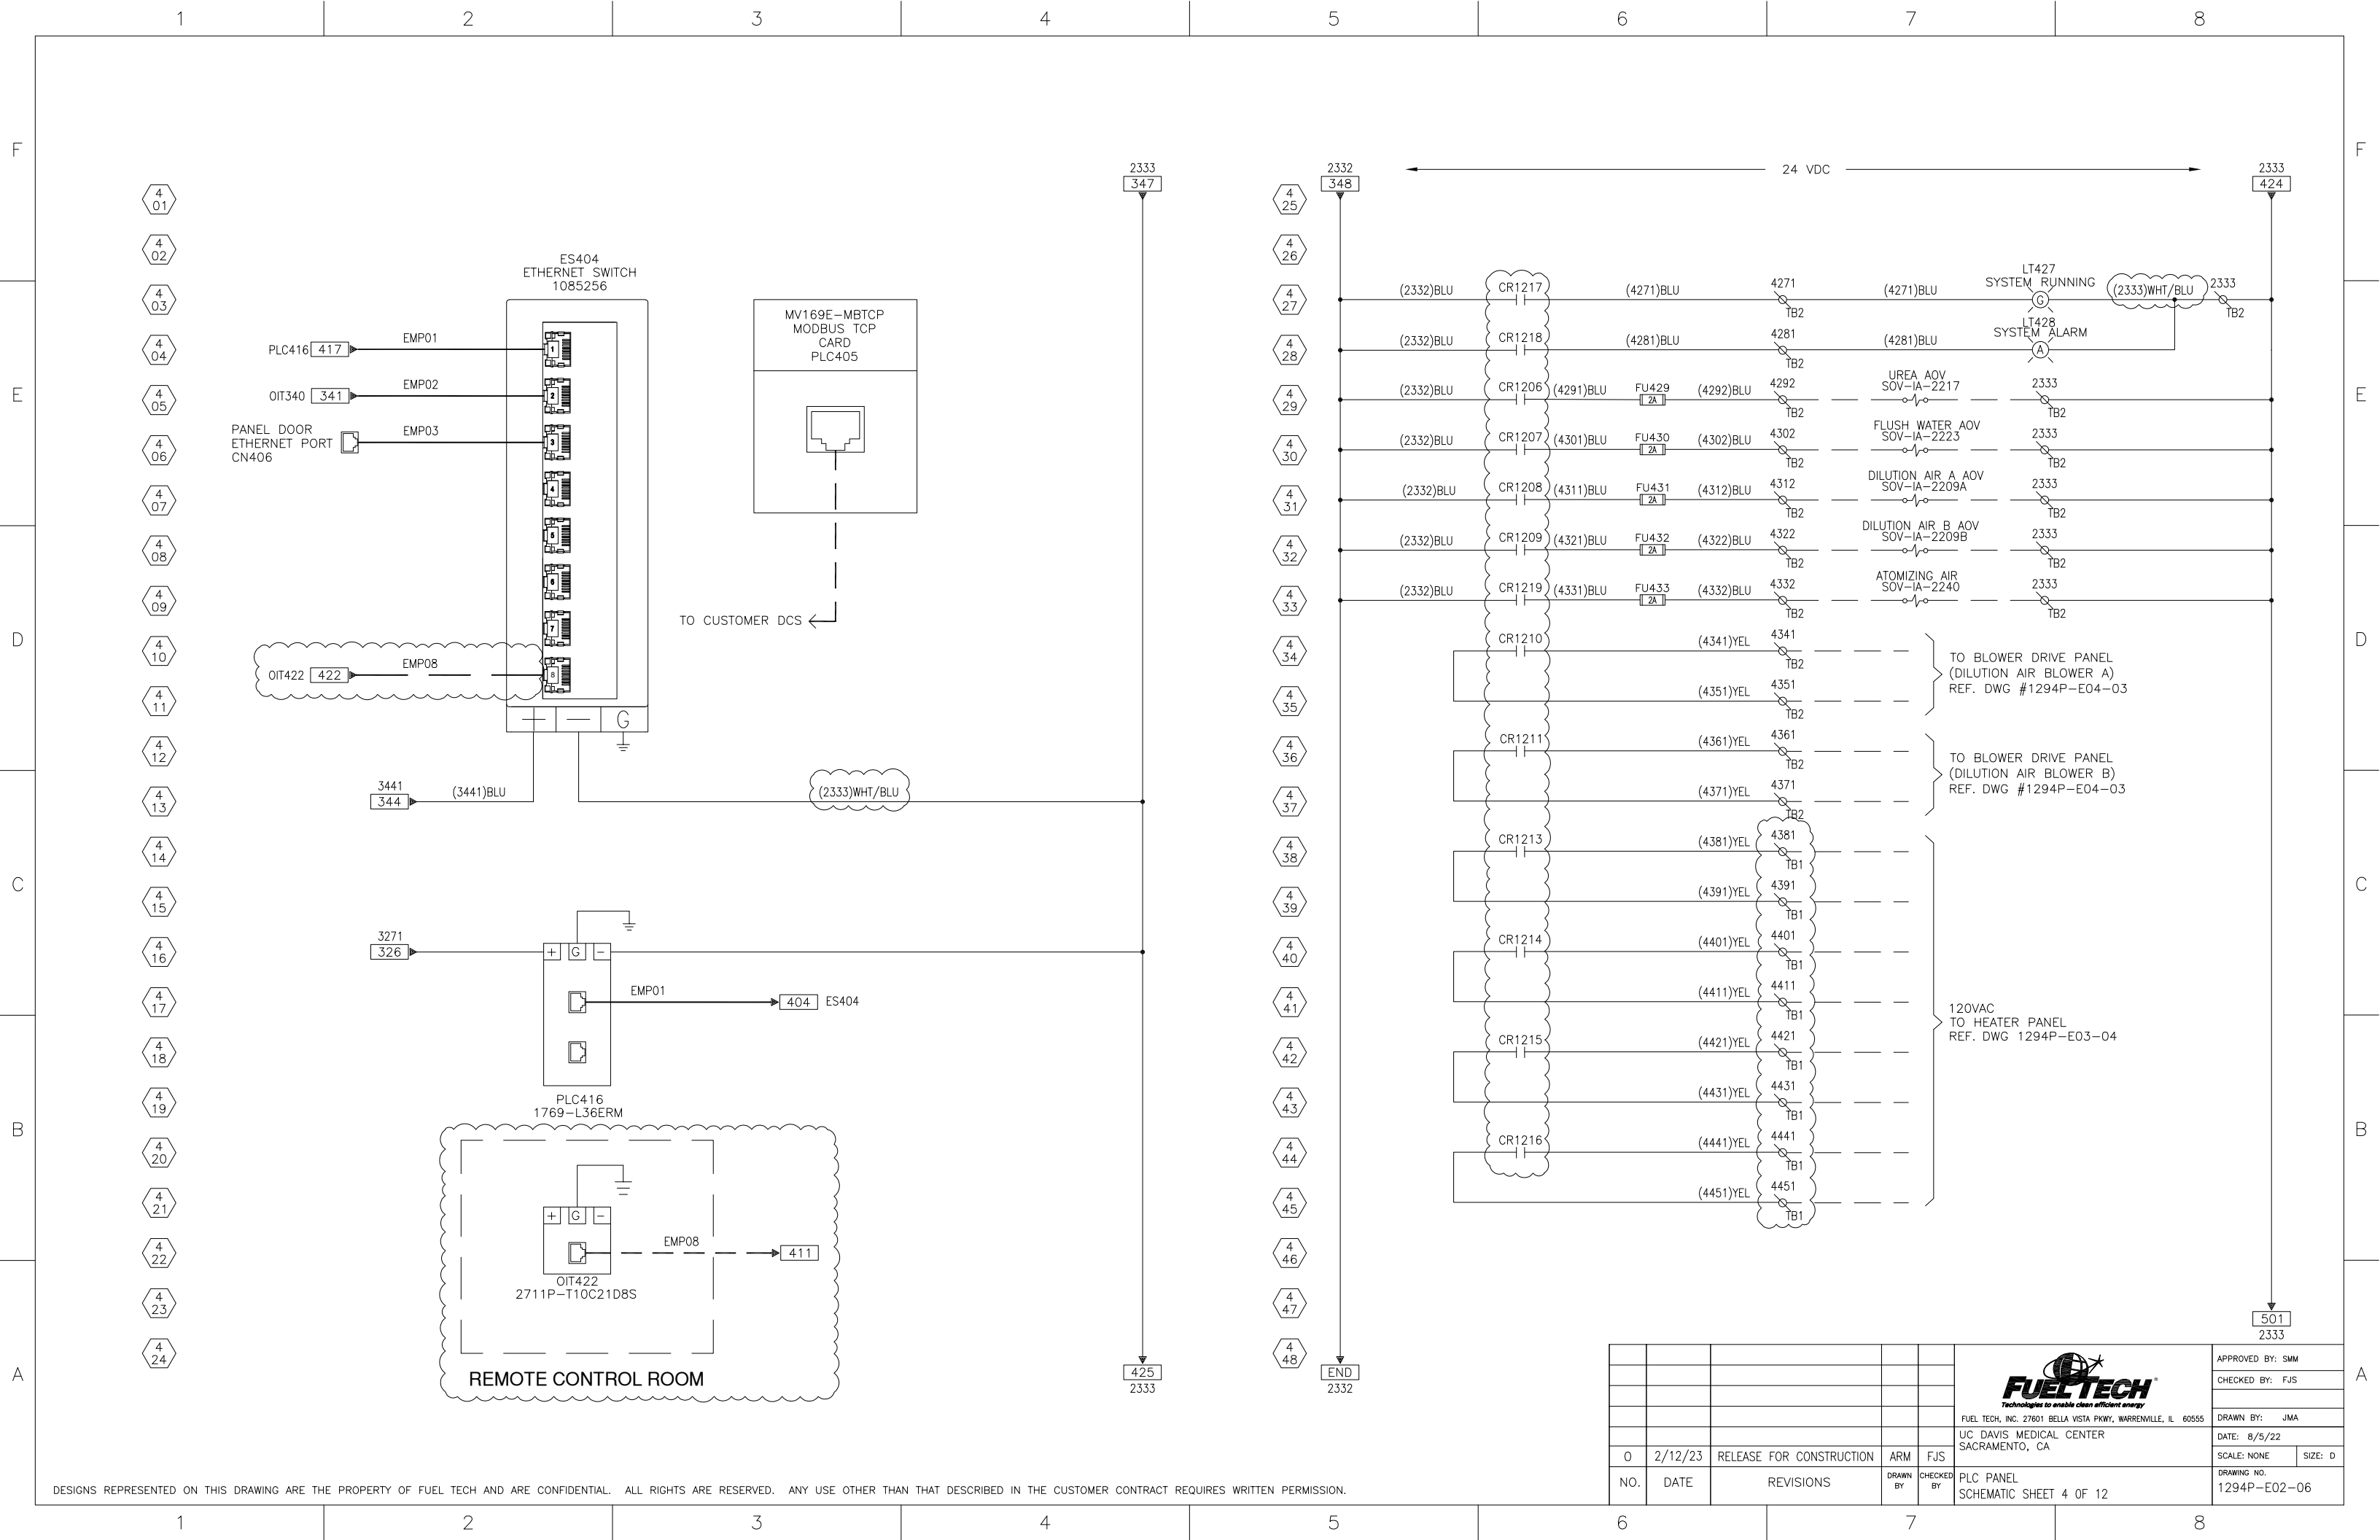



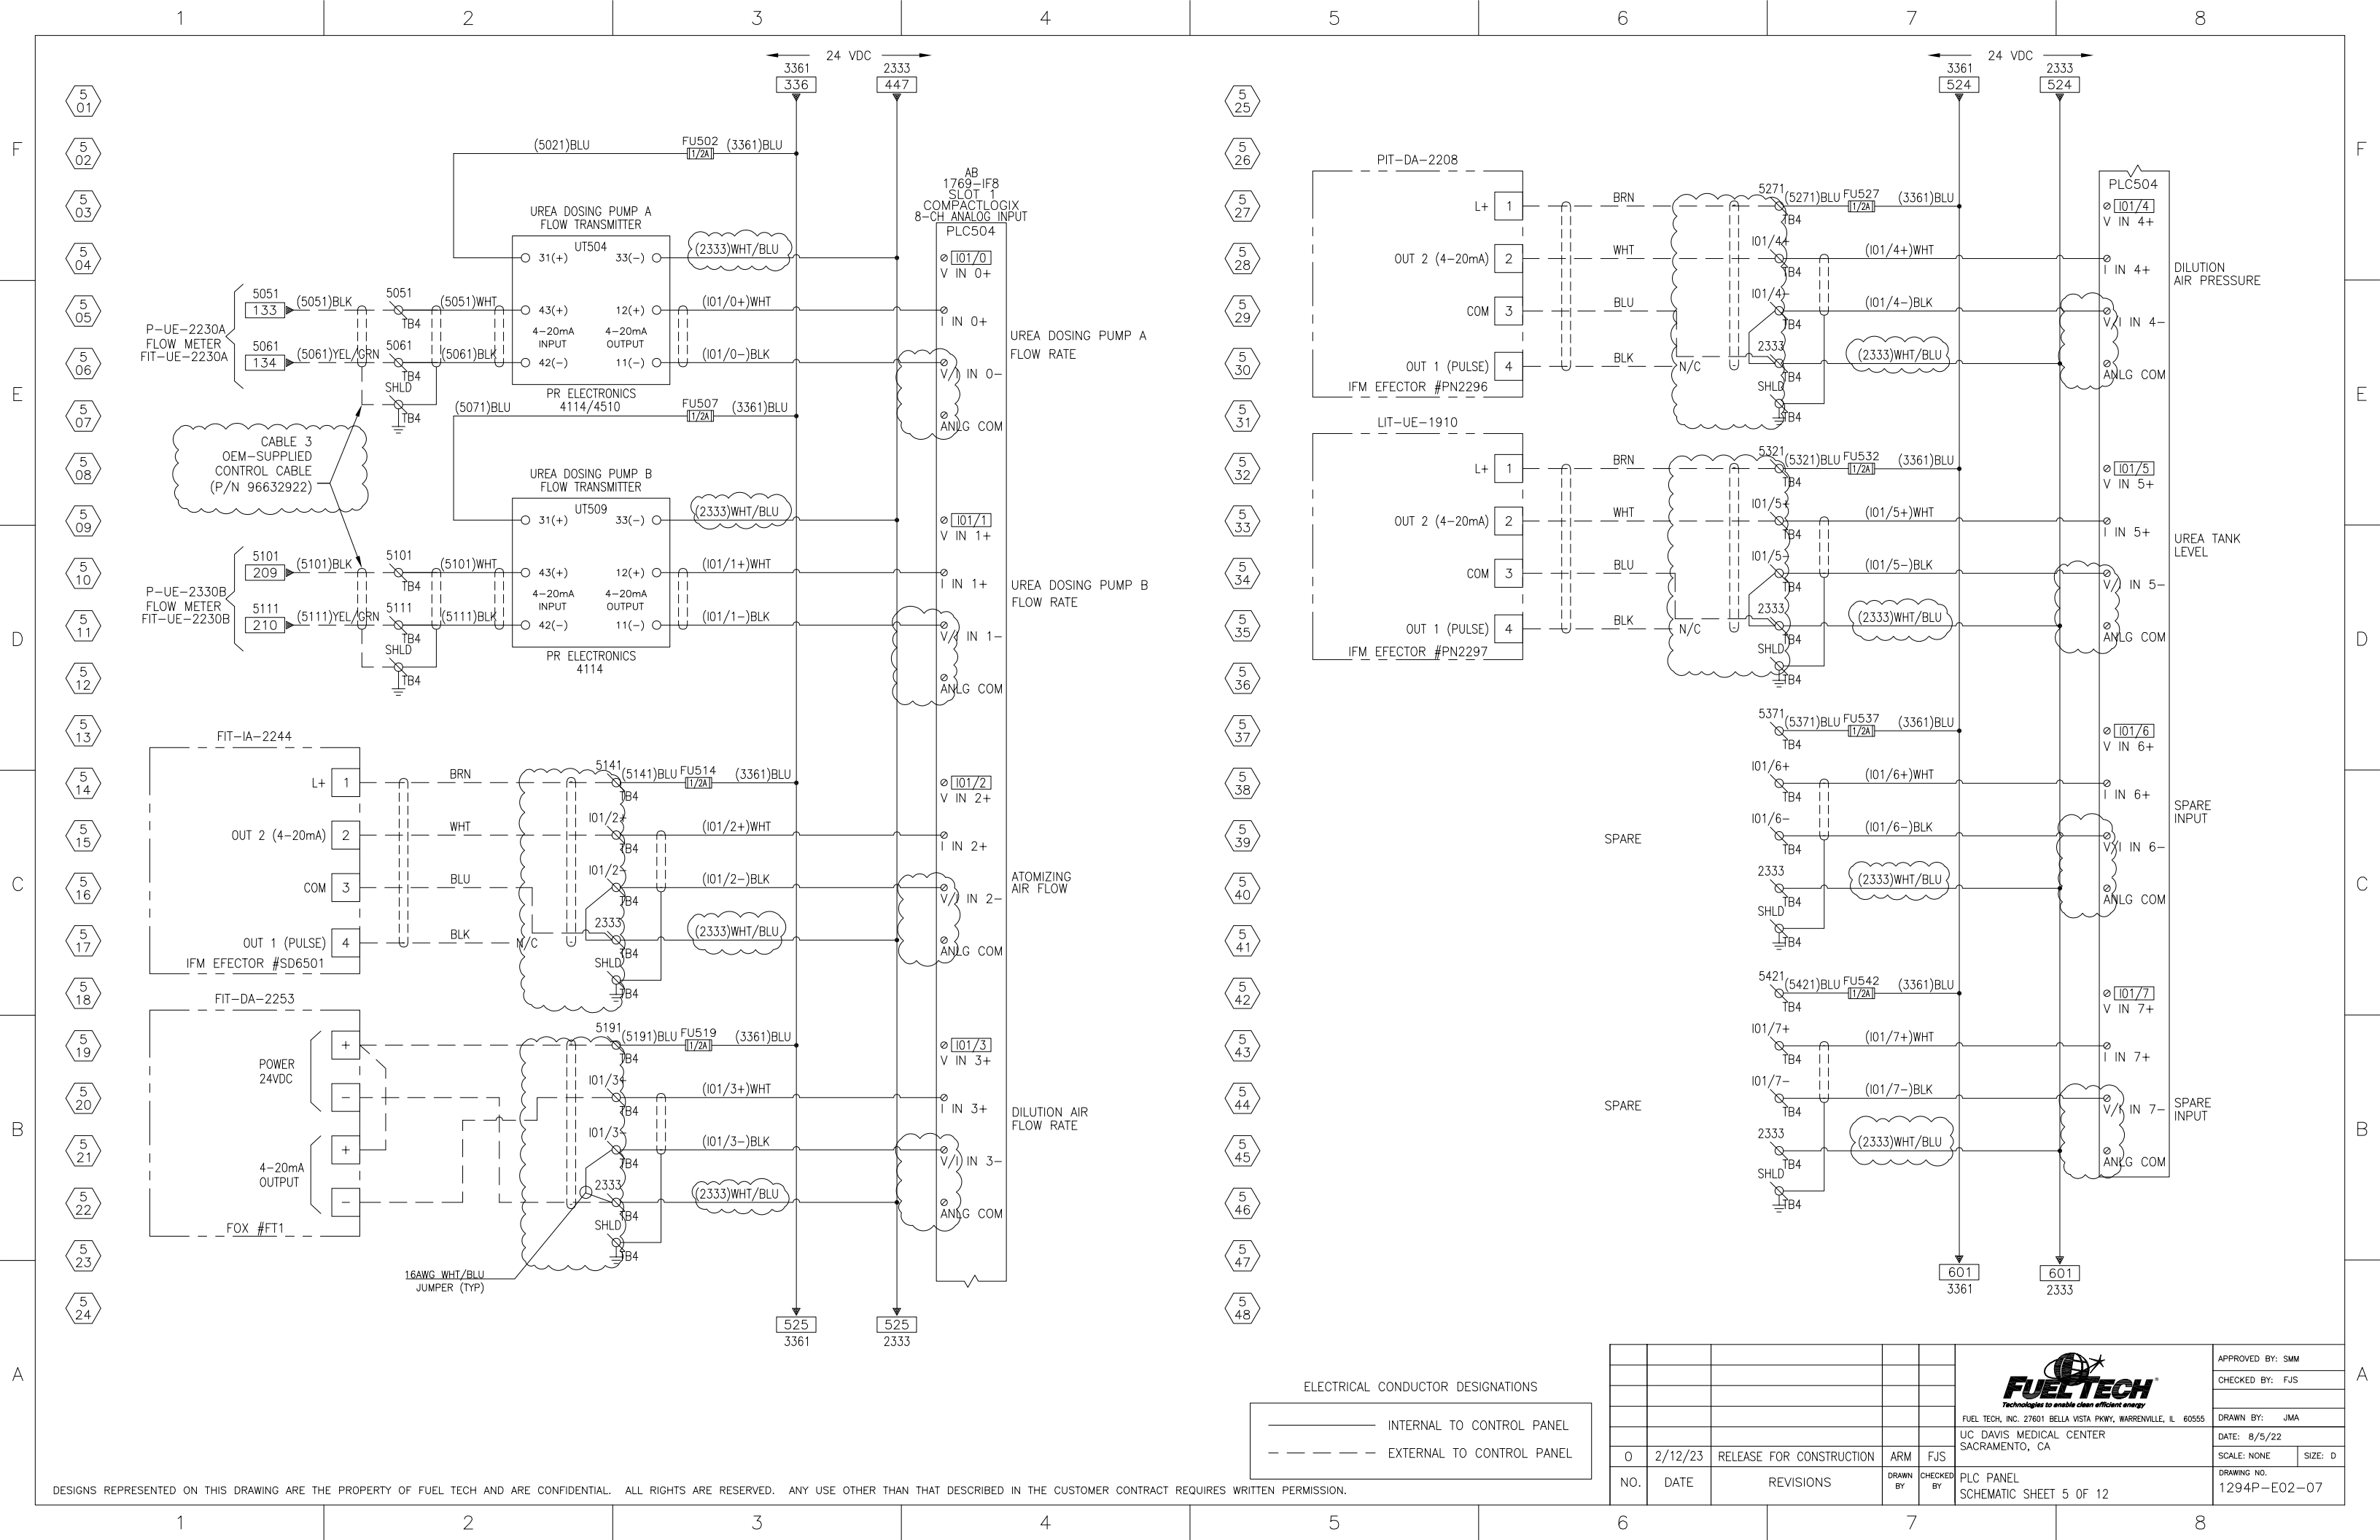


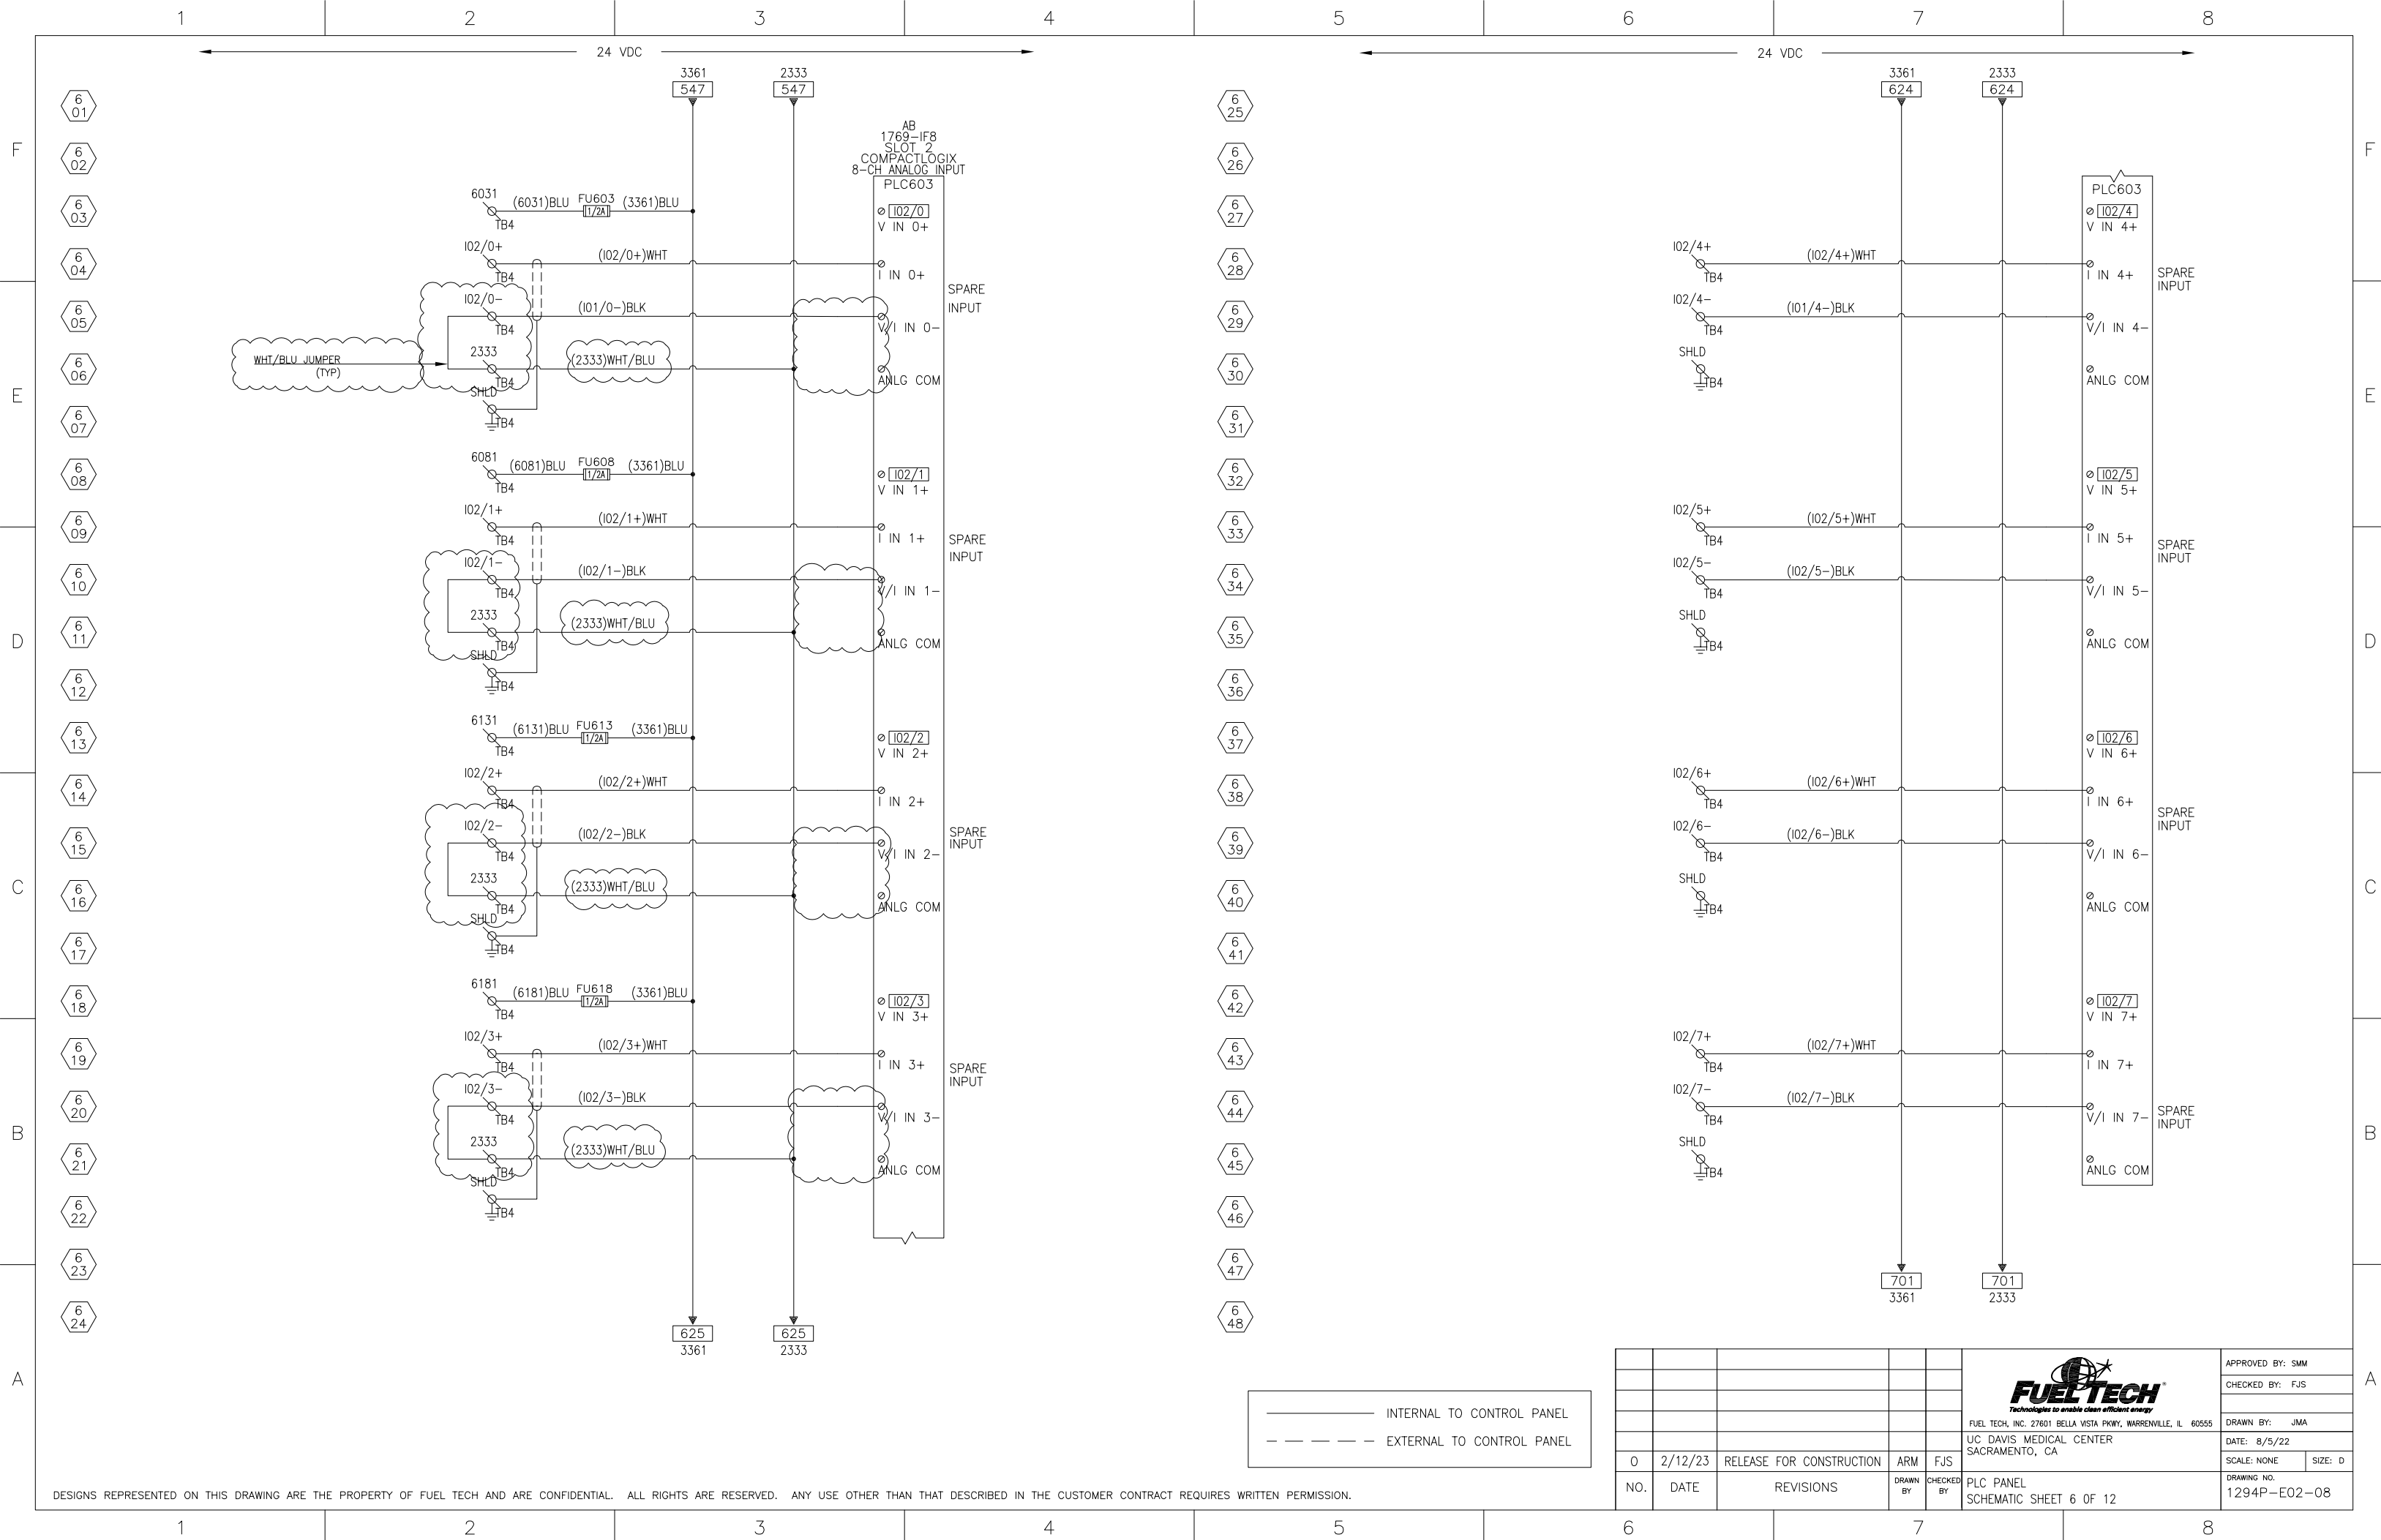

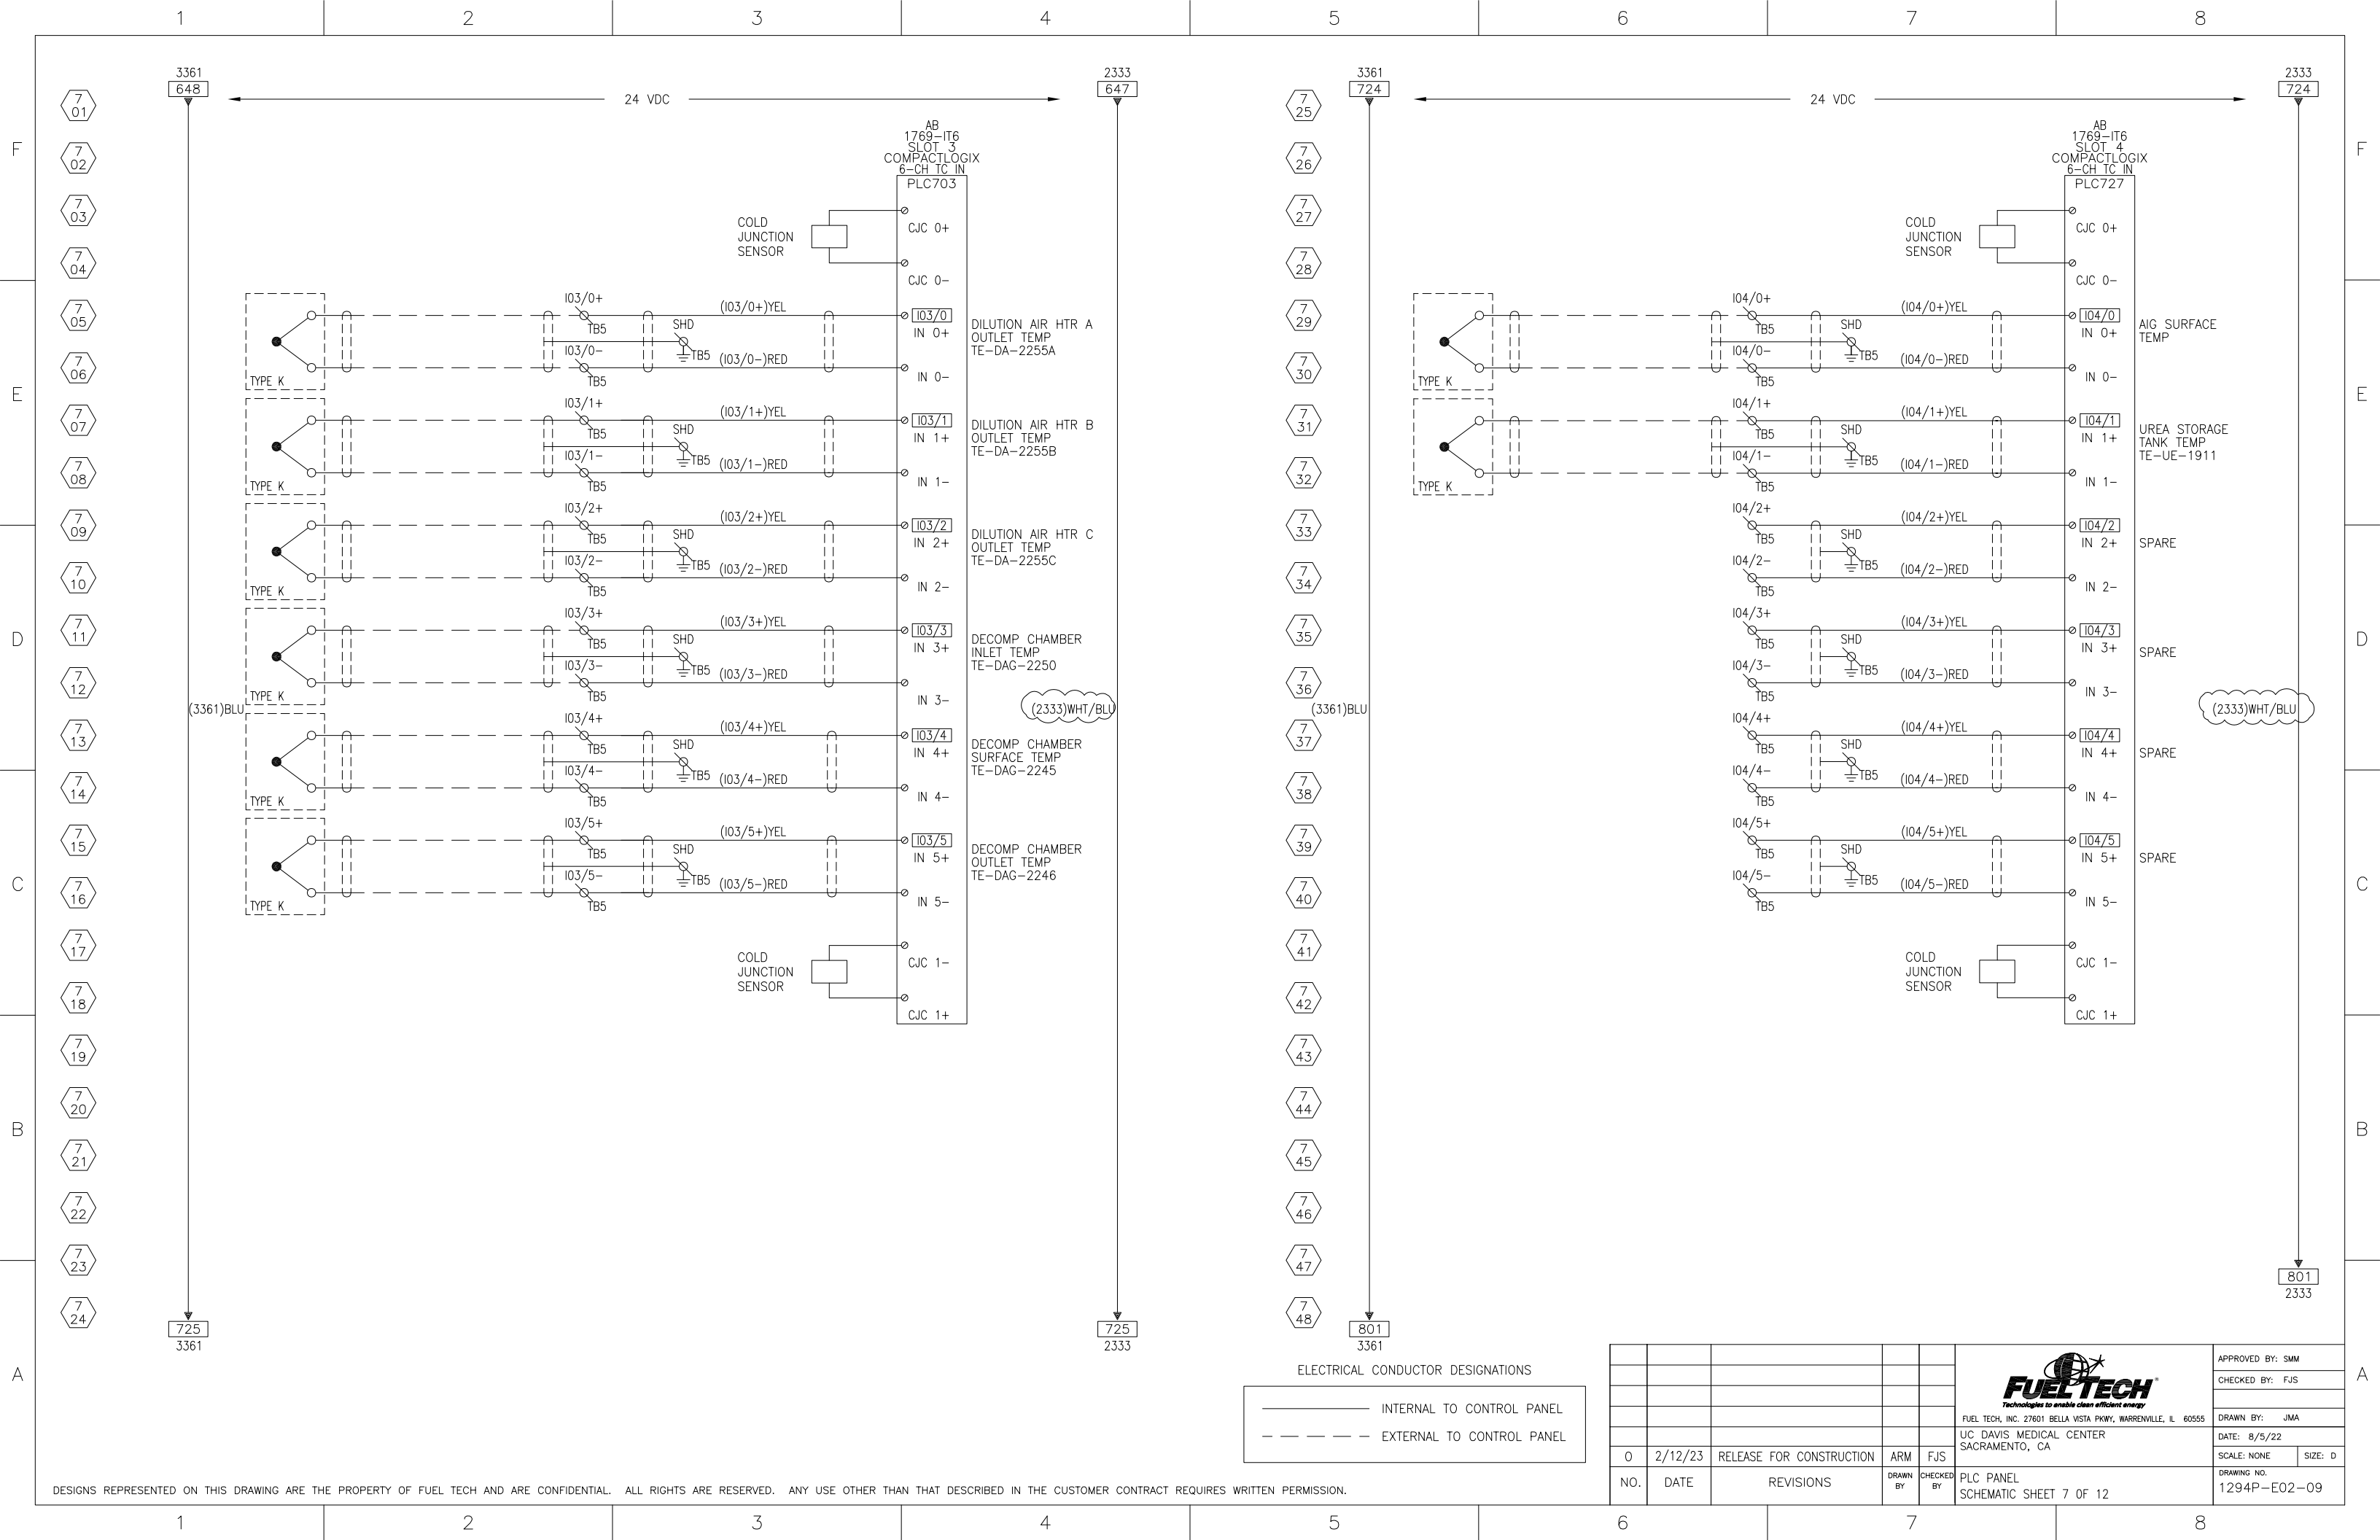

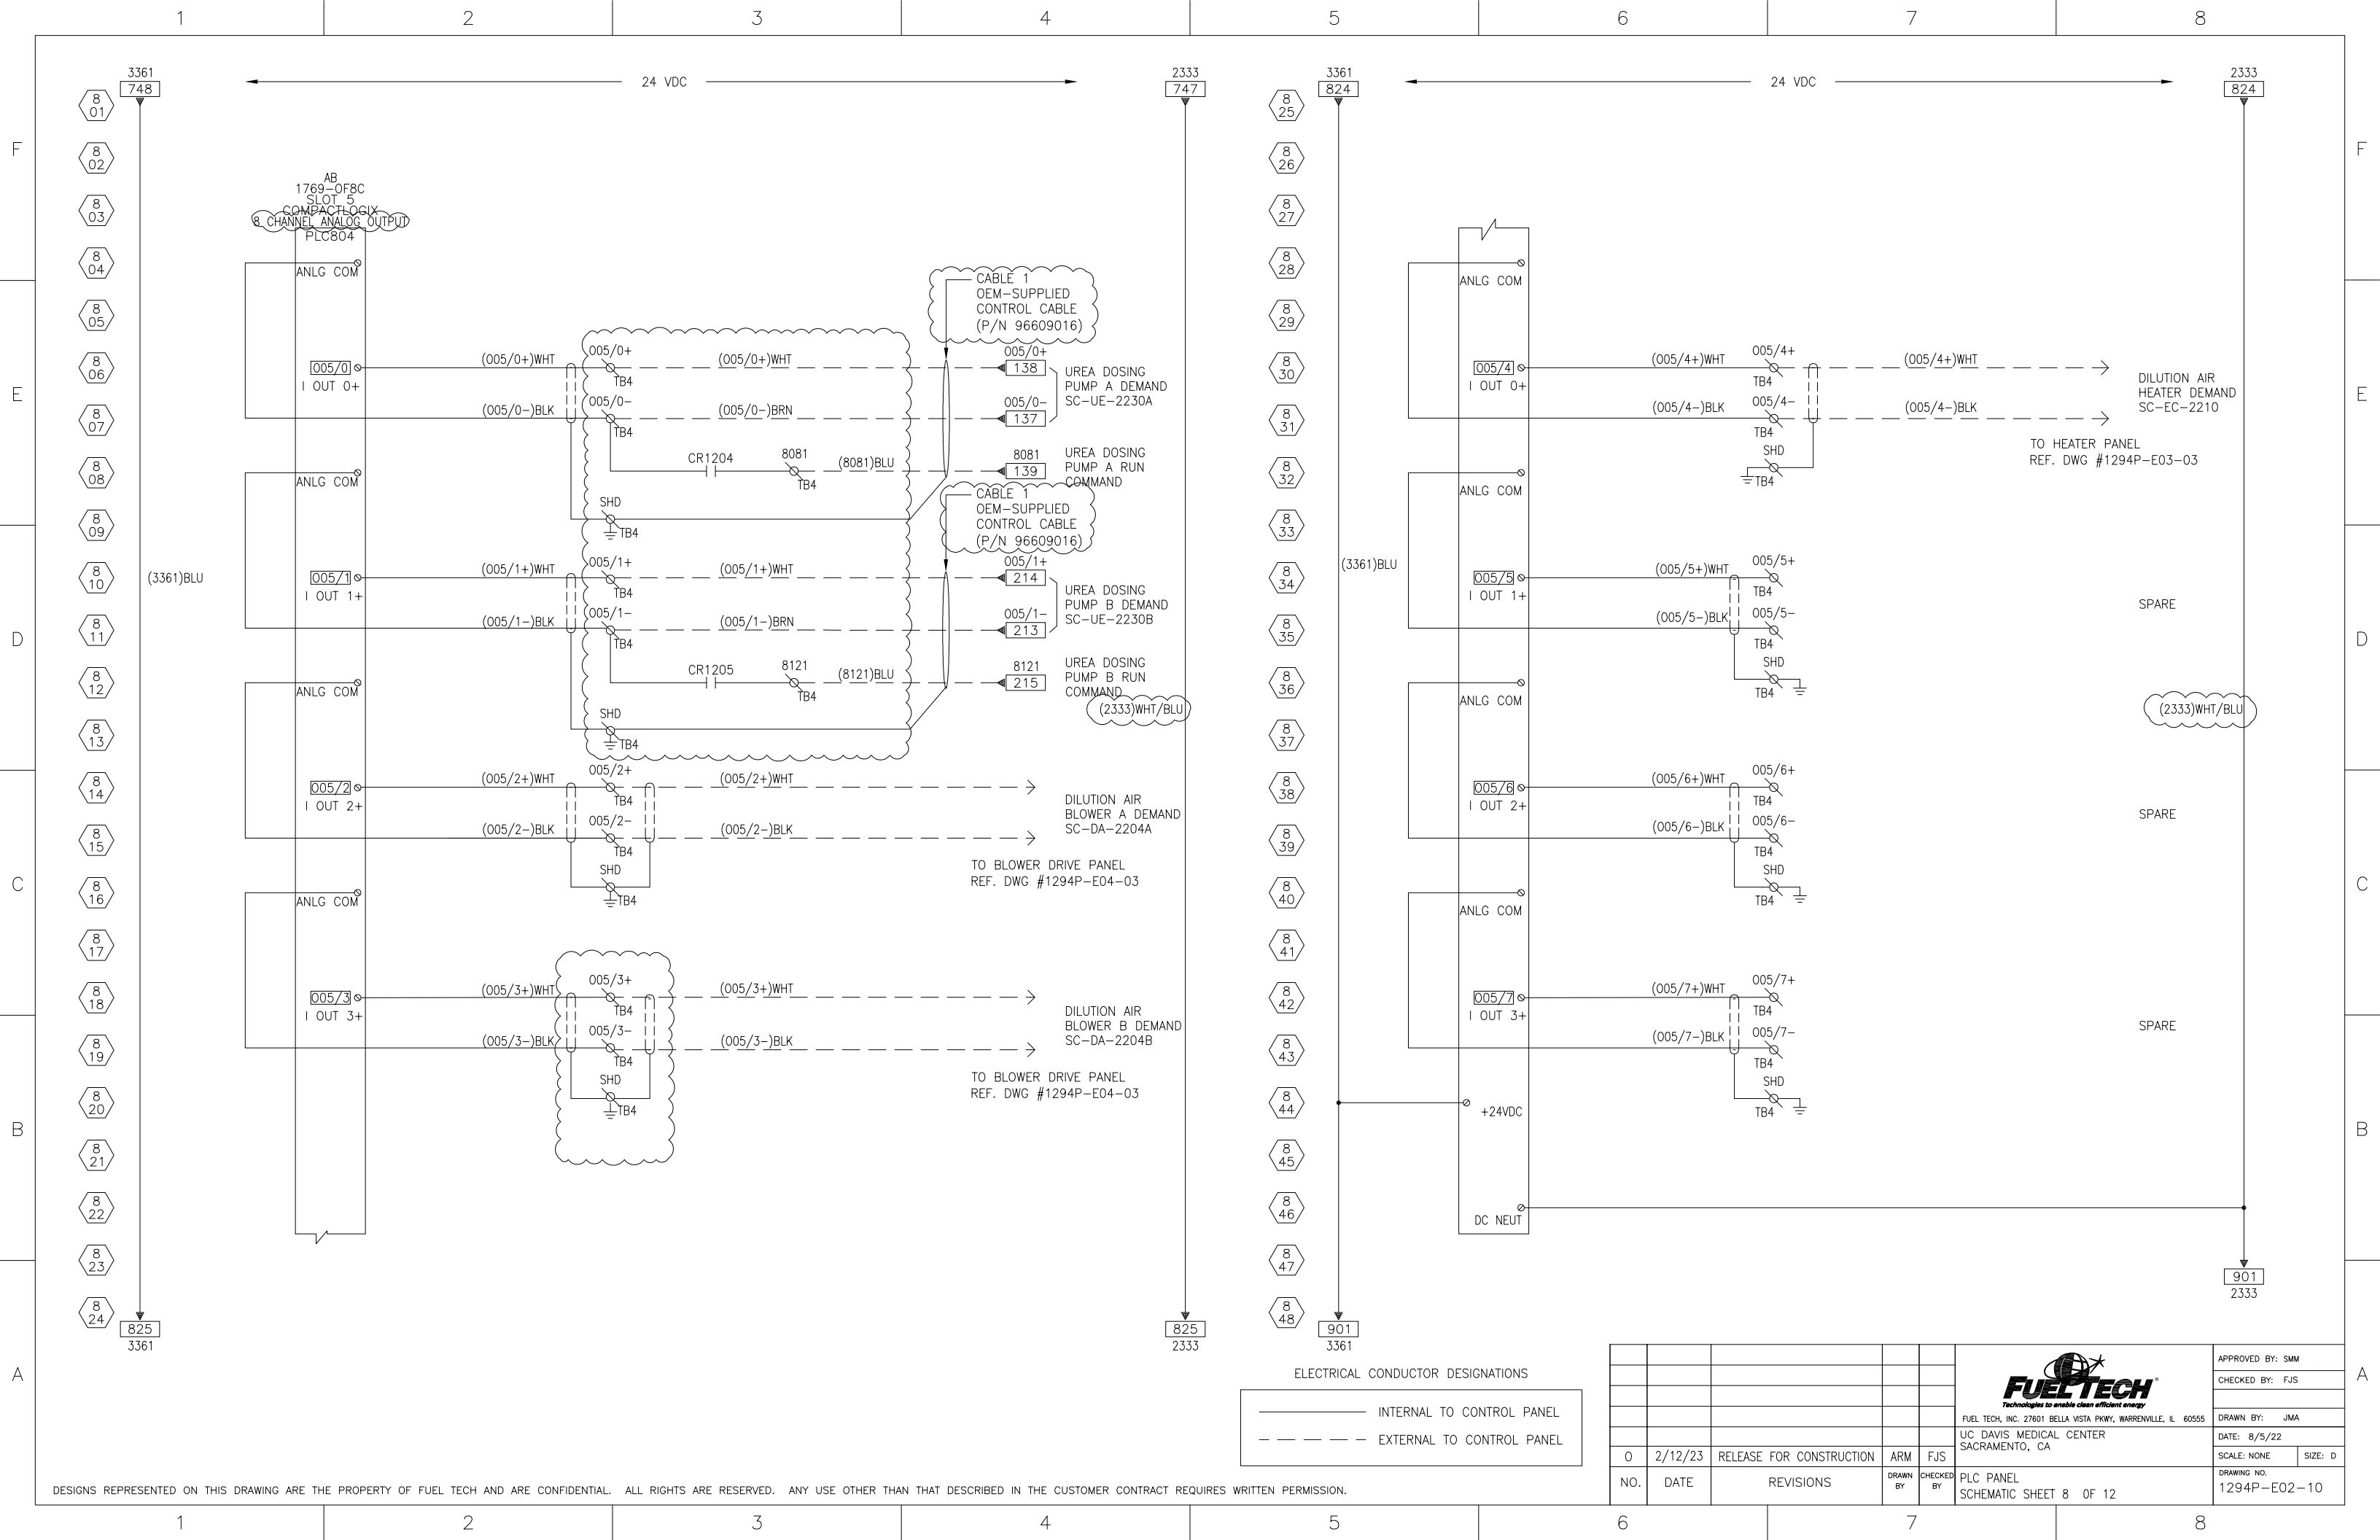

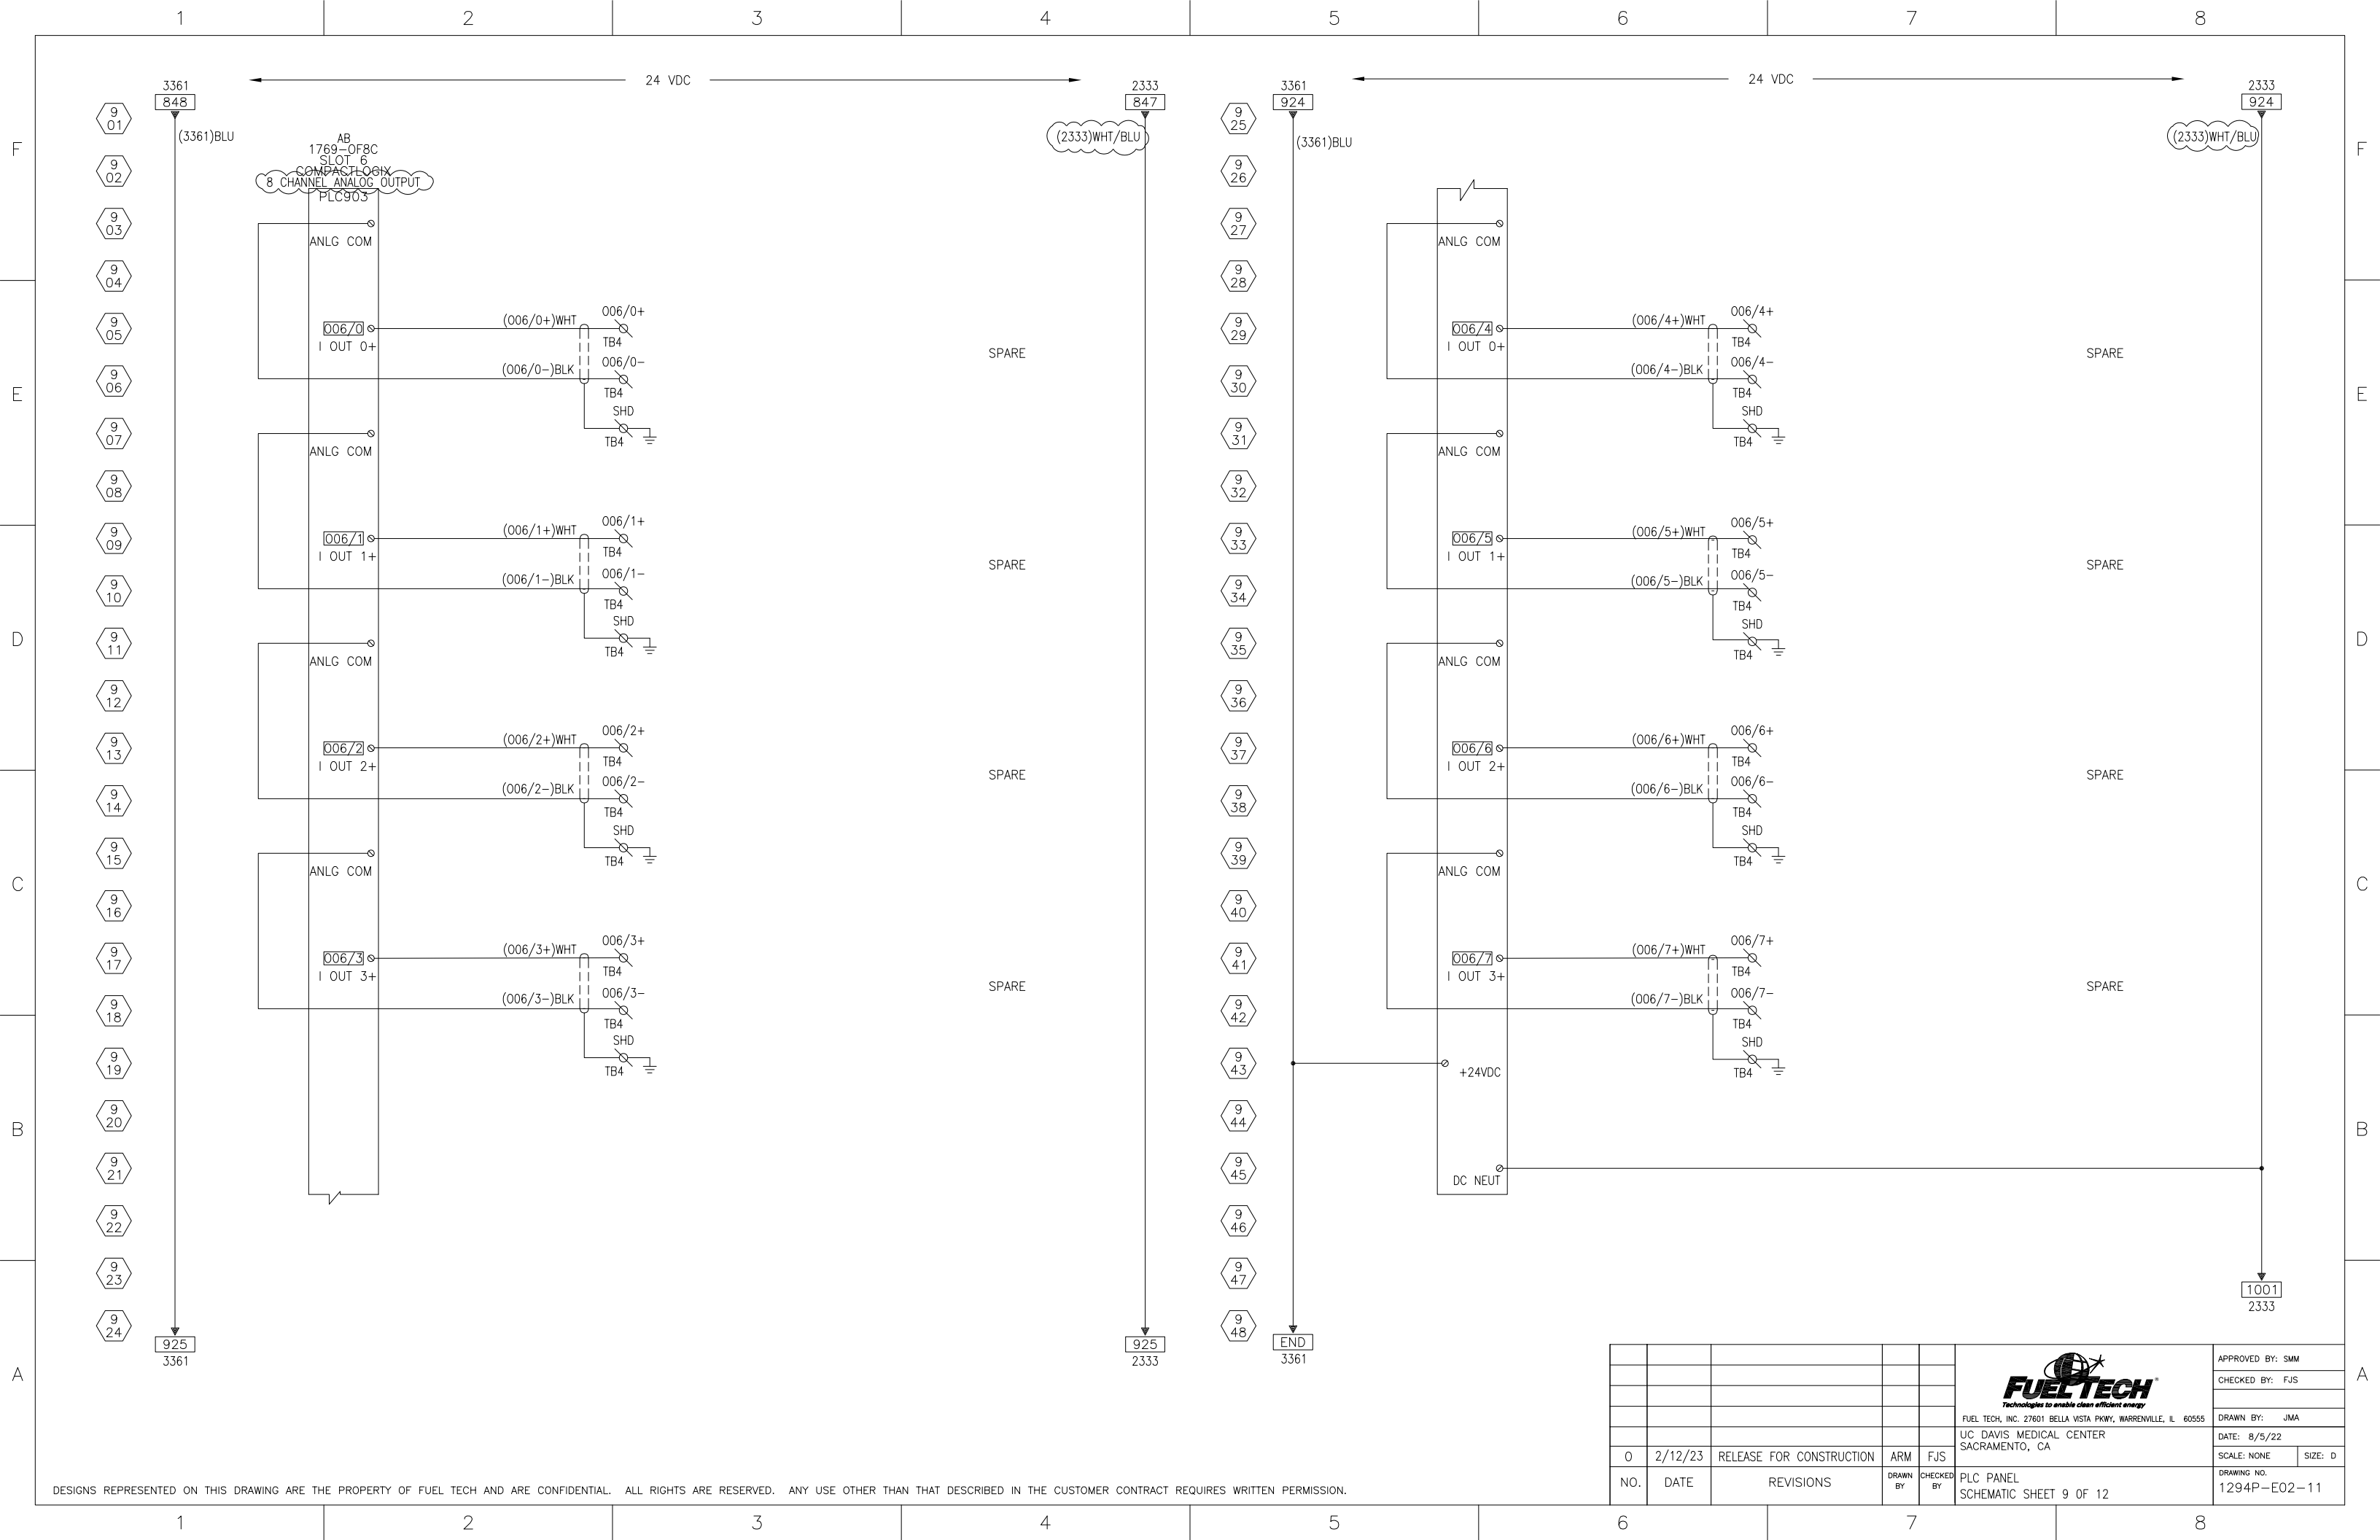

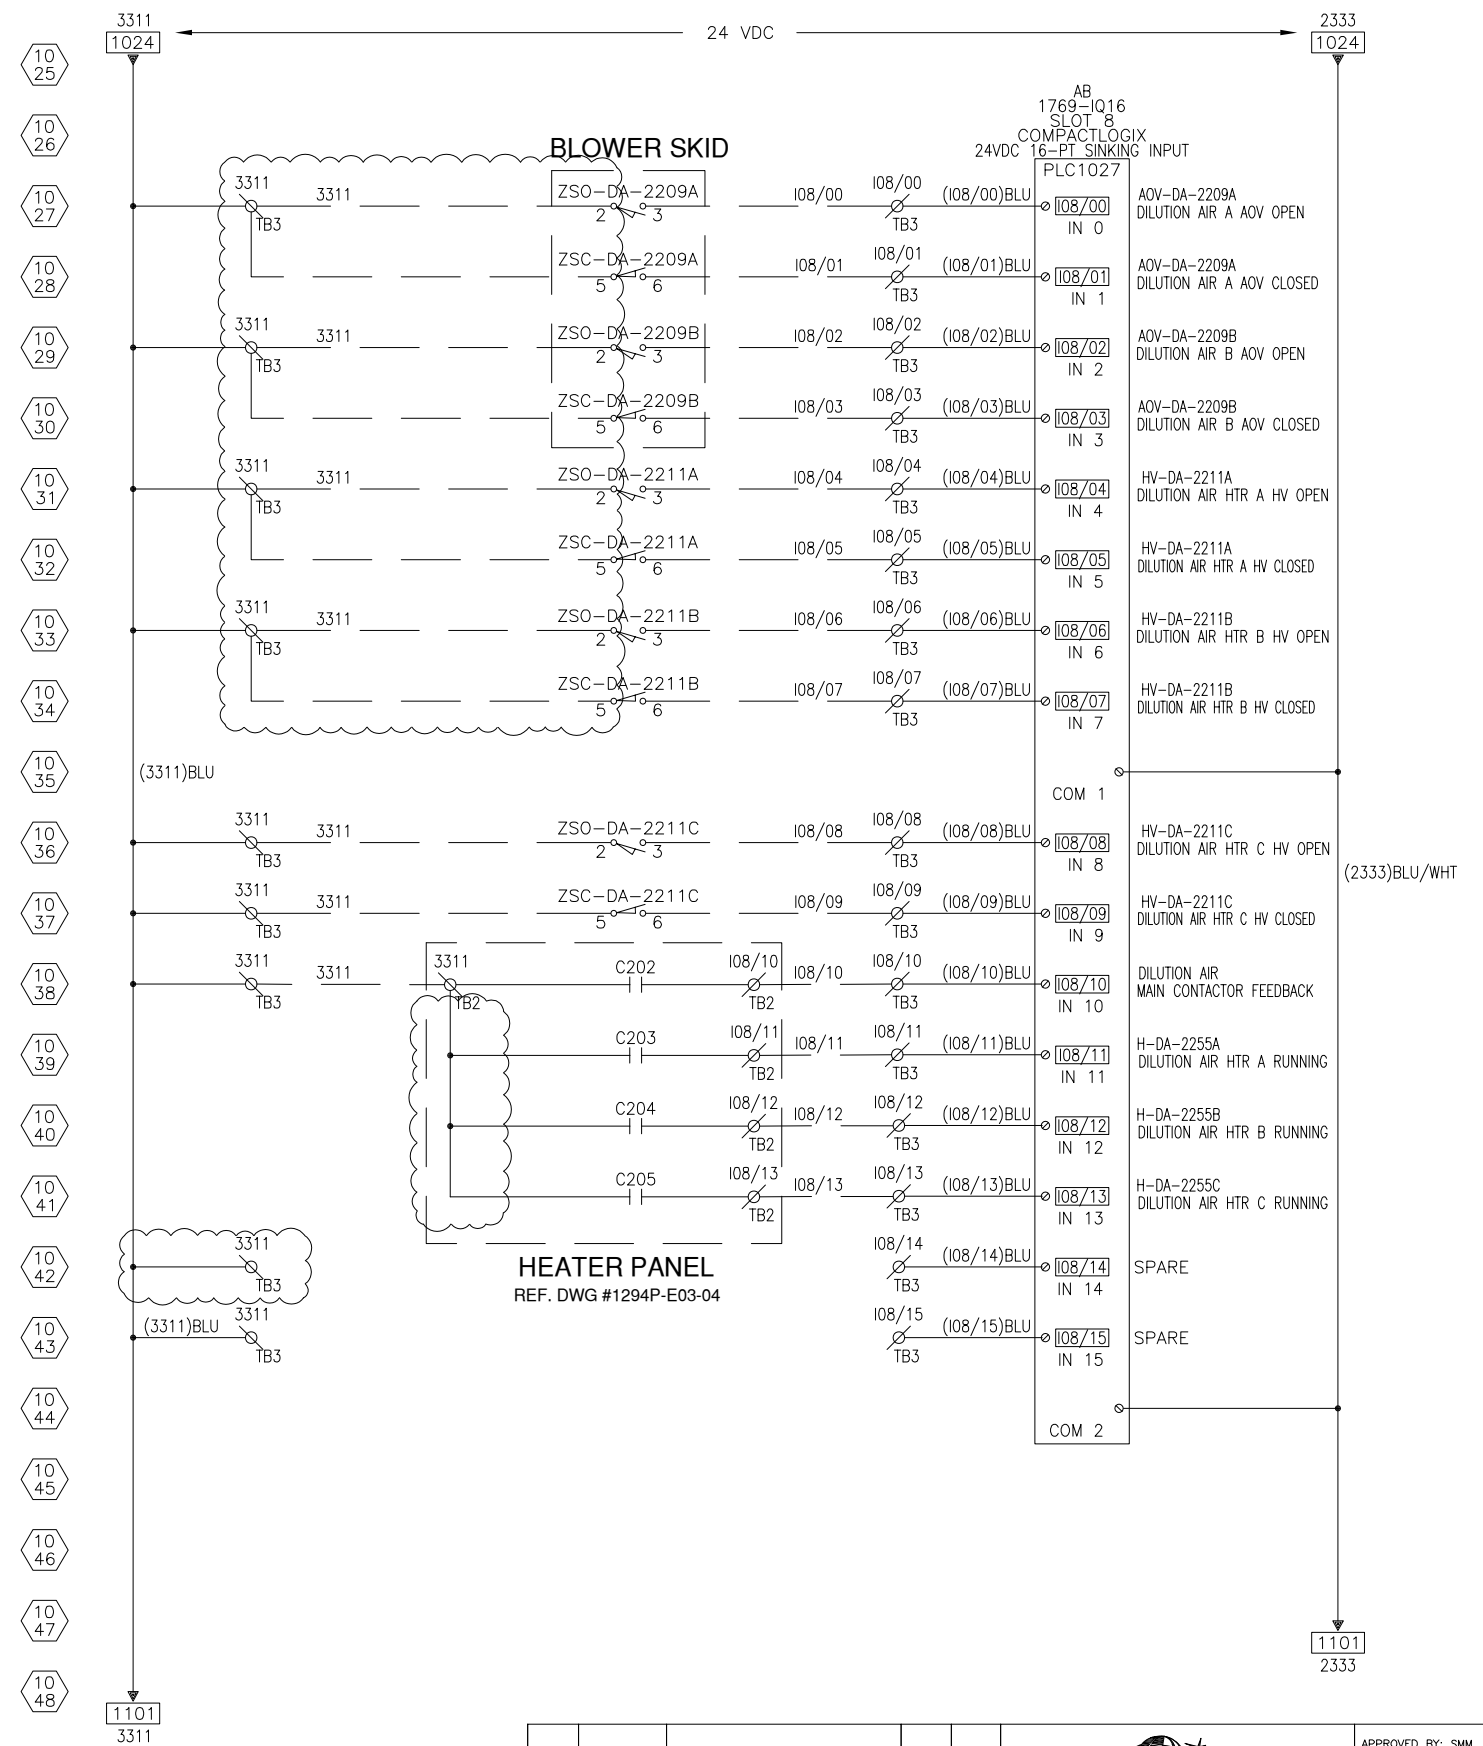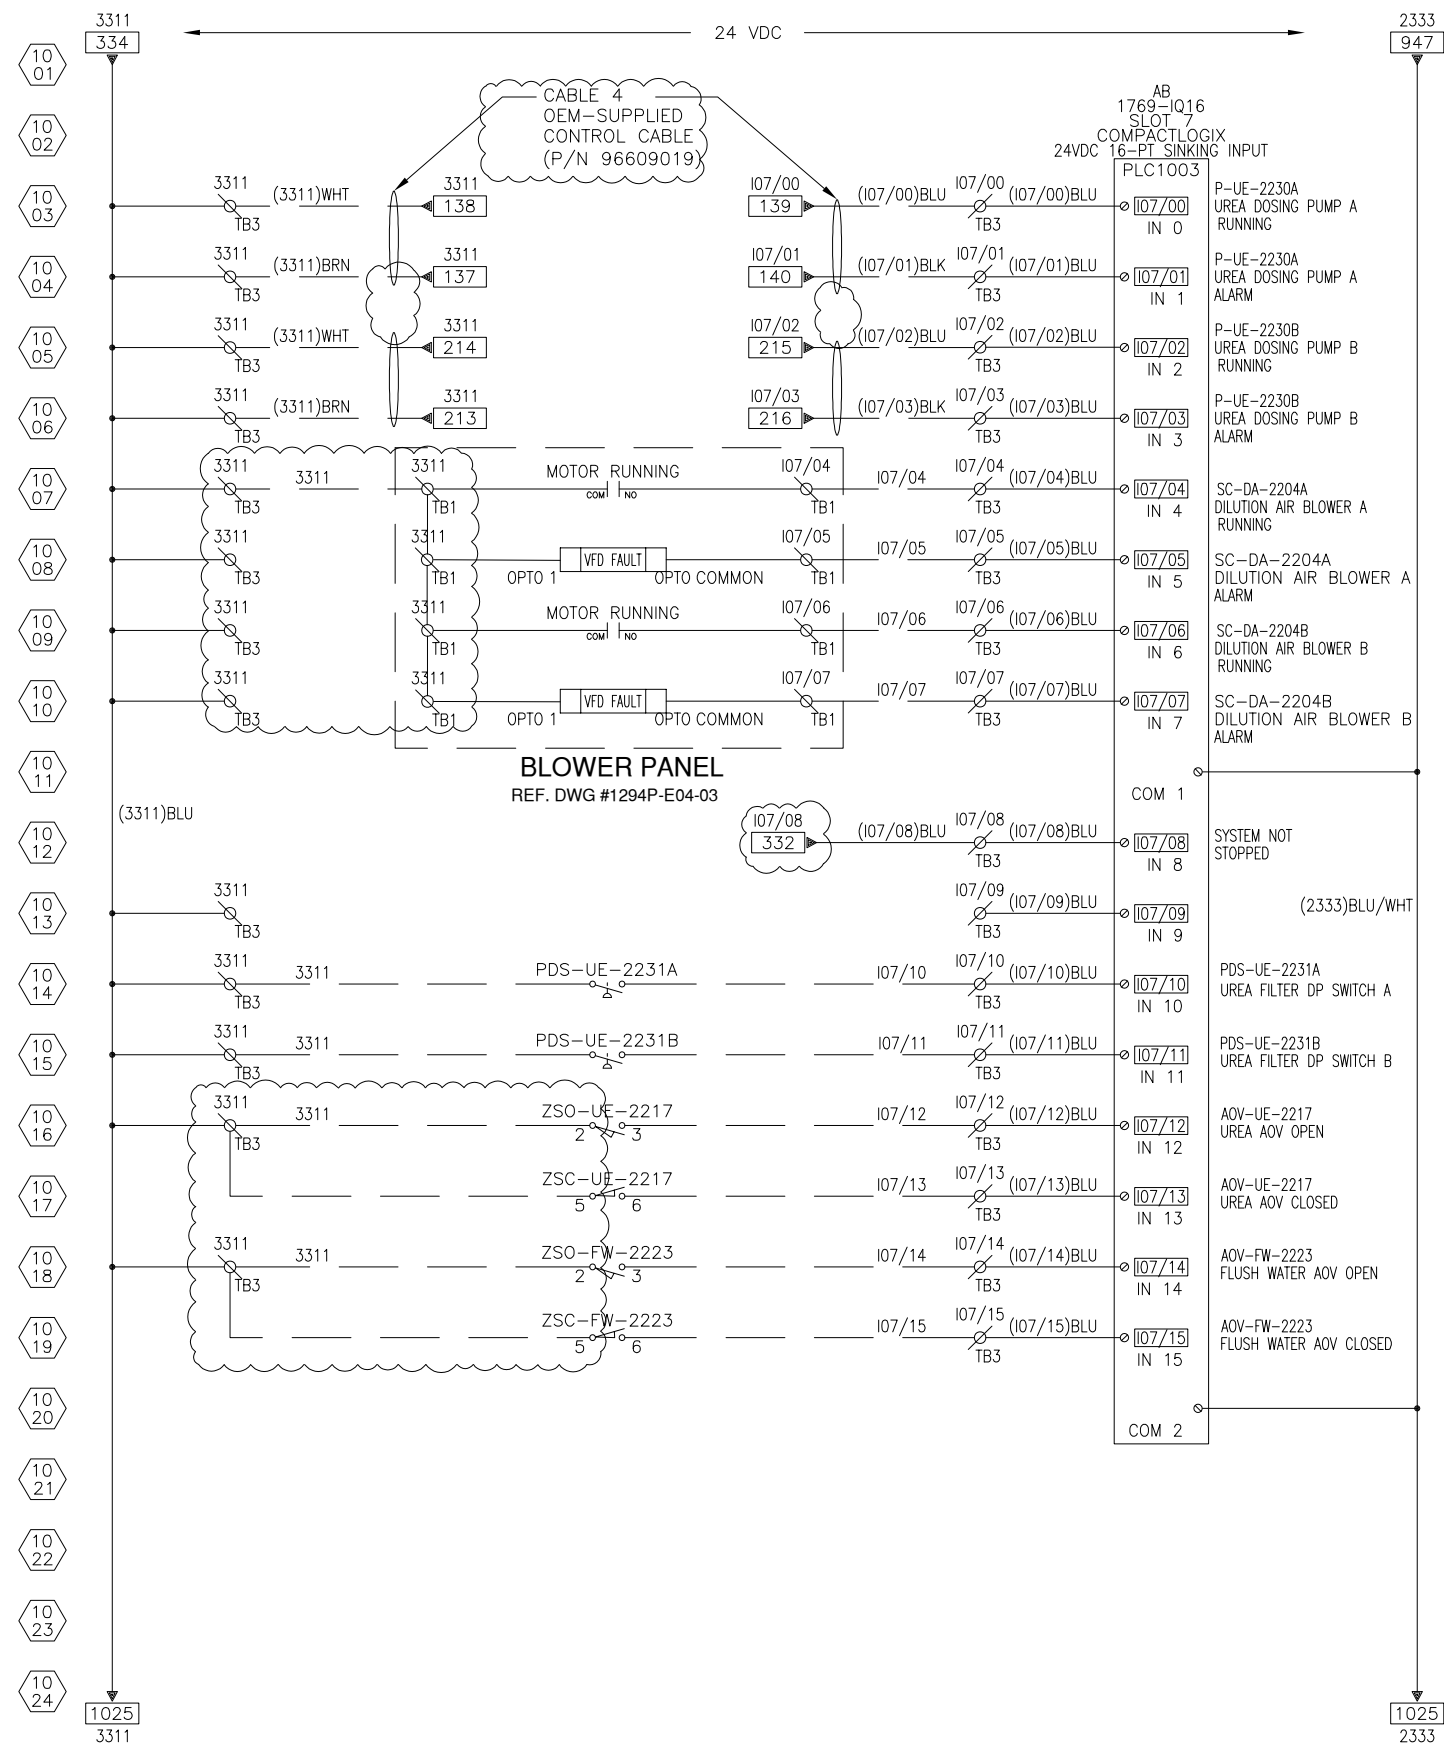


						APPROVED BY: SMM	
						CHECKED BY: FJS	
						DRAWN BY: JMA	
					FUEL TECH, INC. 27601 BELLA VISTA PKWY, WARRENVILLE, IL 60555	DATE: 8/5/22	
0	2/12/23	RELEASE FOR CONSTRUCTION	ARM	FJS	UC DAVIS MEDICAL CENTER SACRAMENTO, CA	SCALE: NONE	SIZE: D
NO.	DATE	REVISIONS	DRAWN BY	CHECKED BY	PLC PANEL SCHEMATIC SHEET 10 OF 12	DRAWING NO. 1294P-E02-12	

DESIGNS REPRESENTED ON THIS DRAWING ARE THE PROPERTY OF FUEL TECH AND ARE CONFIDENTIAL. ALL RIGHTS ARE RESERVED. ANY USE OTHER THAN THAT DESCRIBED IN THE CUSTOMER CONTRACT REQUIRES WRITTEN PERMISSION.



						APPROVED BY: SMM	
						CHECKED BY: FJS	
						DRAWN BY: JMA	
					FUEL TECH, INC. 27601 BELLA VISTA PKWY, WARRENVILLE, IL 60555		DATE: 8/5/22
					UC DAVIS MEDICAL CENTER SACRAMENTO, CA		SCALE: NONE SIZE: D
0	2/12/23	RELEASE FOR CONSTRUCTION	ARM	FJS			DRAWING NO. 1294P-E02-13
NO.	DATE	REVISIONS	DRAWN BY	CHECKED BY	PLC PANEL SCHEMATIC SHEET 11 OF 12		

DESIGNS REPRESENTED ON THIS DRAWING ARE THE PROPERTY OF FUEL TECH AND ARE CONFIDENTIAL. ALL RIGHTS ARE RESERVED. ANY USE OTHER THAN THAT DESCRIBED IN THE CUSTOMER CONTRACT REQUIRES WRITTEN PERMISSION.

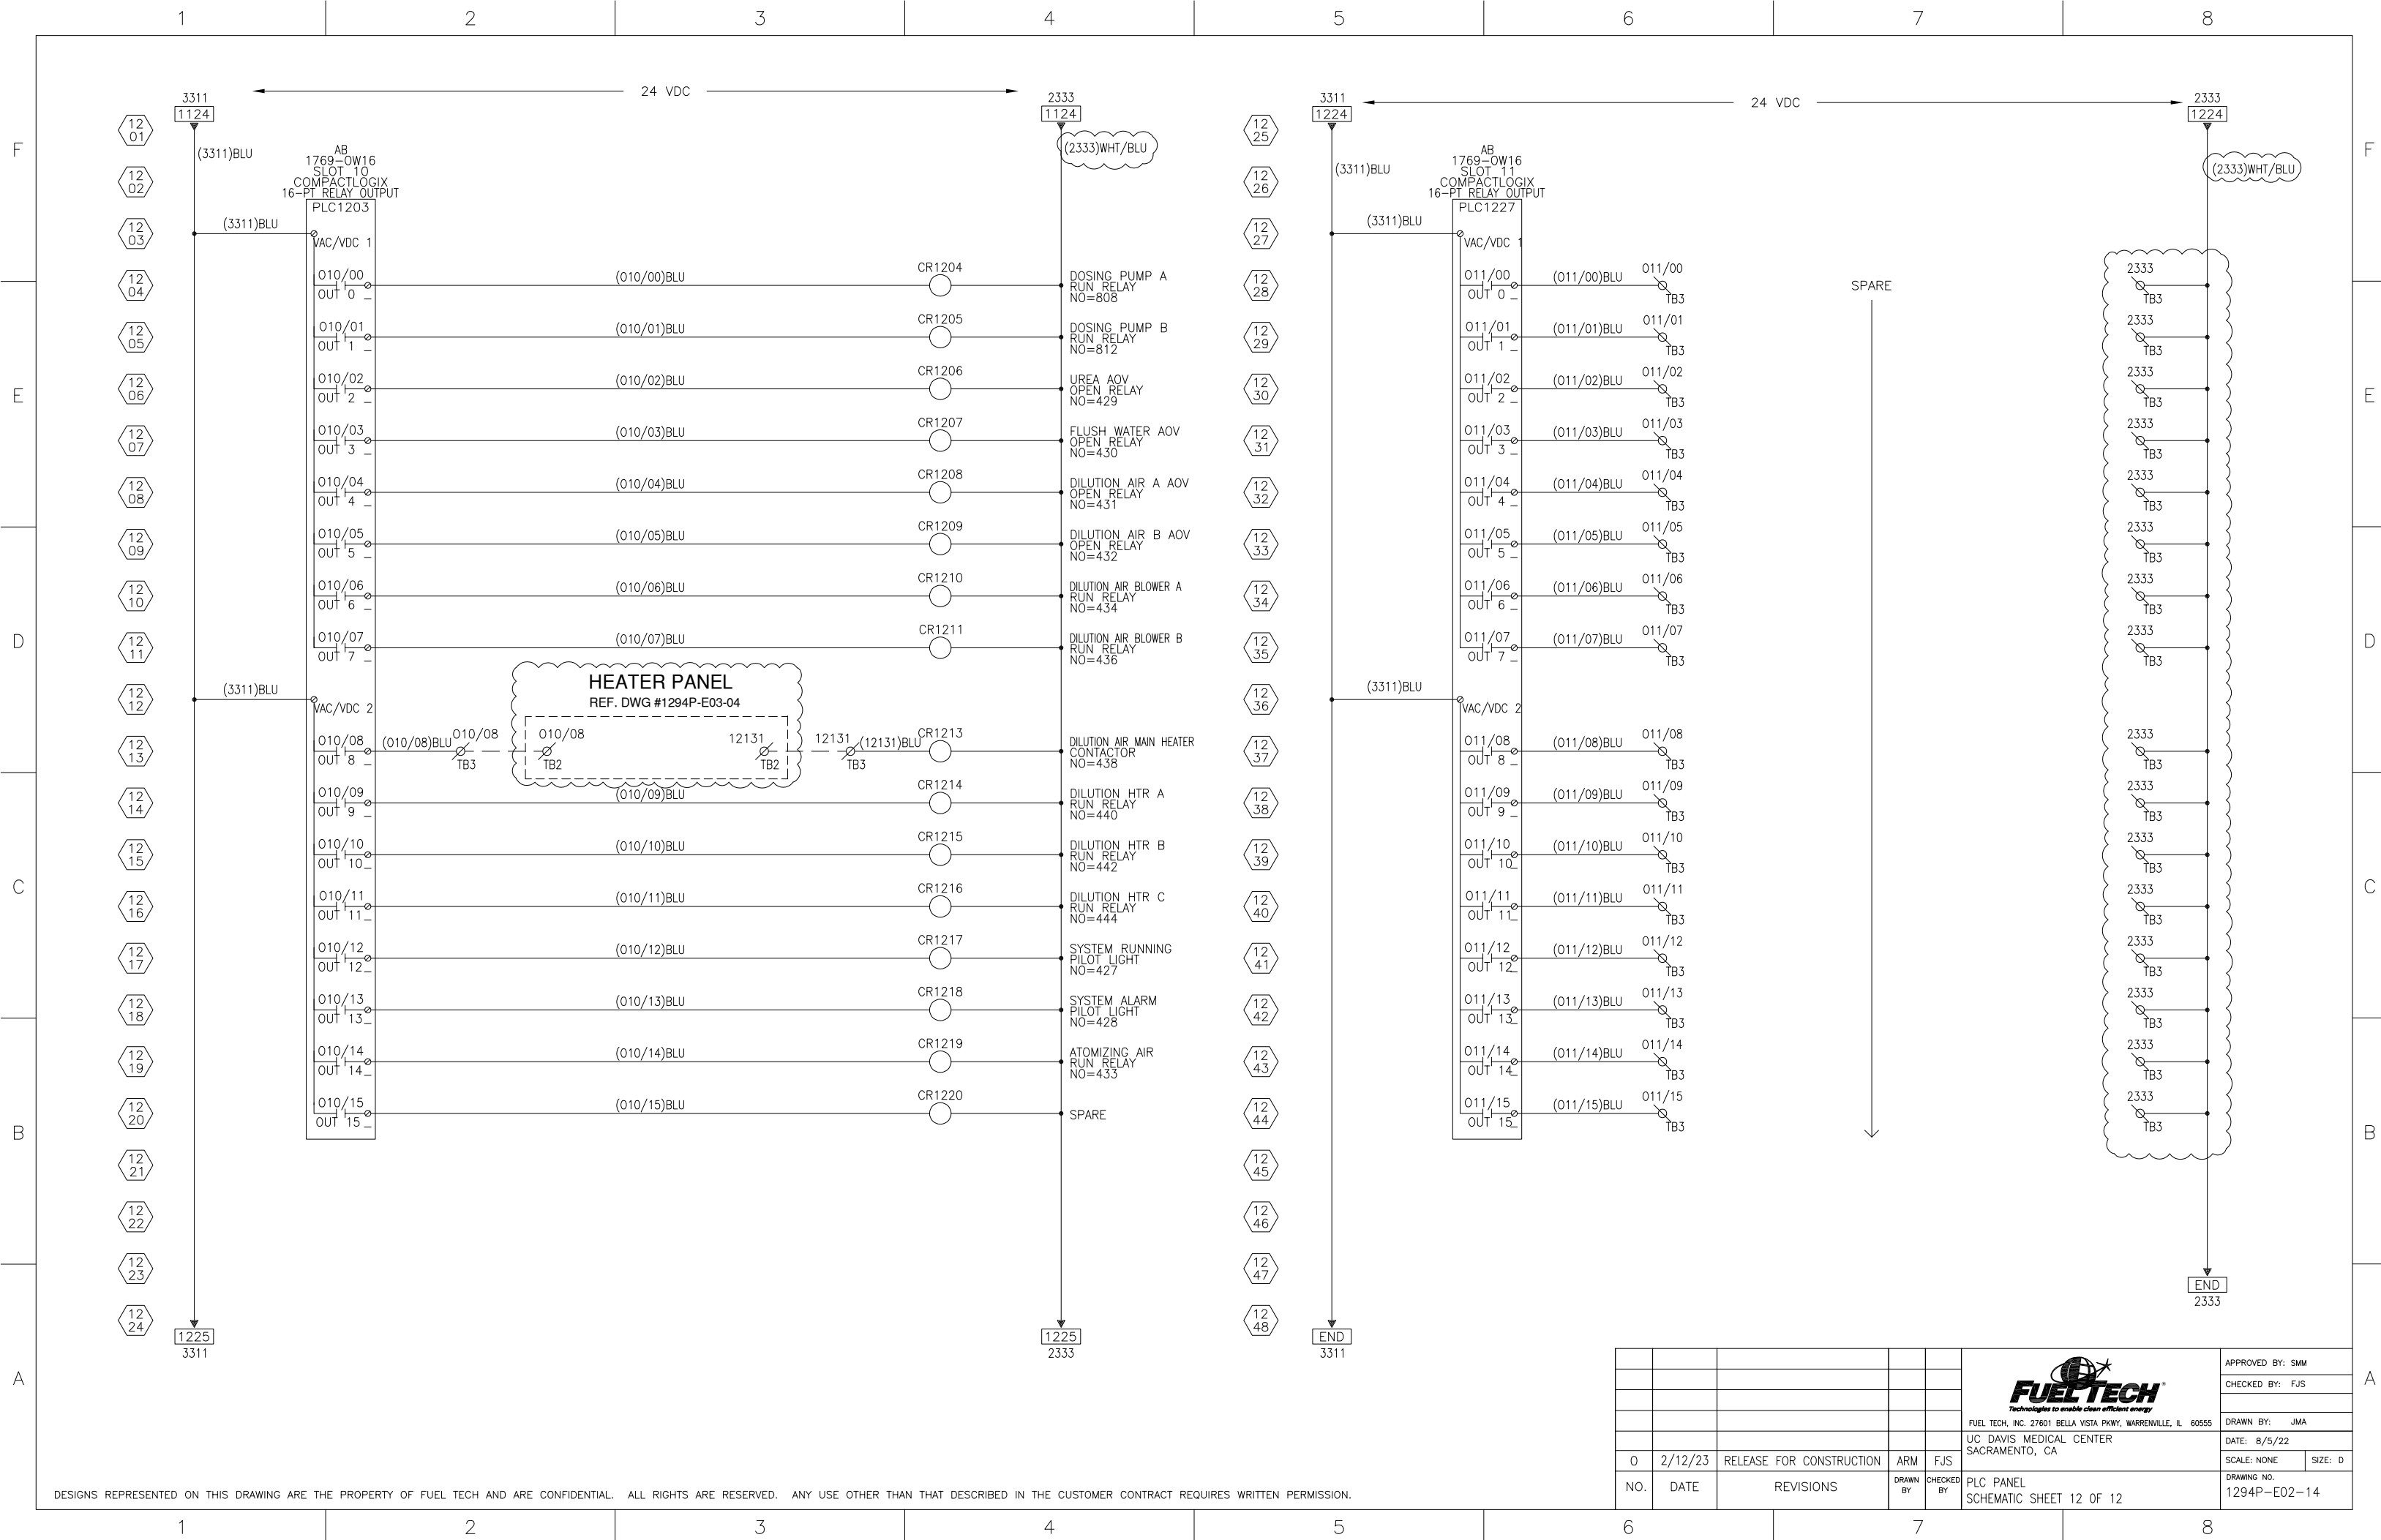

12345678

F

E

D

C

B

A

12345678

INTENTIONALLY BLANK
(FOR FUTURE USE IF NEEDED)

					 FUEL TECH, INC. 27601 BELLA VISTA PKWY, WARRENVILLE, IL 60555 UC DAVIS MEDICAL CENTER SACRAMENTO, CA	APPROVED BY: SMM	
						CHECKED BY: FJS	
						DRAWN BY: JMA	
						DATE: 8/5/22	
0	2/12/23	RELEASE FOR CONSTRUCTION	ARM	FJS		SCALE: NONE	SIZE: D
NO.	DATE	REVISIONS	DRAWN BY	CHECKED BY	PLC PANEL FUTURE		
					DRAWING NO. 1294P-E02-15		

DESIGNS REPRESENTED ON THIS DRAWING ARE THE PROPERTY OF FUEL TECH AND ARE CONFIDENTIAL. ALL RIGHTS ARE RESERVED. ANY USE OTHER THAN THAT DESCRIBED IN THE CUSTOMER CONTRACT REQUIRES WRITTEN PERMISSION.

12345678

F

E

D

C

B

A

12345678

INTENTIONALLY BLANK
(FOR FUTURE USE IF NEEDED)

					 FUEL TECH, INC. 27601 BELLA VISTA PKWY, WARRENVILLE, IL 60555 UC DAVIS MEDICAL CENTER SACRAMENTO, CA	APPROVED BY: SMM	
						CHECKED BY: FJS	
						DRAWN BY: JMA	
						DATE: 8/5/22	
0	2/12/23	RELEASE FOR CONSTRUCTION	ARM	FJS		SCALE: NONE	SIZE: D
NO.	DATE	REVISIONS	DRAWN BY	CHECKED BY	PLC PANEL FUTURE	DRAWING NO. 1294P-E02-16	

DESIGNS REPRESENTED ON THIS DRAWING ARE THE PROPERTY OF FUEL TECH AND ARE CONFIDENTIAL. ALL RIGHTS ARE RESERVED. ANY USE OTHER THAN THAT DESCRIBED IN THE CUSTOMER CONTRACT REQUIRES WRITTEN PERMISSION.

F

E

D


C


B

A


--	--	

DESIGNS REPRESENTED ON THIS DRAWING ARE THE PROPERTY OF FUEL TECH AND ARE CONFIDENTIAL. ALL RIGHTS ARE RESERVED. ANY USE OTHER THAN THAT DESCRIBED IN THE CUSTOMER CONTRACT REQUIRES WRITTEN PERMISSION.

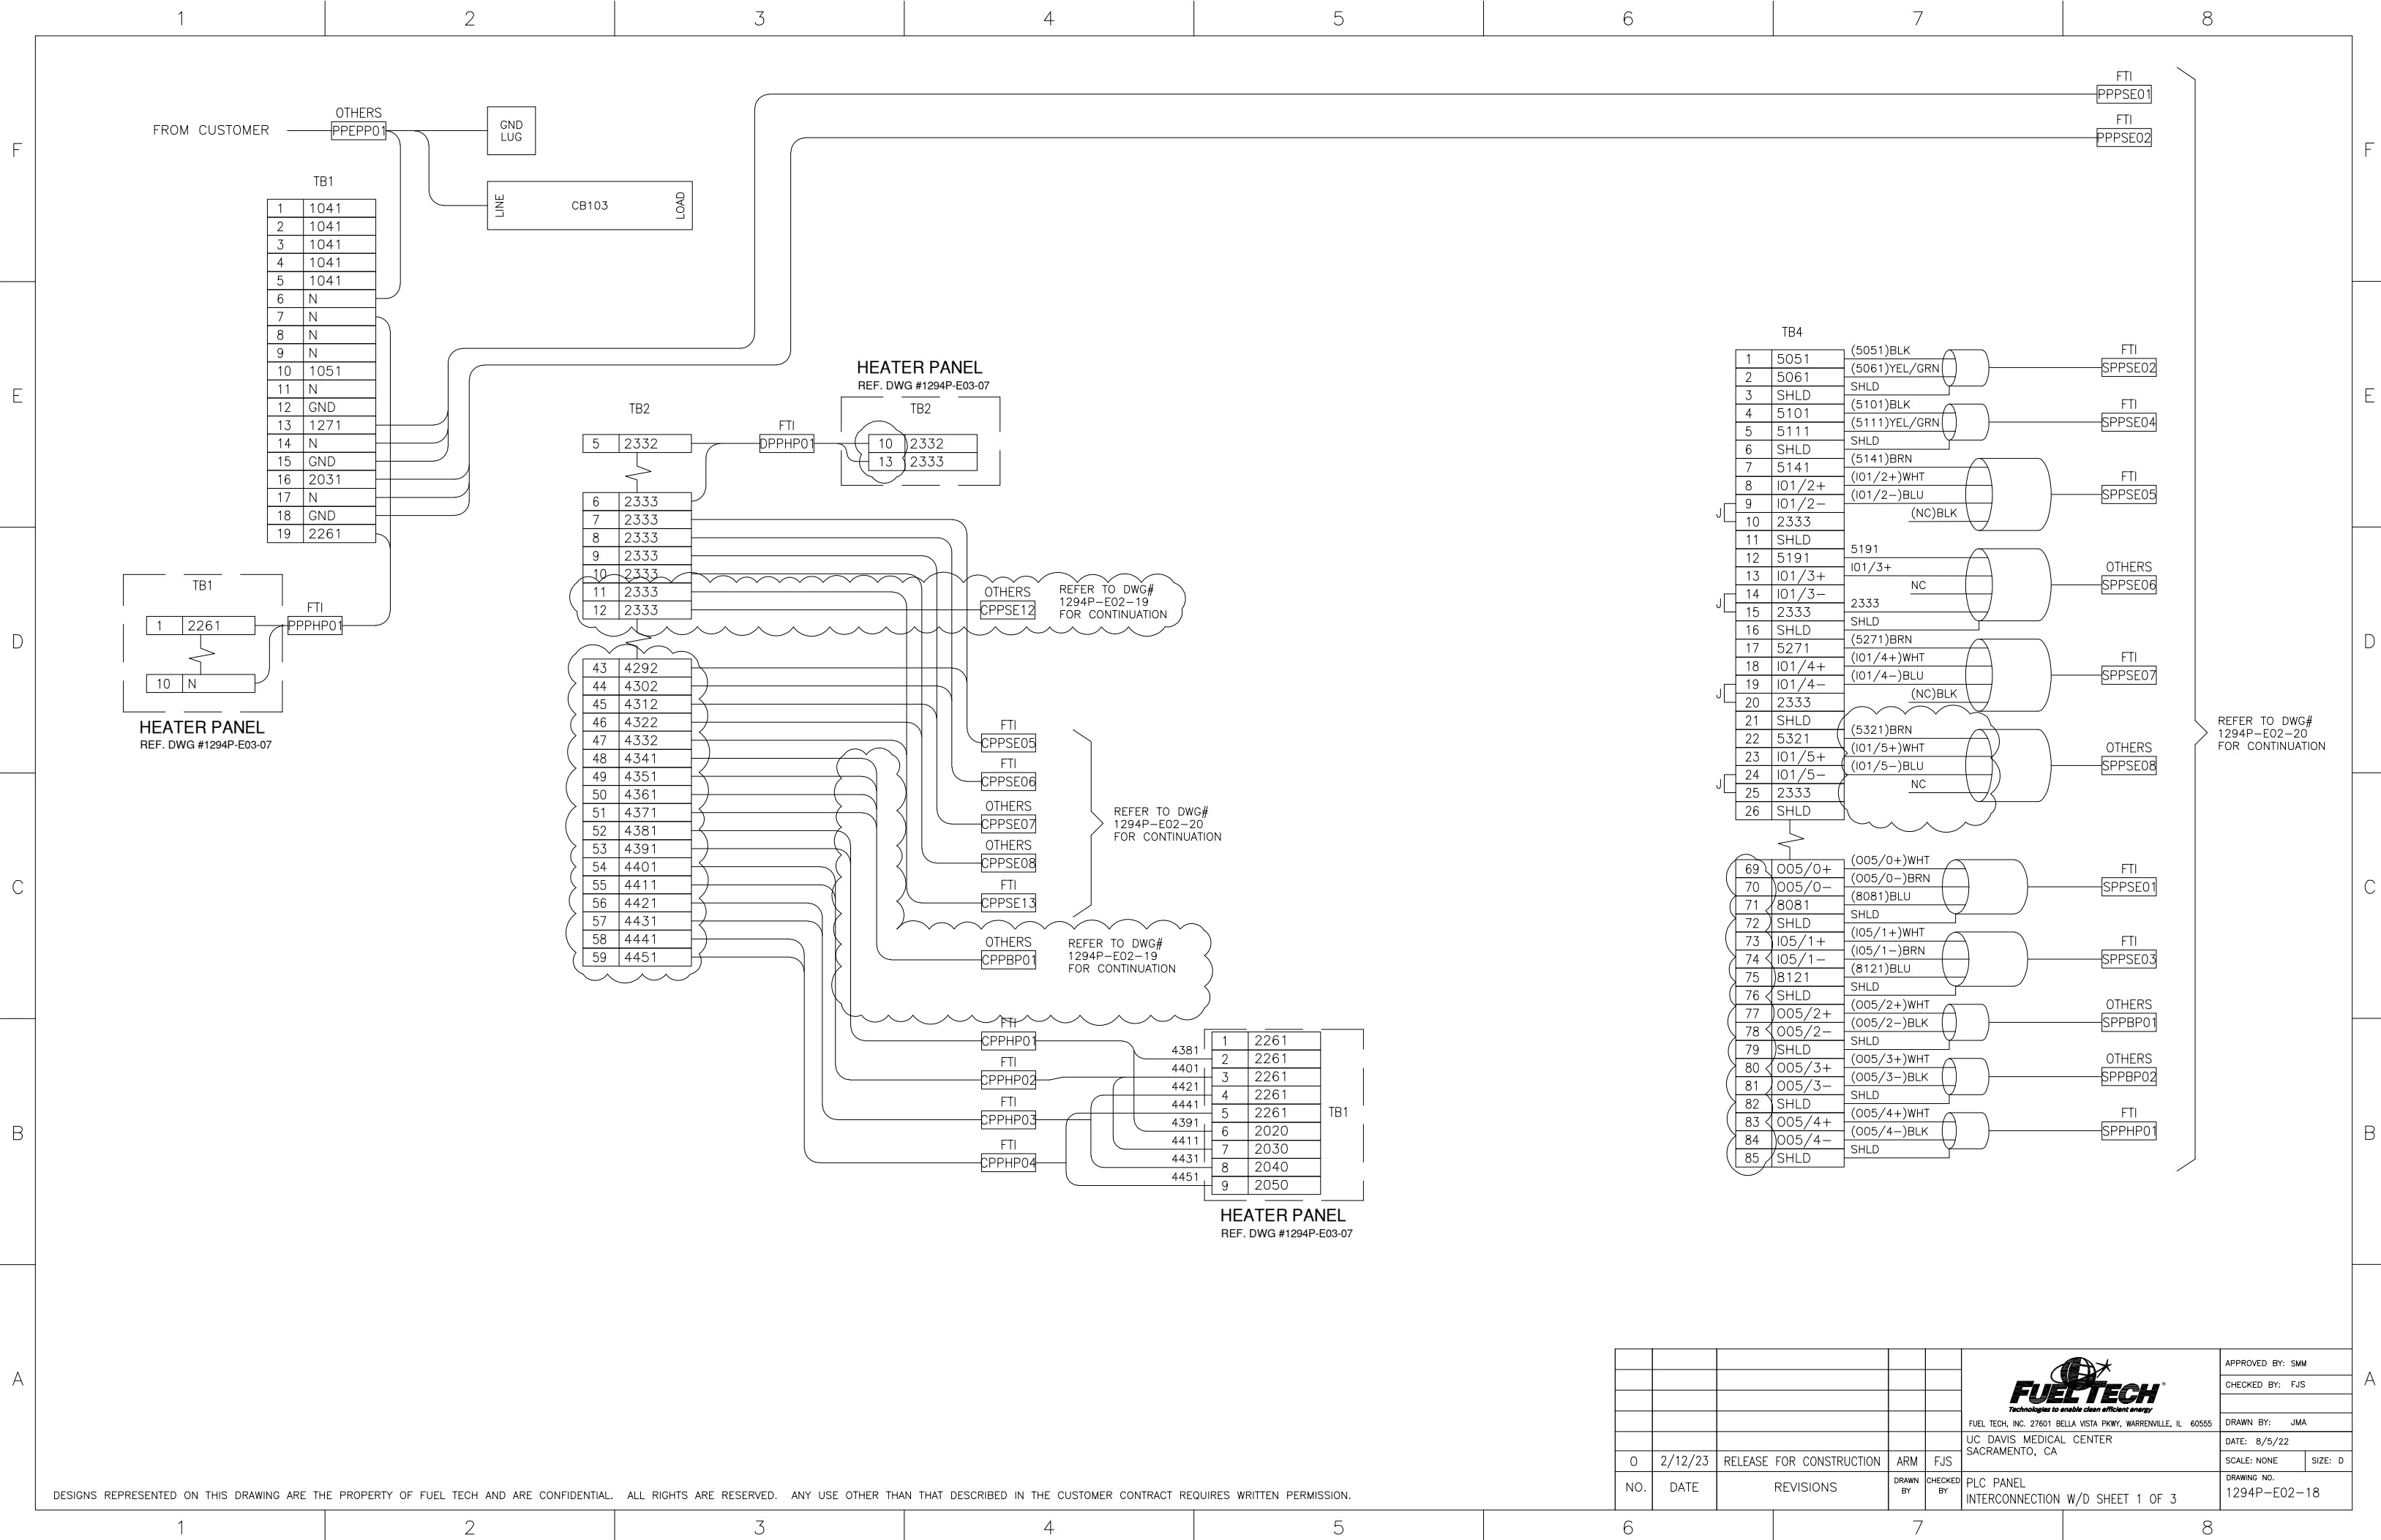

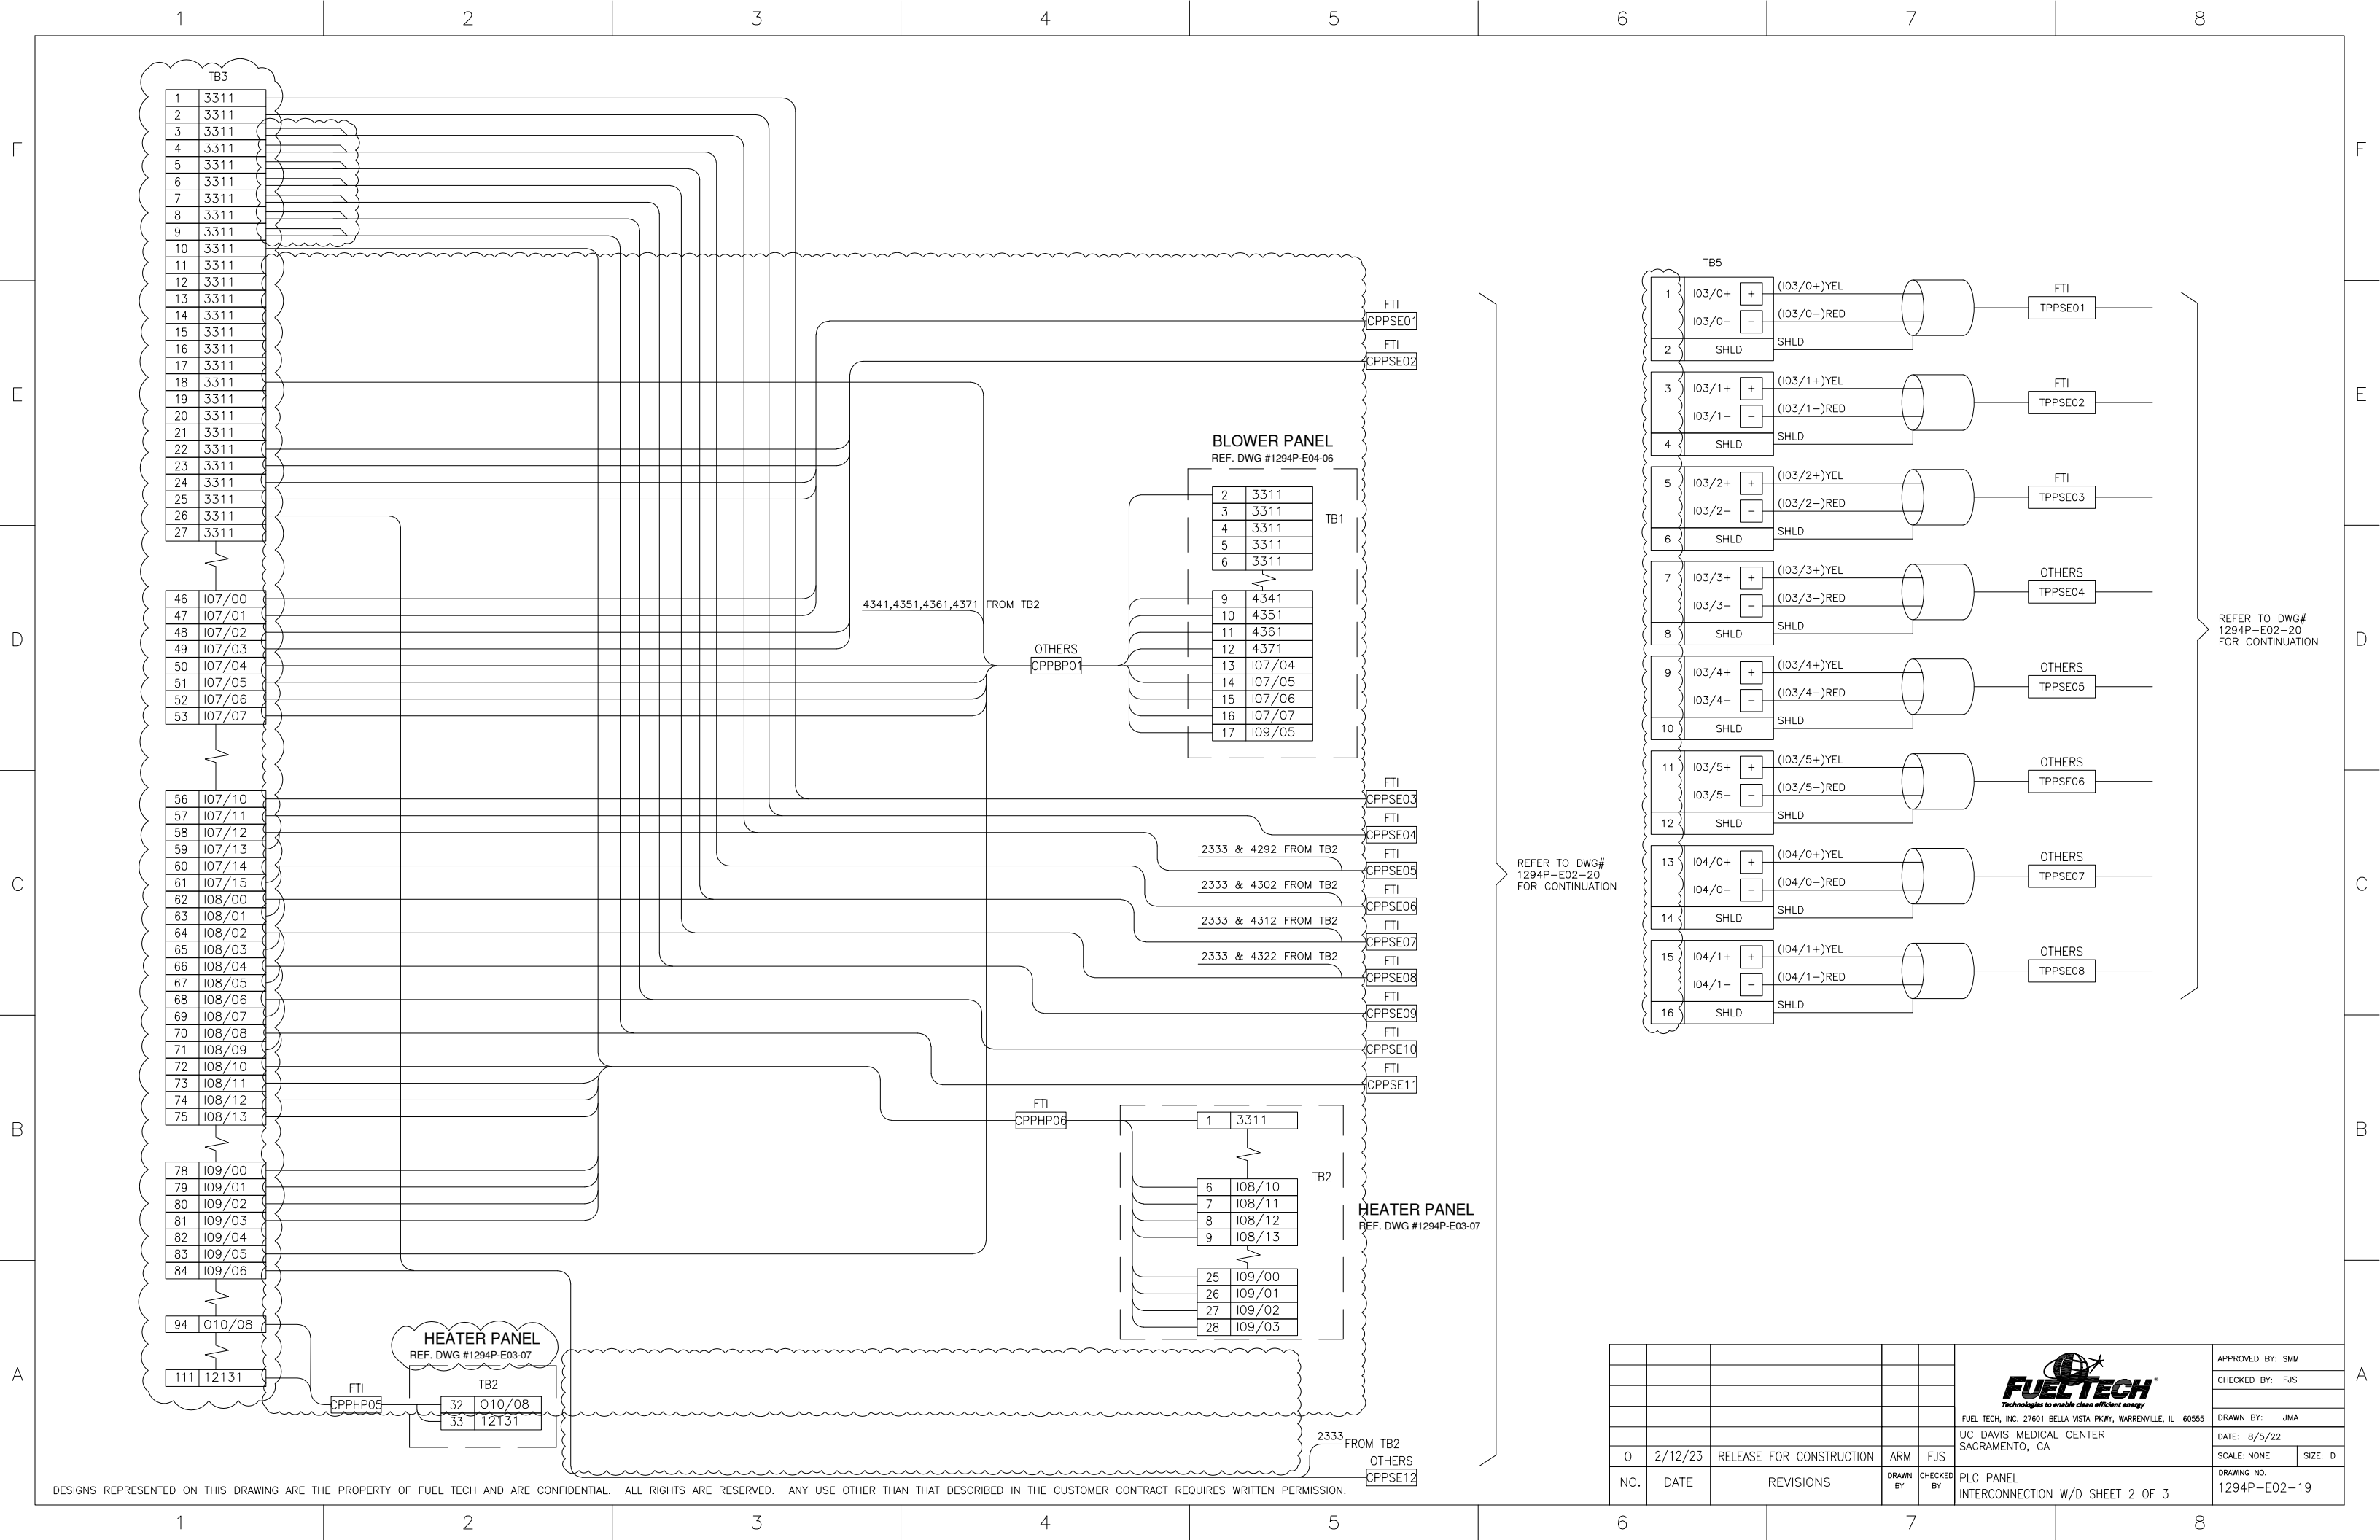

1	2	3	4	5	6	7	8	
INTERCONNECT CABLE/WIRE LIST								
CABLE NO.	NO. COND.	WIRE SIZE	FROM LOCATION	DEVICE	TO LOCATION	DEVICE	WIRE NUMBERS	CABLING BY
PPEPP01	2 + 1	CLIENT-DEFINED	CLIENT	120VAC,1PH,60HZ SOURCE	PLC PANEL	CB103, TB1, GND	L N GND	OTHERS
PPPHP01	2 WIRE CABLE	#14 AWG 600V 90C MIN	PLC PANEL	TB1	HEATER PANEL	TB1	2261 N	FTI
DPPHP01	2 WIRE CABLE	#14 AWG 600V 90C MIN	PLC PANEL	TB2	HEATER PANEL	TB2	2332 2333	FTI
PPPSE01	2 + 1	#14 AWG 600V 90C MIN + #14 AWG GND	PLC PANEL	TB1	P-UE-2230 A	UREA DOSING PUMP A	1271 N GND	FTI
PPPSE02	2 + 1	#14 AWG 600V 90C MIN + #14 AWG GND	PLC PANEL	TB1	P-UE-2230 B	UREA DOSING PUMP B	2031 N GND	FTI
SPPHP01	2 WIRE CABLE	#16 AWG SIGNAL SHIELDED	PLC PANEL	TB4	HEATER PANEL	TB2	005/4+ 005/4- SHLD	FTI
SPPBP01	2 WIRE CABLE	#16 AWG SIGNAL SHIELDED	PLC PANEL	TB4	BLOWER PANEL	TB1	005/2+ 005/2- SHLD	OTHERS
SPPBP02	2 WIRE CABLE	#16 AWG SIGNAL SHIELDED	PLC PANEL	TB4	BLOWER PANEL	TB1	005/3+ 005/3- SHLD	OTHERS
SPPSE01	4 WIRE CABLE	#16 AWG SIGNAL SHIELDED	PLC PANEL	TB4	P-UE-2230 A	UREA DOSING PUMP A	005/0- 005/0+ 8081 SHLD	FTI
SPPSE02	5 WIRE CABLE	#16 AWG SIGNAL SHIELDED	PLC PANEL	TB4	P-UE-2230 A	UREA DOSING PUMP A	5051 5061 SHLD	FTI
SPPSE03	4 WIRE CABLE	#16 AWG SIGNAL SHIELDED	PLC PANEL	TB4	P-UE-2230 B	UREA DOSING PUMP B	005/1- 005/1+ 8121 SHLD	FTI
SPPSE04	5 WIRE CABLE	#16 AWG SIGNAL SHIELDED	PLC PANEL	TB4	P-UE-2230 B	UREA DOSING PUMP B	5101 5111 SHLD	FTI
SPPSE05	4 WIRE CABLE	#16 AWG SIGNAL SHIELDED	PLC PANEL	TB4	FIT-IA-2244	ATOMIZING AIR FLOW TRANSMITTER	5141 I01/2+ I01/2- NC	FTI
SPPSE06	3 WIRE CABLE	#16 AWG SIGNAL SHIELDED	PLC PANEL	TB4	FIT-DA-2253	DILUTION AIR FLOW RATE TRANSMITTER	5191 I01/3+ 2333 SHLD	OTHERS
SPPSE07	4 WIRE CABLE	#16 AWG SIGNAL SHIELDED	PLC PANEL	TB4	PIT-DA-2208	DILUTION AIR PRESSURE TRANSMITTER	5271 I01/4+ I01/4- NC	FTI
SPPSE08	4 WIRE CABLE	#16 AWG SIGNAL SHIELDED	PLC PANEL	TB4	UT-UE-1910	UREA TANK LEVEL TRANSMITTER	5321 I01/5+ I01/5- NC	OTHERS
CPPSE01	4 WIRE CABLE	#16 AWG 600V 90C MIN	PLC PANEL	TB3	P-UE-2230 A	UREA DOSING PUMP A	I07/00 3311 I07/01 3311	FTI
CPPSE02	4 WIRE CABLE	#16 AWG 600V 90C MIN	PLC PANEL	TB3	P-UE-2230 B	UREA DOSING PUMP B	I07/02 3311 I07/03 3311	FTI
CPPSE03	2 WIRE CABLE	#14 AWG 600V 90C MIN	PLC PANEL	TB3	PDS-UE-2231A	UREA FILTER DP SWITCH A	I07/10 3311	FTI
CPPSE04	2 WIRE CABLE	#14 AWG 600V 90C MIN	PLC PANEL	TB3	PDS-UE-2231B	UREA FILTER DP SWITCH B	I07/11 3311	FTI
CPPSE05	7 WIRE CABLE	#14 AWG 600V 90C MIN	PLC PANEL	TB2 & TB3, GND	AOV-UE-2217	UREA SUPPLY VALVE	4292 2333 I07/12 3311 I07/13 GND	FTI
CPPSE06	7 WIRE CABLE	#14 AWG 600V 90C MIN	PLC PANEL	TB2 & TB3, GND	AOV-FW-2223	FLUSH WATER VALVE	4302 2333 I07/14 3311 I07/15 GND	FTI
CPPSE07	7 WIRE CABLE	#14 AWG 600V 90C MIN	PLC PANEL	TB2 & TB3, GND	AOV-DA-2209A	DILUTION AIR A VALVE	4312 2333 I08/00 3311 I08/01 GND	OTHERS
CPPSE08	7 WIRE CABLE	#14 AWG 600V 90C MIN	PLC PANEL	TB2 & TB3, GND	AOV-DA-2209B	DILUTION AIR B VALVE	4322 2333 I08/02 3311 I08/03 GND	OTHERS
CPPSE09	4 WIRE CABLE	#14 AWG 600V 90C MIN	PLC PANEL	TB3	HV-DA-2211A	DILUTION AIR HEATER A HAND VALVE	I08/04 3311 I08/05	FTI
CPPSE10	4 WIRE CABLE	#14 AWG 600V 90C MIN	PLC PANEL	TB3	HV-DA-2211B	DILUTION AIR HEATER B HAND VALVE	I08/06 3311 I08/07	FTI
CPPSE11	4 WIRE CABLE	#14 AWG 600V 90C MIN	PLC PANEL	TB3	HV-DA-2211C	DILUTION AIR HEATER C HAND VALVE	I08/08 3311 I08/09	FTI
CPPSE12	4 WIRE CABLE	#14 AWG 600V 90C MIN	PLC PANEL	TB2 & TB3	LSH-UE-1912	UREA TANK HIGH LEVEL SWITCH	3311 I09/06 2333 NC	OTHERS
CPPSE13	3 WIRE CABLE	#14 AWG 600V 90C MIN	PLC PANEL	TB2	SOV-IA-2240	ATOMIZING AIR VALVE	4332 2333 GND	FTI
CPPHP01	2 WIRE CABLE	#14 AWG 600V 90C MIN	PLC PANEL	TB2	HEATER PANEL	TB1	4381 4391	FTI
CPPHP02	2 WIRE CABLE	#14 AWG 600V 90C MIN	PLC PANEL	TB2	HEATER PANEL	TB1	4401 4411	FTI
CPPHP03	2 WIRE CABLE	#14 AWG 600V 90C MIN	PLC PANEL	TB2	HEATER PANEL	TB1	4421 4431	FTI
CPPHP04	2 WIRE CABLE	#14 AWG 600V 90C MIN	PLC PANEL	TB2	HEATER PANEL	TB1	4441 4451	FTI
CPPHP05	2 WIRE CABLE	#14 AWG 600V 90C MIN	PLC PANEL	TB3	HEATER PANEL	TB2	I01/08 12131	FTI
CPPHP06	9 WIRE CABLE	#14 AWG 600V 90C MIN	PLC PANEL	TB3	HEATER PANEL	TB2	I08/10 3311 I08/11 I08/12 I08/13 I09/00 I09/01 I09/02 I09/03	FTI
CPPBP01	10 WIRE CABLE	#14 AWG 600V 90C MIN	PLC PANEL	TB2 & TB3	BLOWER PANEL	TB1	I07/04 3311 I07/05 I07/06 I07/07 I09/05 4341 4351 4361 4371	OTHERS
TPPSE01	1 PR 20AWG SHLD CABLE	TYPE KX THERMOCOUPLE WIRE 20 AWG MIN	PLC PANEL	TB5	TE-DA-2255A	DILUTION AIR HEATER A OUTLET TEMP	I03/0+ I03/0- SHLD	FTI
TPPSE02	1 PR 20AWG SHLD CABLE	TYPE KX THERMOCOUPLE WIRE 20 AWG MIN	PLC PANEL	TB5	TE-DA-2255B	DILUTION AIR HEATER B OUTLET TEMP	I03/1+ I03/1- SHLD	FTI
TPPSE03	1 PR 20AWG SHLD CABLE	TYPE KX THERMOCOUPLE WIRE 20 AWG MIN	PLC PANEL	TB5	TE-DA-2255C	DILUTION AIR HEATER B OUTLET TEMP	I03/2+ I03/2- SHLD	FTI
TPPSE04	1 PR 20AWG SHLD CABLE	TYPE KX THERMOCOUPLE WIRE 20 AWG MIN	PLC PANEL	TB5	TE-DAG-2250	DECOMP CHAMBER INLET TEMP	I03/3+ I03/3- SHLD	OTHERS
TPPSE05	1 PR 20AWG SHLD CABLE	TYPE KX THERMOCOUPLE WIRE 20 AWG MIN	PLC PANEL	TB5	TE-DAG-2245	DECOMP CHAMBER SURFACE TEMP	I03/4+ I03/4- SHLD	OTHERS
TPPSE06	1 PR 20AWG SHLD CABLE	TYPE KX THERMOCOUPLE WIRE 20 AWG MIN	PLC PANEL	TB5	TE-DAG-2246	DECOMP CHAMBER OUTLET TEMP	I03/5+ I03/5- SHLD	OTHERS
TPPSE07	1 PR 20AWG SHLD CABLE	TYPE KX THERMOCOUPLE WIRE 20 AWG MIN	PLC PANEL	TB5		AIG SURFACE TEMP	I04/0+ I04/0- SHLD	OTHERS
TPPSE08	1 PR 20AWG SHLD CABLE	TYPE KX THERMOCOUPLE WIRE 20 AWG MIN	PLC PANEL	TB5	TE-UE-1911	UREA STORAGE TANK TEMP	I04/1+ I04/1- SHLD	OTHERS
								</

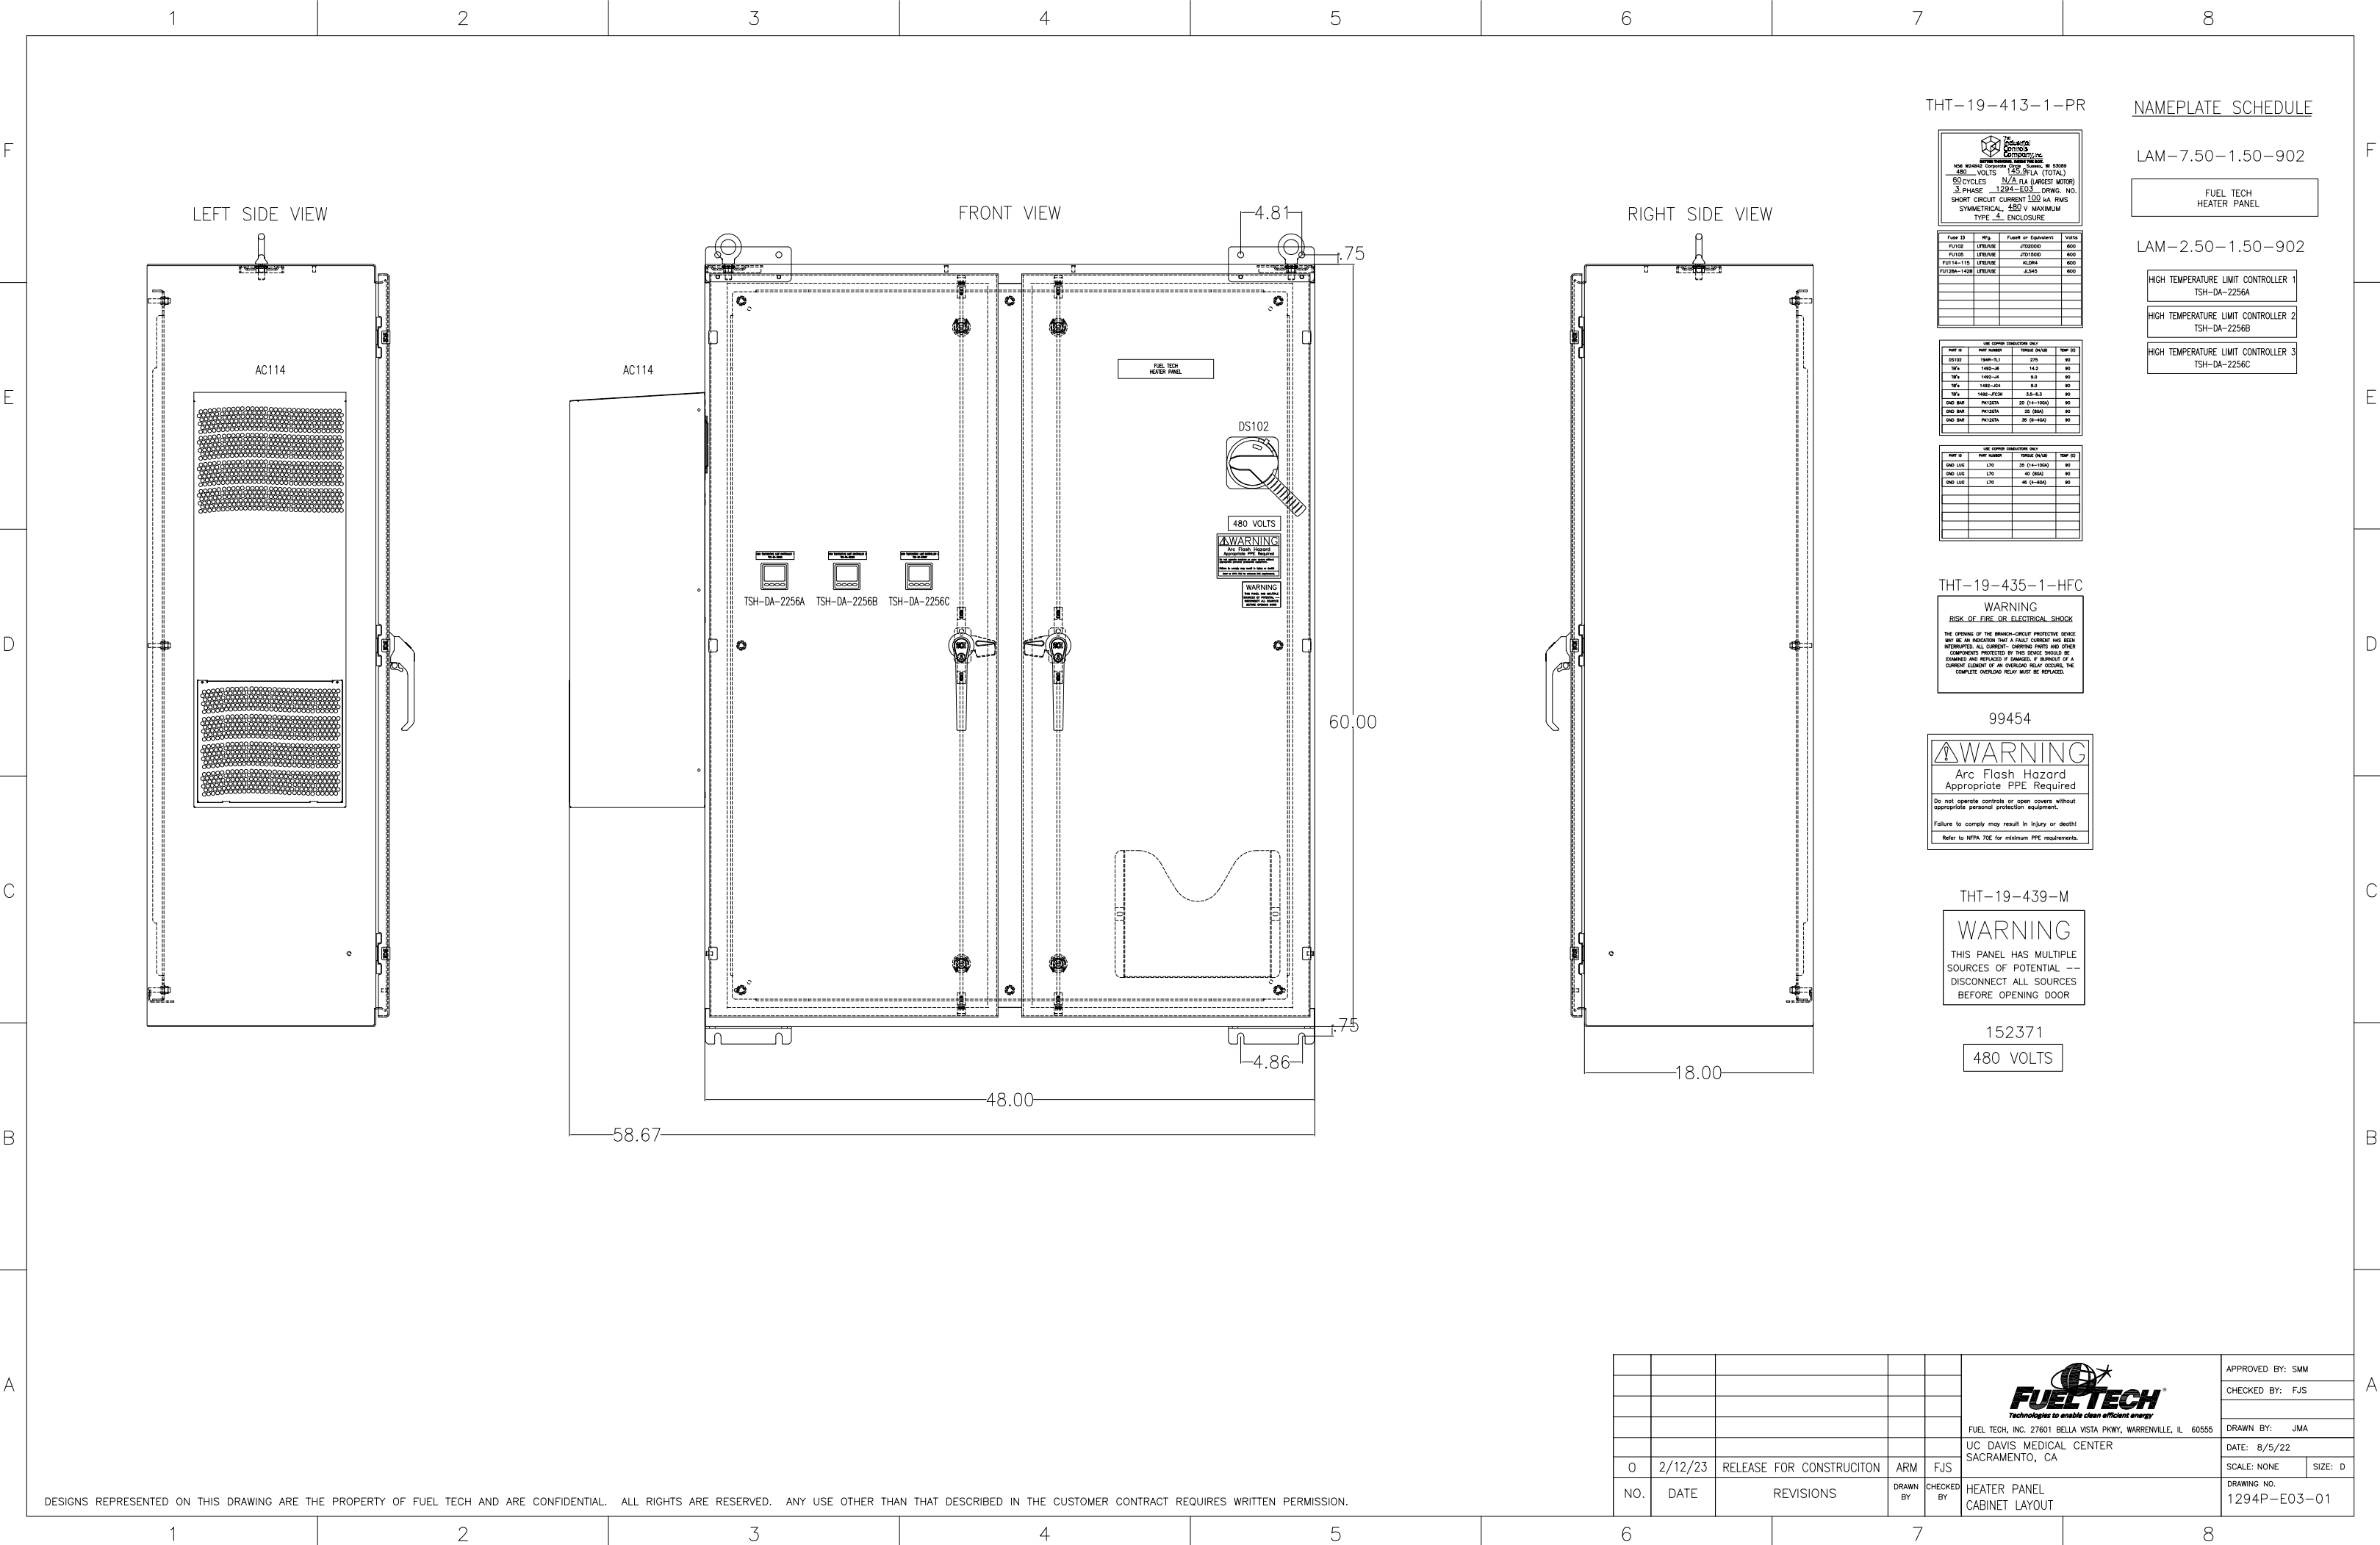

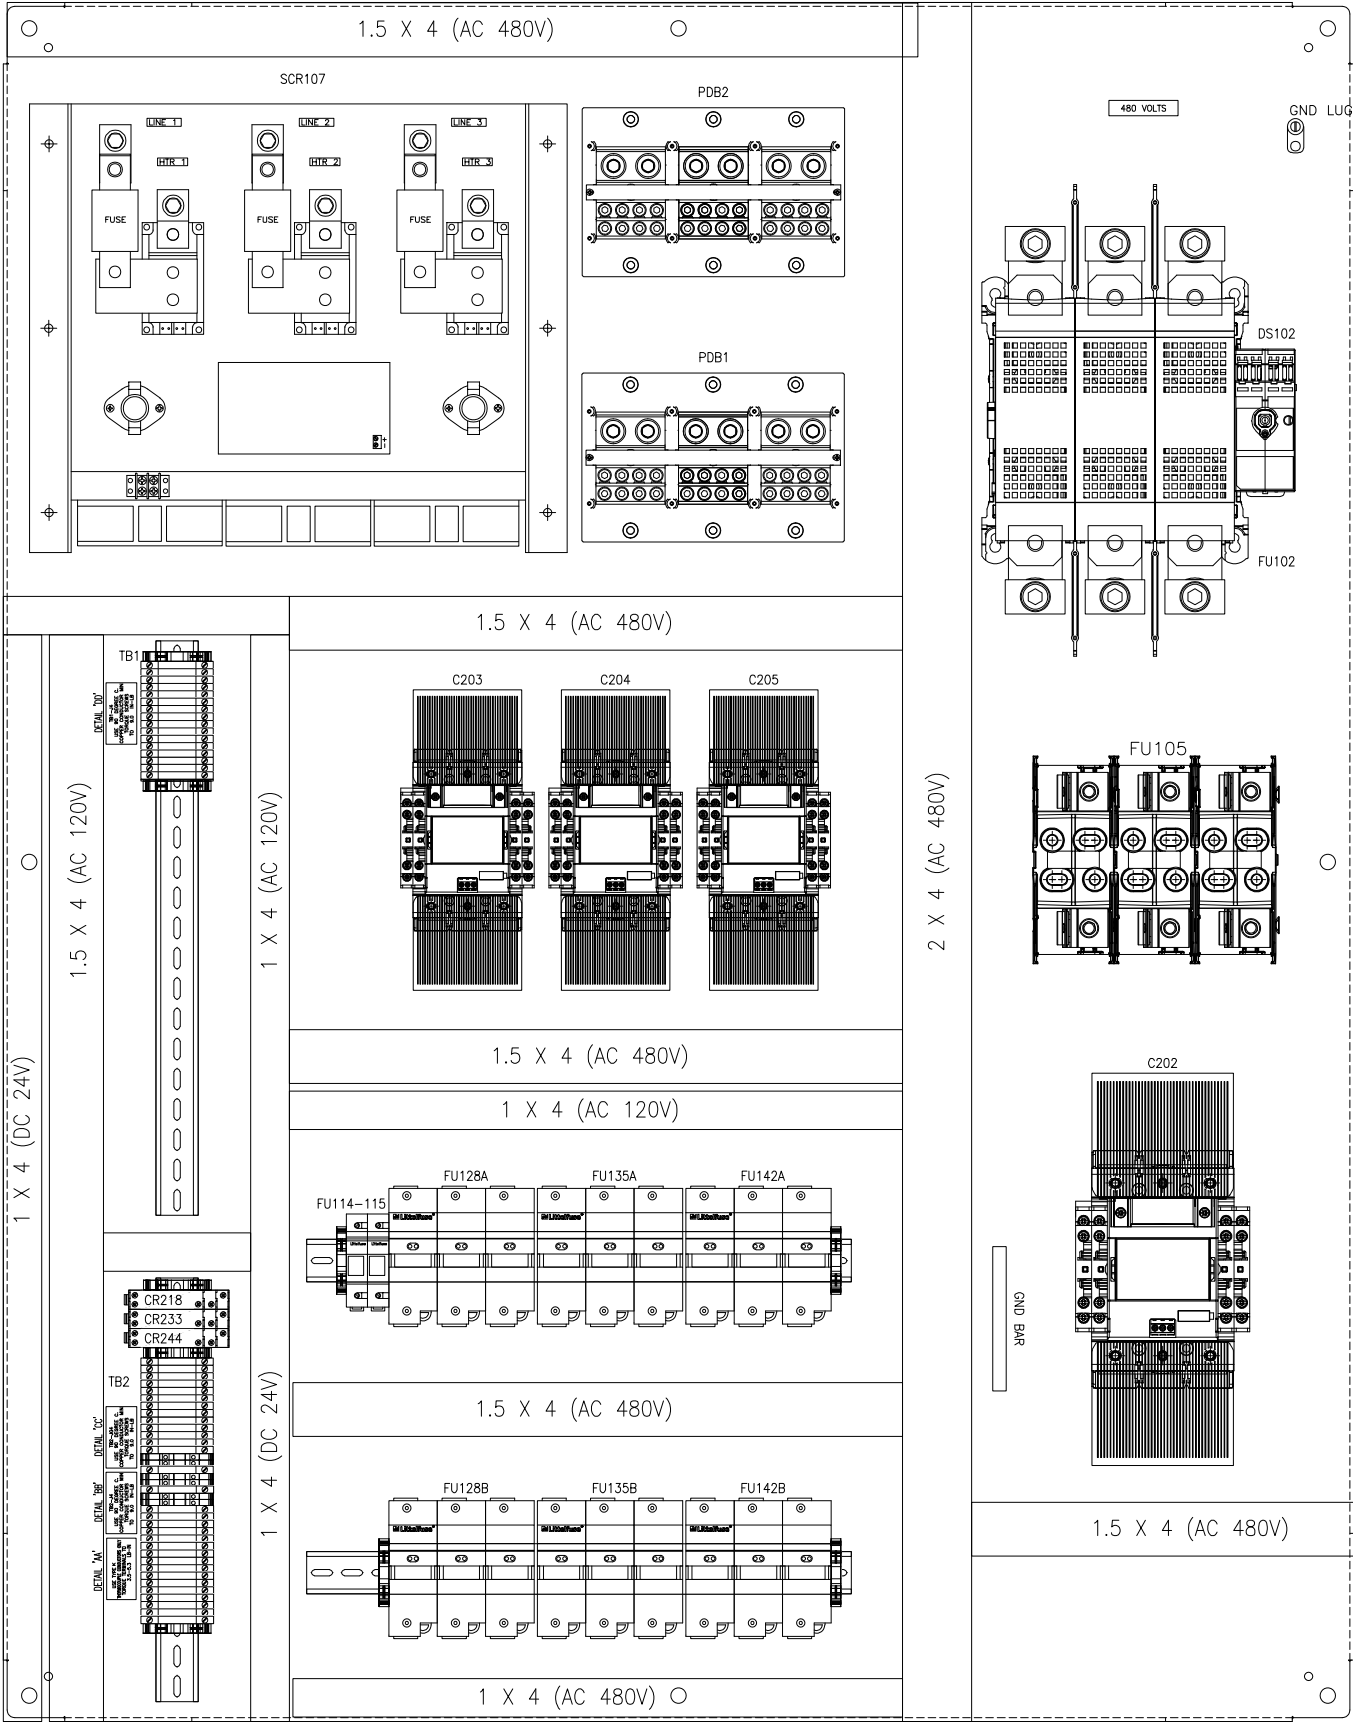

120VAC		
TB1		
1	2261	
2	2261	
3	2261	
4	2261	
5	2261	
6	2020	
7	2030	
8	2040	
9	2050	
10	N	
11	N	
12	N	
13	N	
14	N	
15	SPARE	
16	SPARE	
17	SPARE	
17 @ 1492-J4		

24VDC		
TB2		
1	3311	
2	3311	
3	3311	
4	3311	
5	3311	
6	I08/10	
7	I08/11	
8	I08/12	
9	I08/13	
10	2332	
11	2332	
12	2332	
13	2333	
14	2333	
15	2333	
16	2160	*
	2170	*
17	SHLD	**
18	2290	*
	2300	*
19	SHLD	**
20	2400	*
	2410	*
21	SHLD	**
22	3311	
23	3311	
24	3311	
25	I09/00	
26	I09/01	
27	I09/02	
28	I09/03	
29	O05/4+	
30	O05/4-	
31	SHLD	**
32	O10/08	
33	12131	
34	SPARE	
35	SPARE	
36	SPARE	
37	SPARE	
30 @ 1492-J4		
*3 @ 1492-JTC3K		
**4 @ 1492-JG4		

44315

480 VOLTS

THT-17-413-3-PR


DETAIL 'AA'
USE TYPE K
THERMOCOUPLE CONDUCTORS ONLY
TORQUE TERMINALS TO
3.5-5.3 LB-IN


DETAIL 'BB'
TB2-J4
USE 90 DEGREE C.
COPPER CONDUCTOR MIN
TORQUE SCREWS
TO 9.0 IN-LB

DETAIL 'CC'
TB2-JG4
USE 90 DEGREE C.
COPPER CONDUCTOR MIN
TORQUE SCREWS
TO 9.0 IN-LB

DETAIL 'DD'
TB1-J4
USE 90 DEGREE C.
COPPER CONDUCTOR MIN
TORQUE SCREWS
TO 9.0 IN-LB

						 FUEL TECH, INC. 27601 BELLA VISTA PKWY, WARRENVILLE, IL 60555 UC DAVIS MEDICAL CENTER SACRAMENTO, CA	APPROVED BY: SMM	
							CHECKED BY: FJS	
							DRAWN BY: JMA	
							DATE: 8/5/22	
0	2/12/23	RELEASE FOR CONSTRUCTION	ARM	FJS			SCALE: NONE	SIZE: D
NO.	DATE	REVISIONS	DRAWN BY	CHECKED BY	HEATER PANEL PANEL LAYOUT		DRAWING NO. 1294P-E03-02	

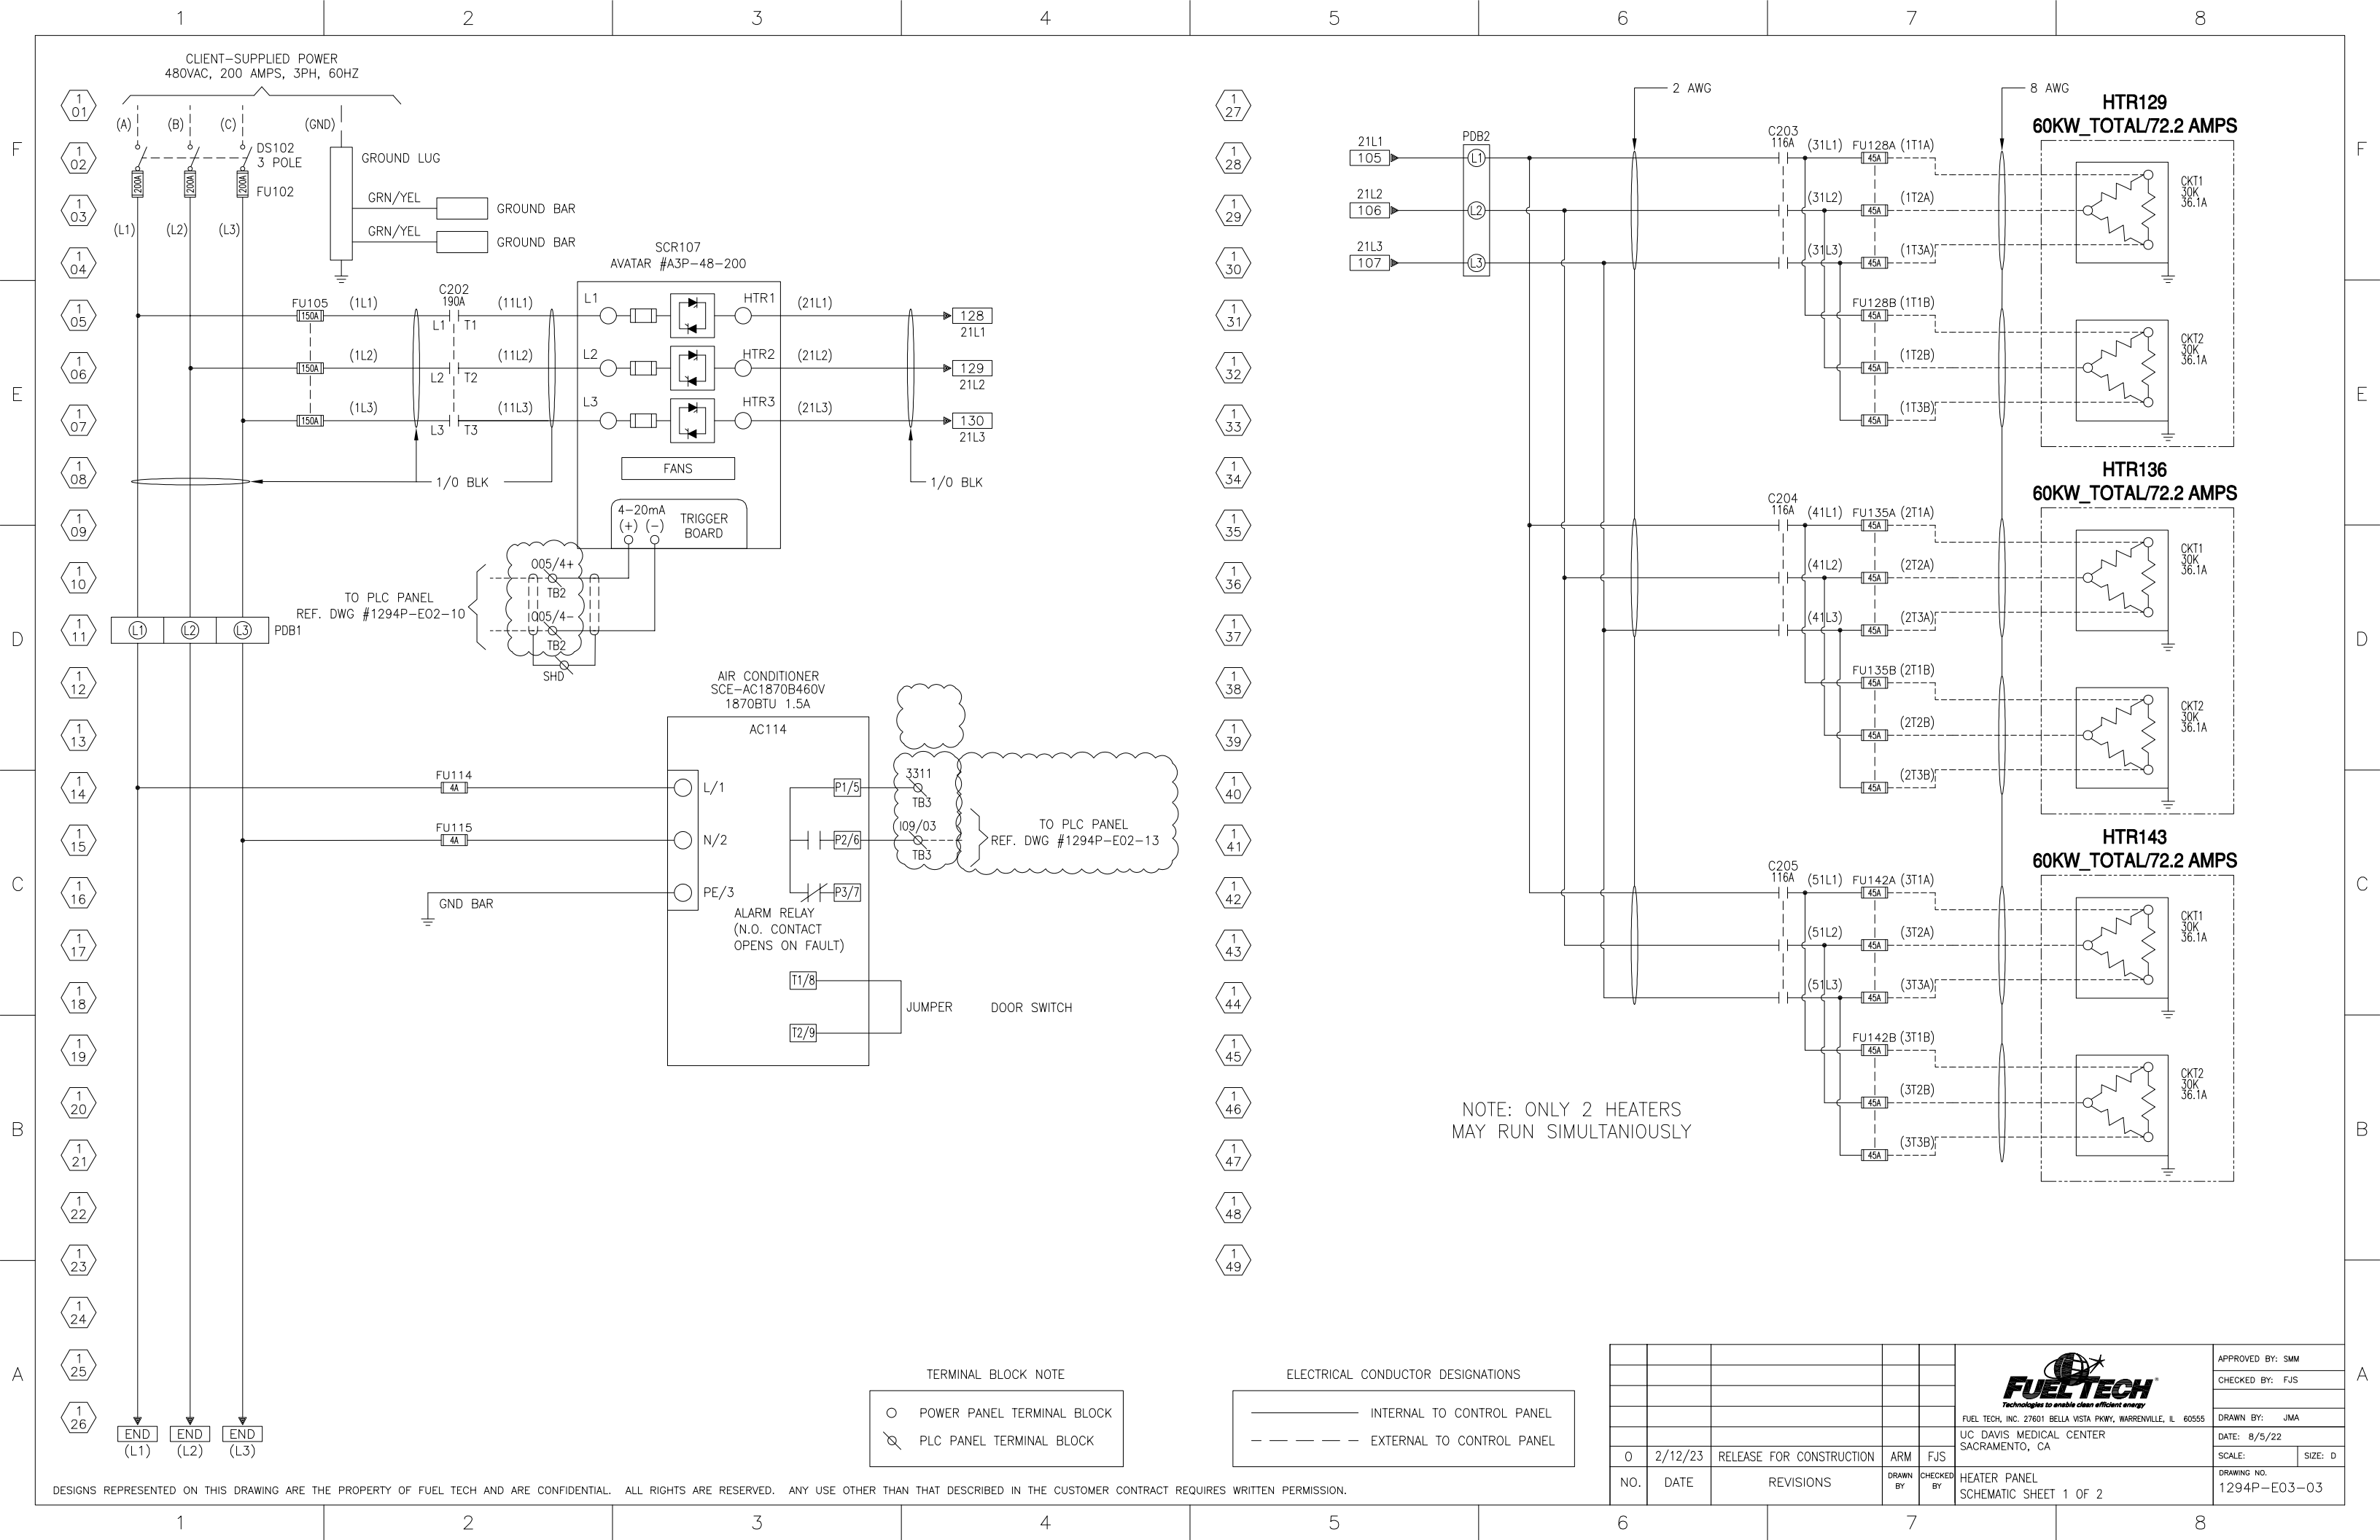

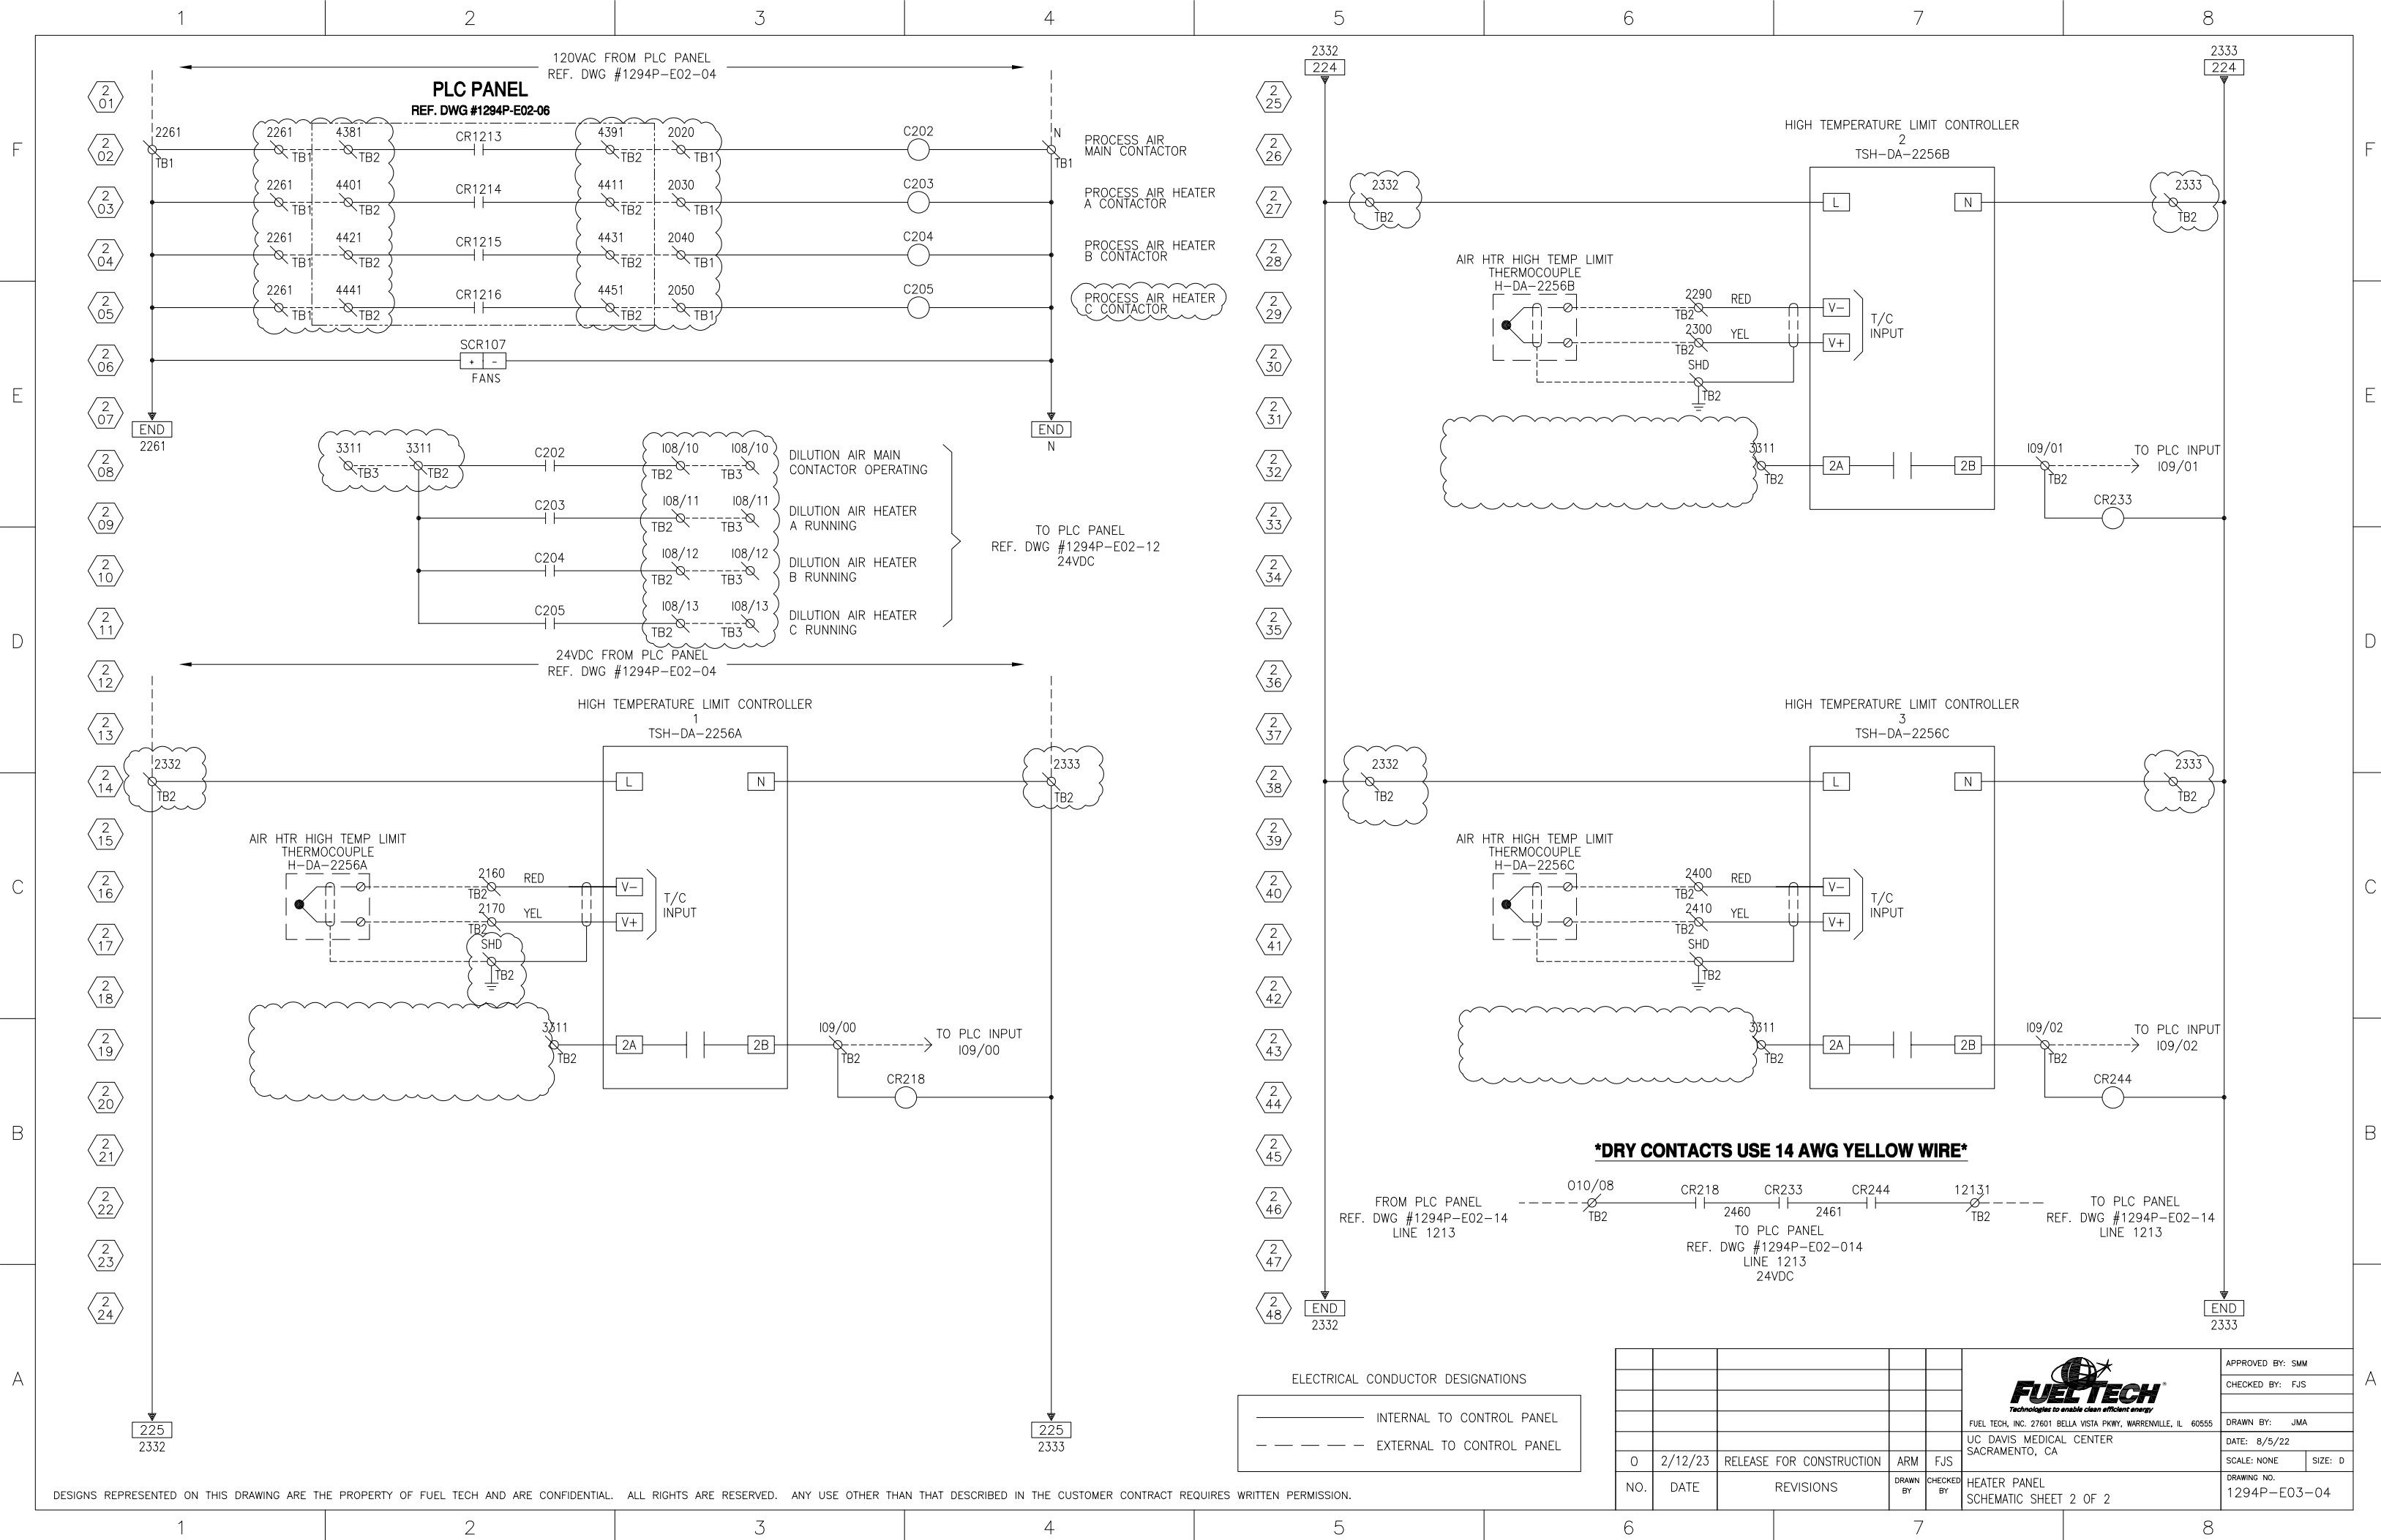

12345678

F

E

D

C

B


A

12345678


INTENTIONALLY BLANK
(FOR FUTURE USE IF NEEDED)

					 FUEL TECH, INC. 27601 BELLA VISTA PKWY, WARRENVILLE, IL 60555 UC DAVIS MEDICAL CENTER SACRAMENTO, CA	APPROVED BY: SMM	
						CHECKED BY: FJS	
						DRAWN BY: JMA	
						DATE: 8/5/22	
0	2/12/23	RELEASE FOR CONSTRUCTION	ARM	FJS		SCALE: NONE	SIZE: D
NO.	DATE	REVISIONS	DRAWN BY	CHECKED BY	HEATER PANEL FUTURE		


DESIGNS REPRESENTED ON THIS DRAWING ARE THE PROPERTY OF FUEL TECH AND ARE CONFIDENTIAL. ALL RIGHTS ARE RESERVED. ANY USE OTHER THAN THAT DESCRIBED IN THE CUSTOMER CONTRACT REQUIRES WRITTEN PERMISSION.

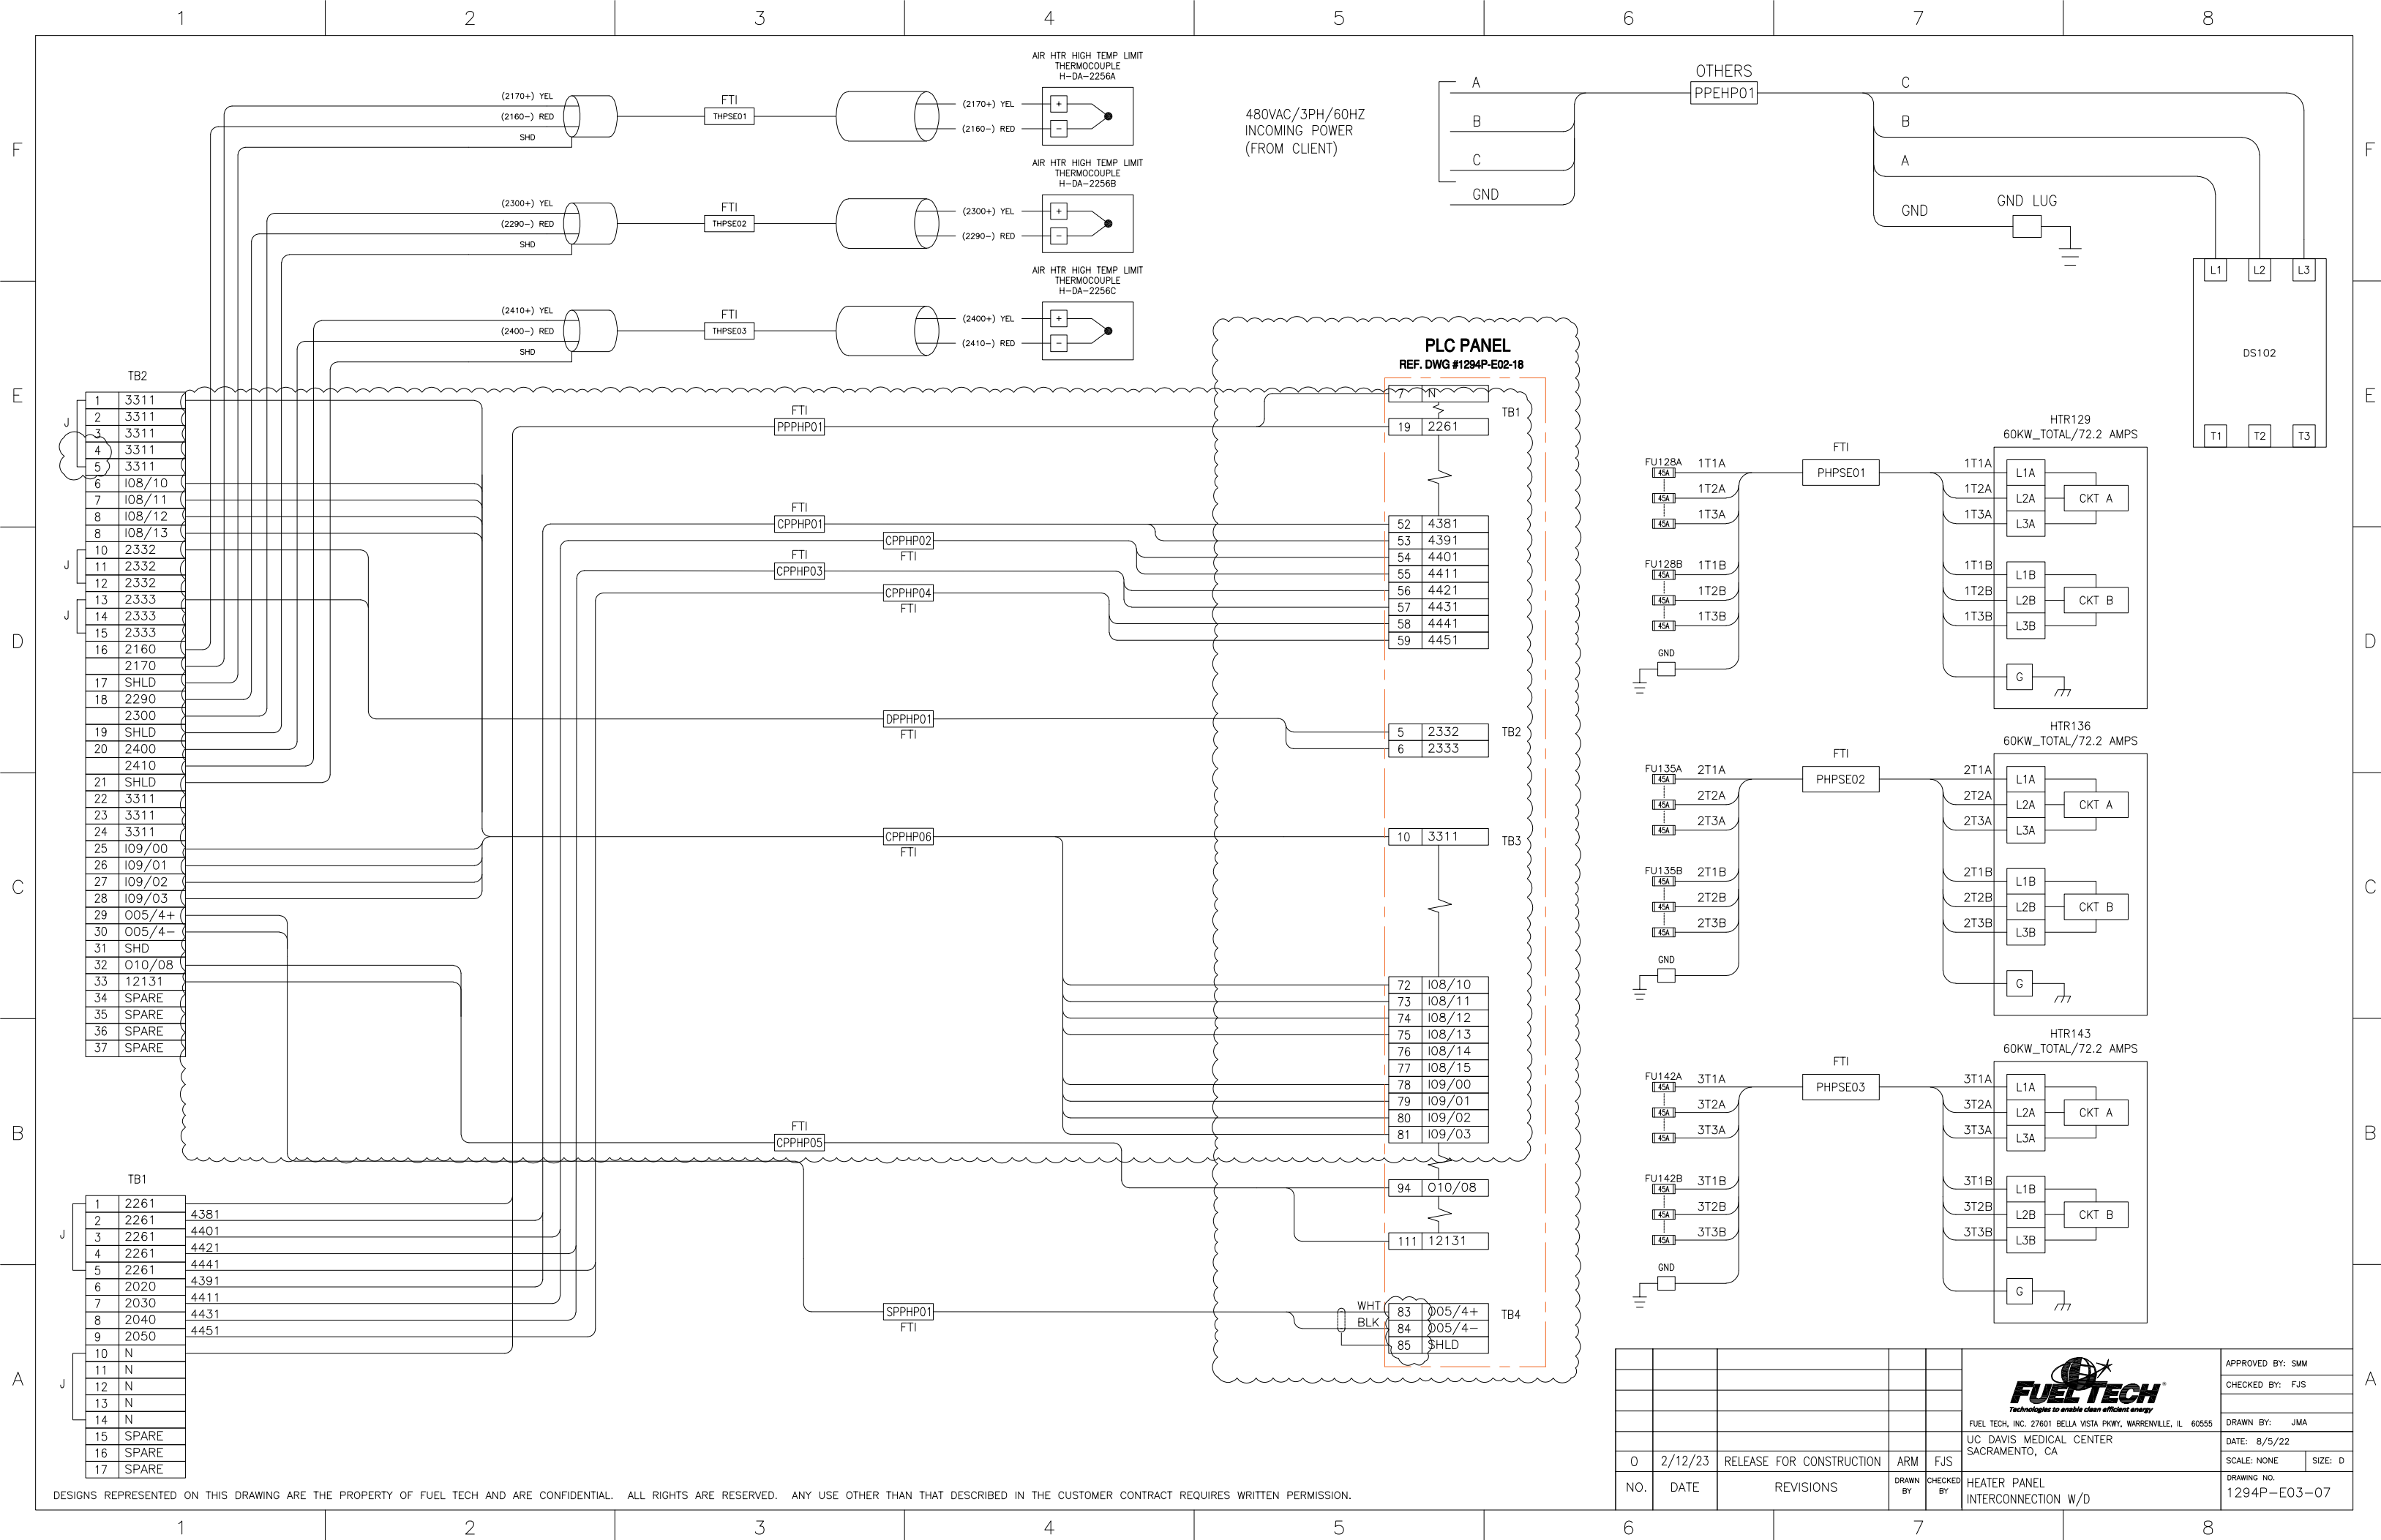

FRONT VIEW

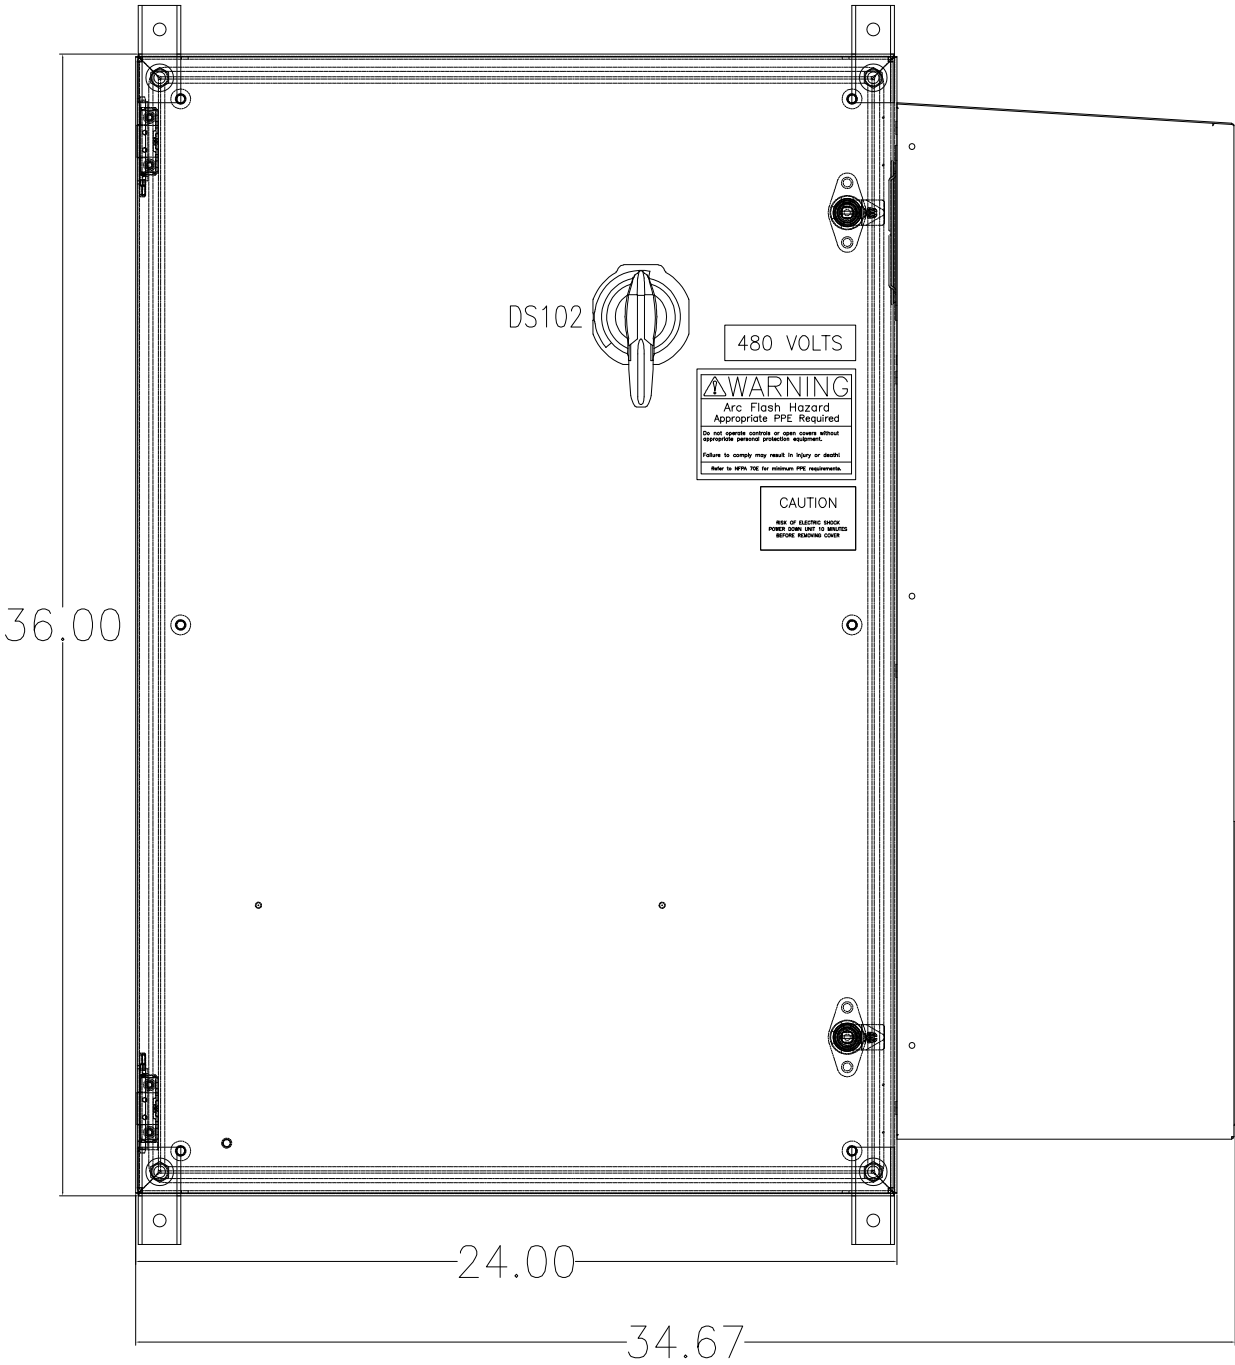

RIGHT SIDE VIEW

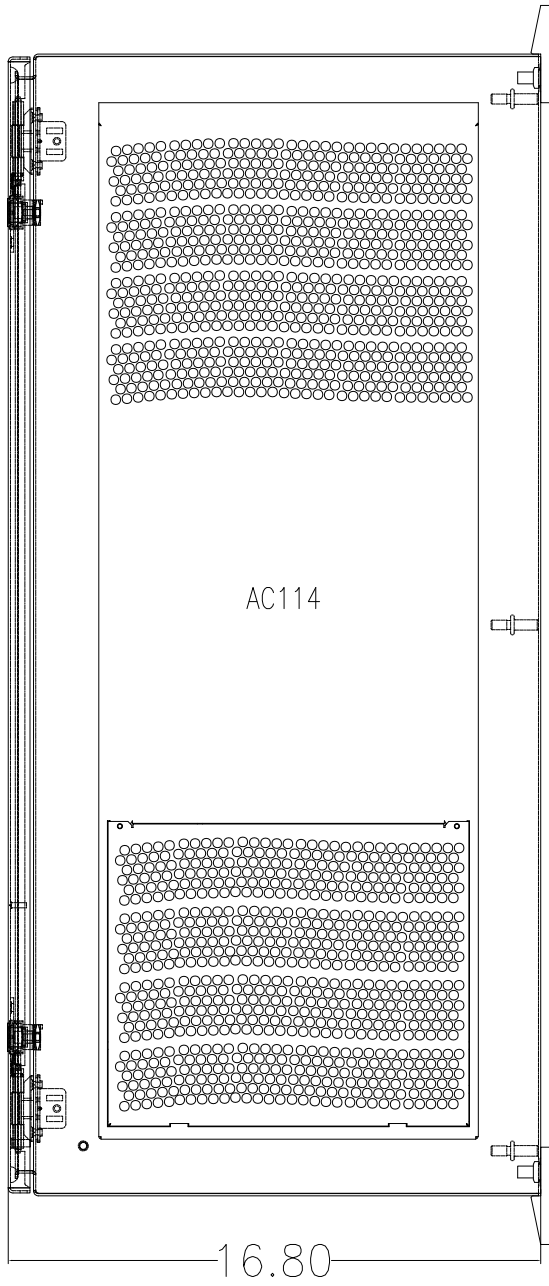

THT-19-413-1-PR

BETTER THINKING. INSIDE THE BOX.
N56 W24842 Corporate Circle, Sussex, WI 53089
480 VOLTS 38.2 FLA (TOTAL)
60 CYCLES N/A FLA (LARGEST MOTOR)
3 PHASE 1294-E04 DRWG. NO.
SHORT CIRCUIT CURRENT 50 kA RMS
SYMMETRICAL, 480 V MAXIMUM
TYPE 4 ENCLOSURE

Fuse ID	Mfg.	Fuse# or Equivalent	Volts
FU102	LITTELFUSE	JTD60D	600
FU114-115	LITTELFUSE	KLDR4	600

USE COPPER CONDUCTORS ONLY			
PART ID	PART NUMBER	TORQUE (IN/LB)	TEMP (C)
DS102	194R-J60-1753	35	90
TB's	1492-J4	9.0	90
TB's	1492-JG4	9.0	90
TB's	1492-J6	14.2	90
GND BAR	PK12GTA	20 (14-10GA)	90
GND BAR	PK12GTA	25 (8GA)	90
GND BAR	PK12GTA	35 (6-4GA)	90

USE COPPER CONDUCTORS ONLY			
PART ID	PART NUMBER	TORQUE (IN/LB)	TEMP (C)
GND LUG	L70	35 (14-10GA)	90
GND LUG	L70	40 (8GA)	90
GND LUG	L70	45 (4-6GA)	90

THT-19-435-1-HFC

WARNING
RISK OF FIRE OR ELECTRICAL SHOCK

THE OPENING OF THE BRANCH-CIRCUIT PROTECTIVE DEVICE MAY BE AN INDICATION THAT A FAULT CURRENT HAS BEEN INTERRUPTED. ALL CURRENT- CARRYING PARTS AND OTHER COMPONENTS PROTECTED BY THIS DEVICE SHOULD BE EXAMINED AND REPLACED IF DAMAGED. IF BURNOUT OF A CURRENT ELEMENT OF AN OVERLOAD RELAY OCCURS, THE COMPLETE OVERLOAD RELAY MUST BE REPLACED.

99454

WARNING
Arc Flash Hazard
Appropriate PPE Required

Do not operate controls or open covers without appropriate personal protection equipment.
Failure to comply may result in injury or death!
Refer to NFPA 70E for minimum PPE requirements.

THT-19-439-DC

CAUTION

RISK OF ELECTRIC SHOCK
POWER DOWN UNIT 10 MINUTES
BEFORE REMOVING COVER

THT-19-439-M


WARNING

THIS PANEL HAS MULTIPLE
SOURCES OF POTENTIAL --
DISCONNECT ALL SOURCES
BEFORE OPENING DOOR

152371

480 VOLTS

						 FUEL TECH, INC. 27601 BELLA VISTA PKWY, WARRENVILLE, IL 60555 UC DAVIS MEDICAL CENTER SACRAMENTO, CA	APPROVED BY: SMM	
							CHECKED BY: FJS	
							DRAWN BY: JMA	
							DATE: 8/5/22	
0	2/12/23	RELEASE FOR CONSTRUCTION	ARM	FJS			SCALE: NONE	SIZE: D
NO.	DATE	REVISIONS	DRAWN BY	CHECKED BY	BLOWER PANEL CABINET LAYOUT		DRAWING NO. 1294P-E04-01	

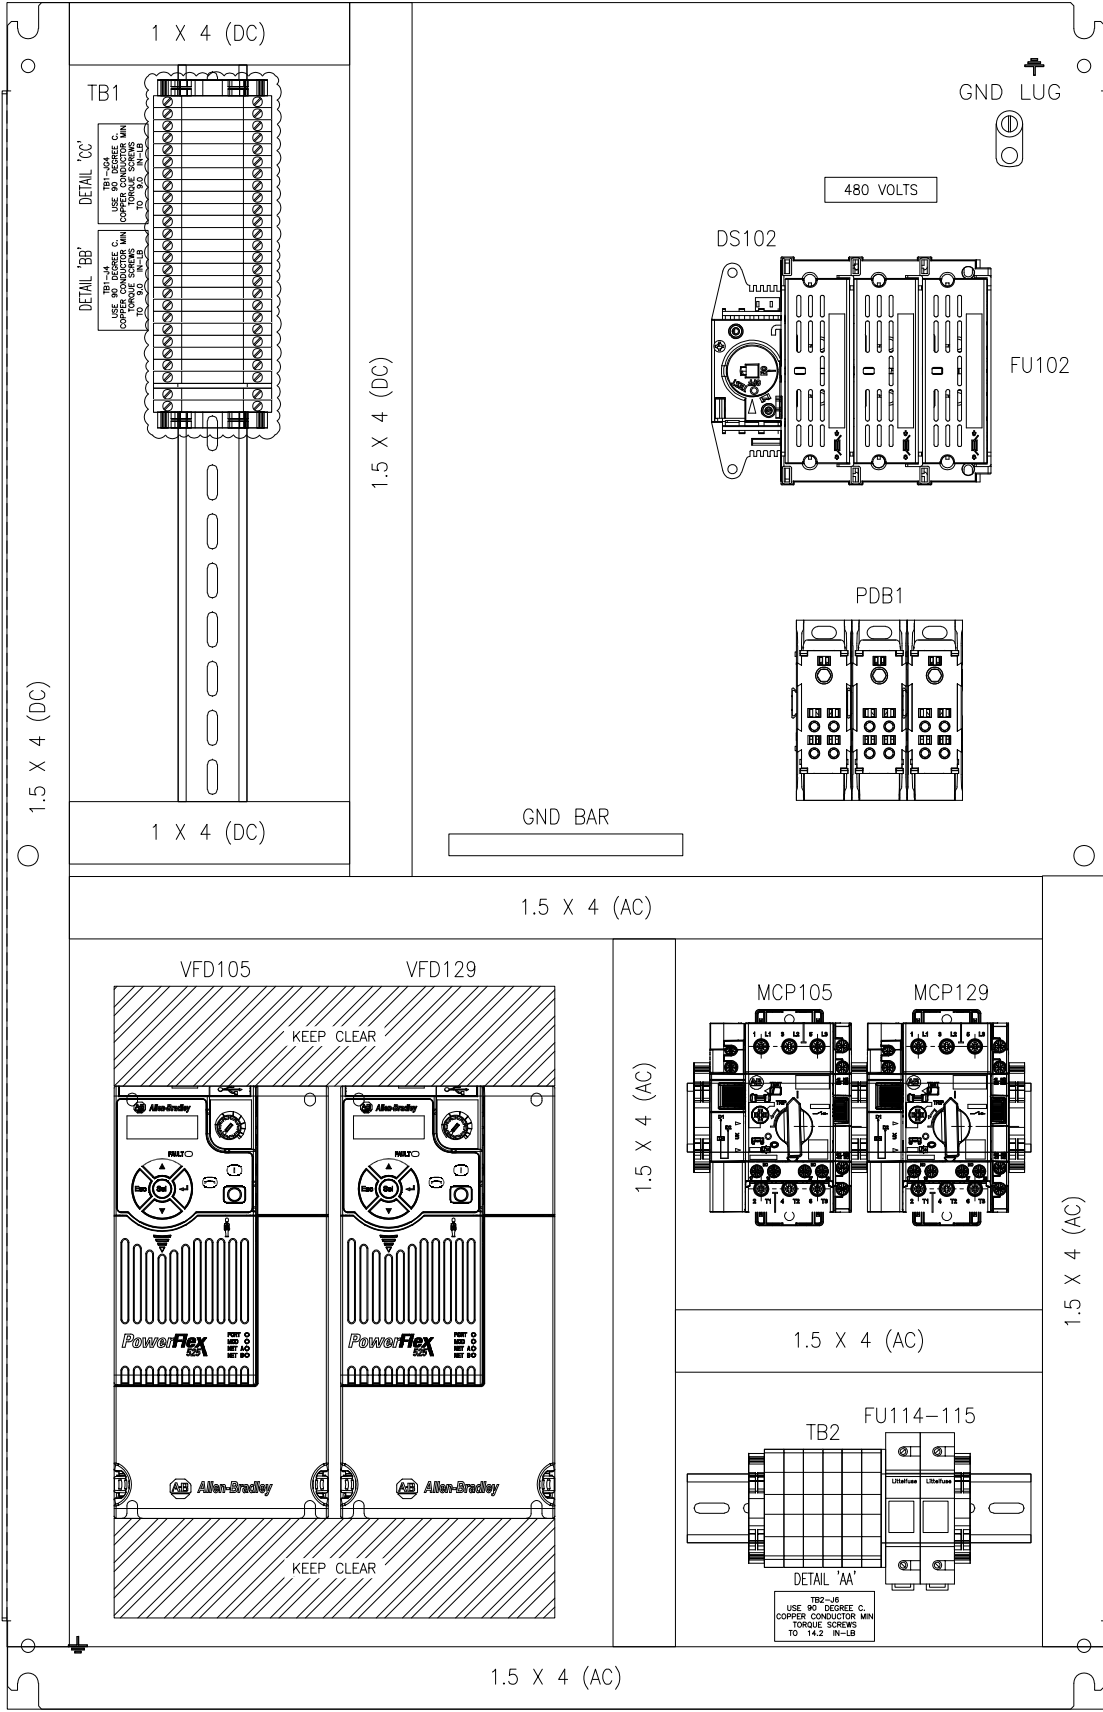

24VDC
TB1

1	2333
2	3311
3	3311
4	3311
5	3311
6	3311
7	3311
8	3311
9	4341
10	4351
11	4361
12	4371
13	I07/04
14	I07/05
15	I07/06
16	I07/07
17	I09/05
18	O05/2+
19	O05/2-
20	SHLD
21	O05/3+
22	O05/3-
23	SHLD
24	SHLD
25	SPARE
26	SPARE
27	SPARE
28	SPARE

25 @ 1492-J4
3 @ 1492-JG4

HIGH VOLTAGE
TB2

1	1T1
2	1T2
3	1T3
4	2T1
5	2T2
6	2T3

*6 @ 1492-J6

44315

480 VOLTS

THT-17-413-3-PR

DETAIL 'AA'

TB2-J6
USE 90 DEGREE C.
COPPER CONDUCTOR MIN
TORQUE SCREWS
TO 14.2 IN-LB

DETAIL 'BB'

TB1-J4
USE 90 DEGREE C.
COPPER CONDUCTOR MIN
TORQUE SCREWS
TO 9.0 IN-LB


DETAIL 'CC'

TB1-JG4
USE 90 DEGREE C.
COPPER CONDUCTOR MIN
TORQUE SCREWS
TO 9.0 IN-LB



FUEL TECH, INC. 27601 BELLA VISTA PKWY, WARRENVILLE, IL 60555
UC DAVIS MEDICAL CENTER
SACRAMENTO, CA

APPROVED BY: SMM
CHECKED BY: FJS
DRAWN BY: JMA
DATE: 8/5/22
SCALE: NONE
SIZE: D
DRAWING NO. 1294P-E04-02

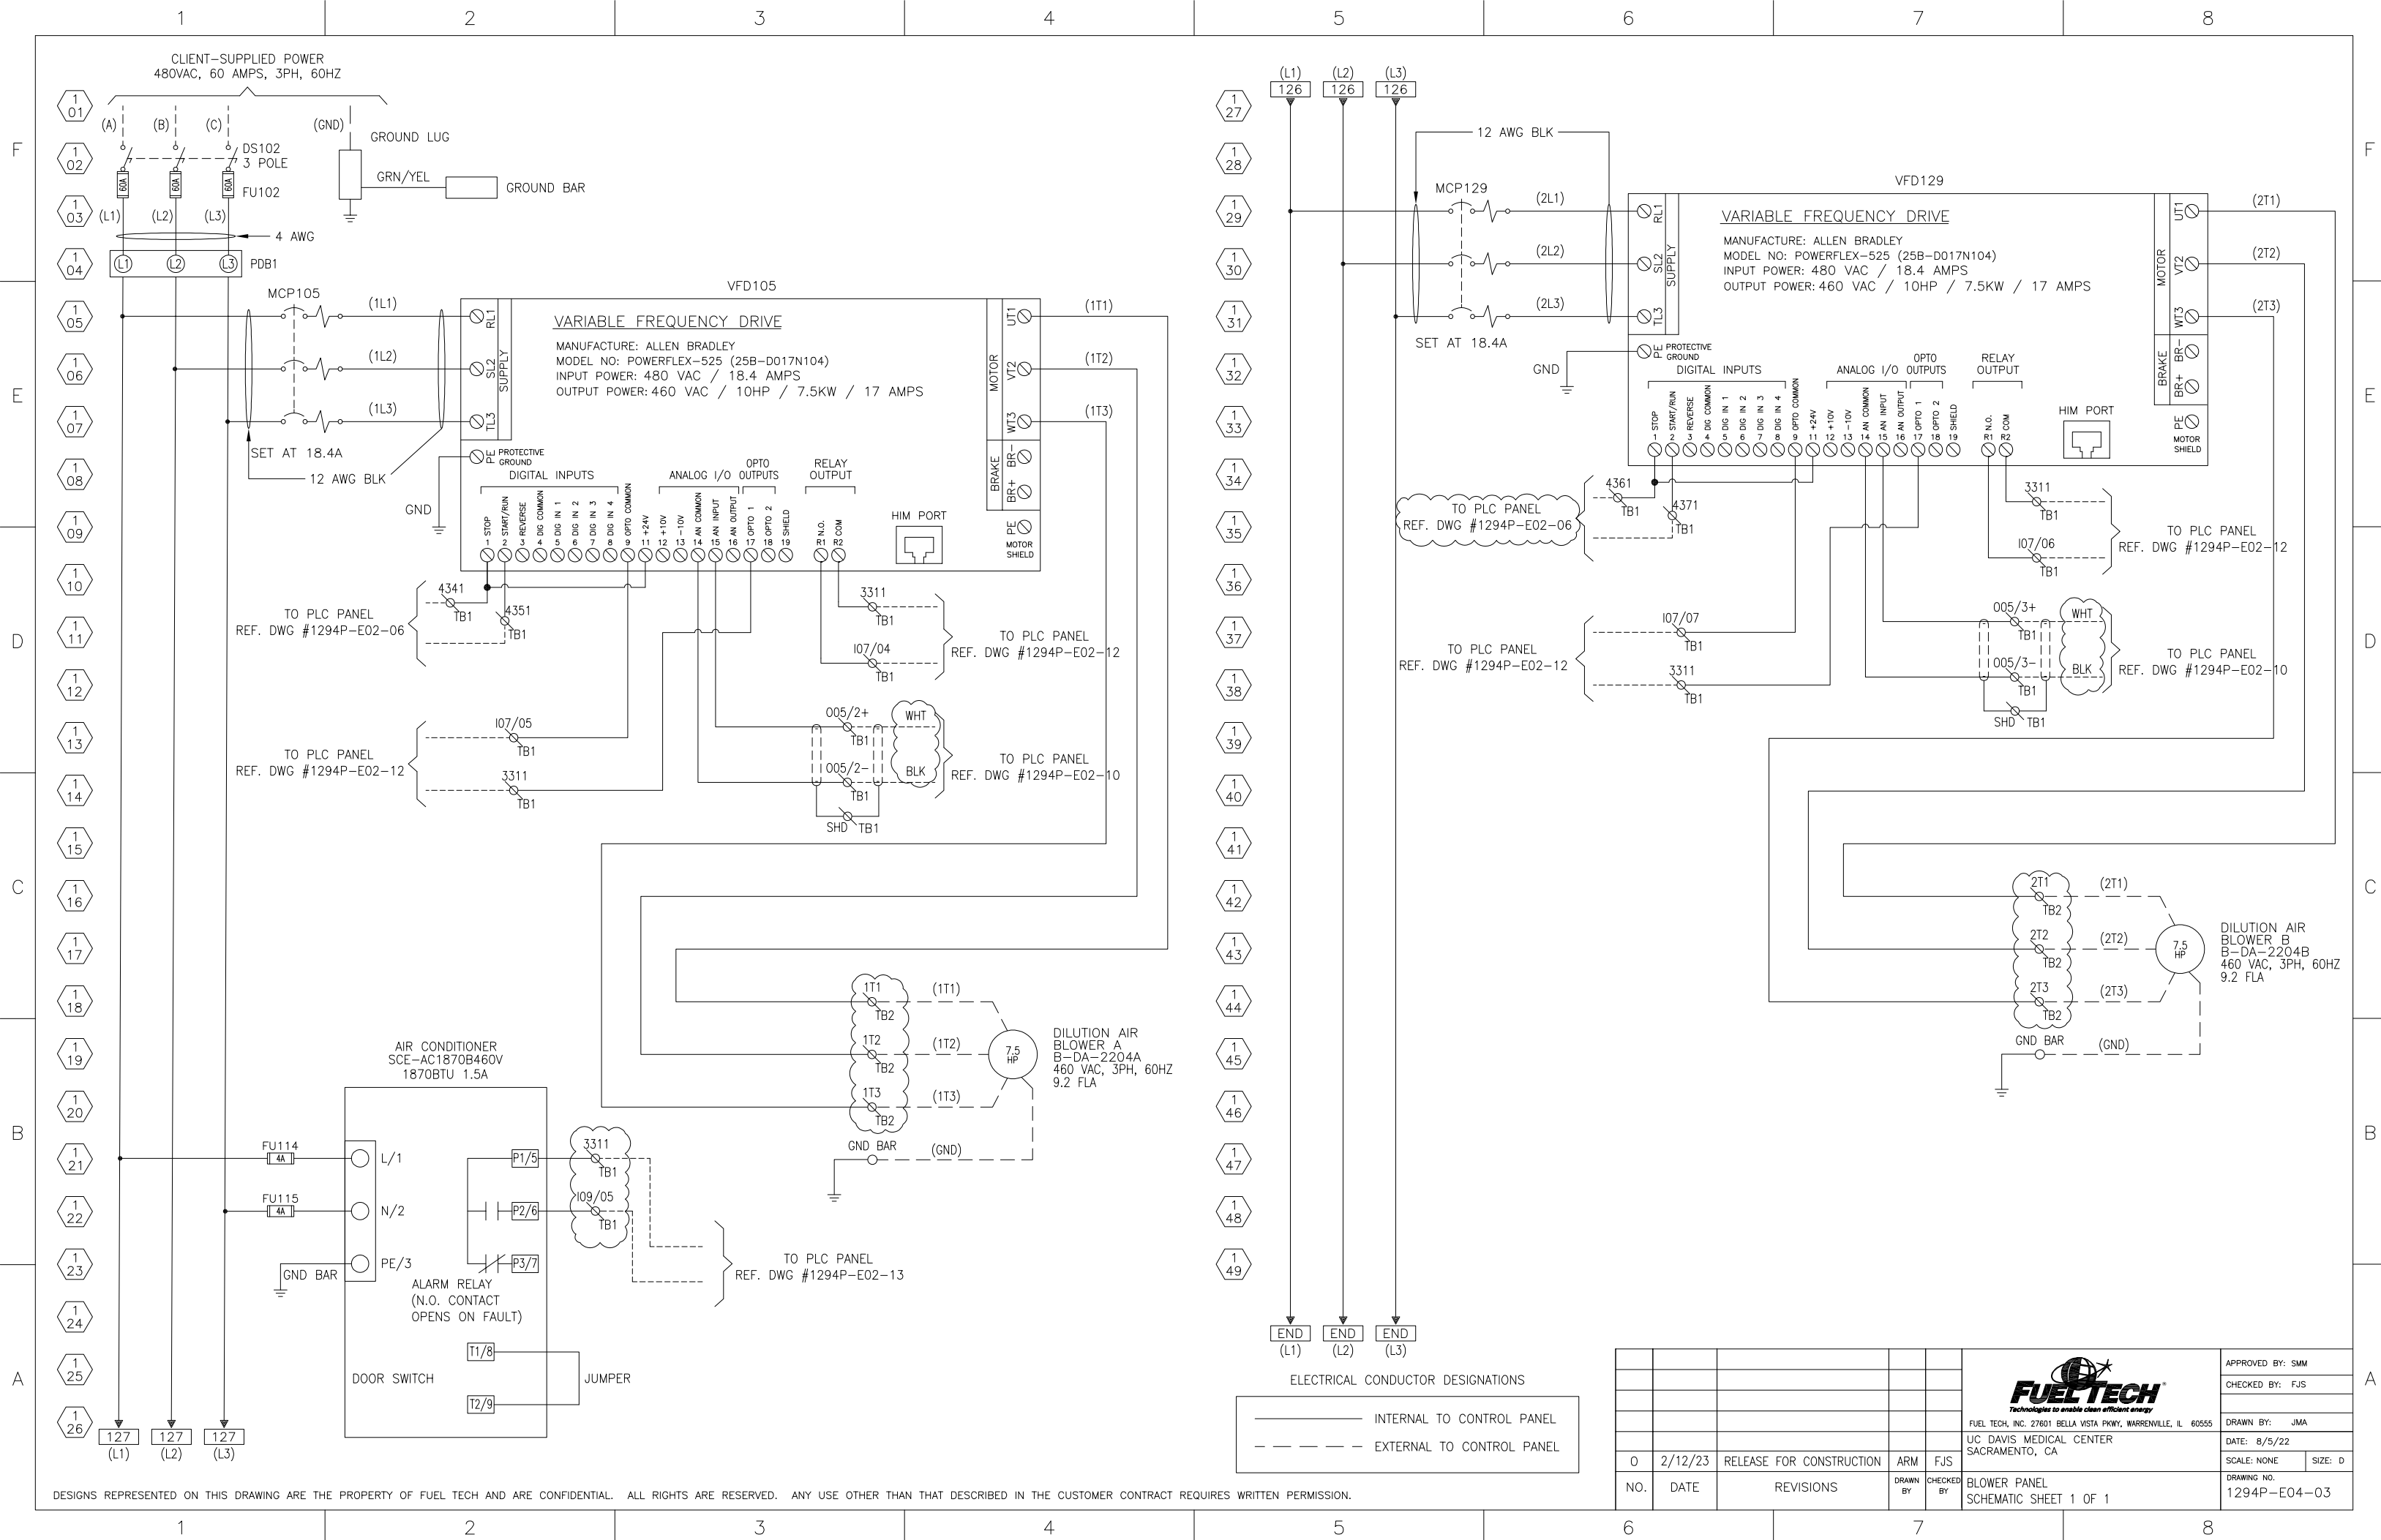

12345678

F

E

D

C

B

A

12345678

INTENTIONALLY BLANK
(FOR FUTURE USE IF NEEDED)

					 FUEL TECH, INC. 27601 BELLA VISTA PKWY, WARRENVILLE, IL 60555 UC DAVIS MEDICAL CENTER SACRAMENTO, CA	APPROVED BY: SMM	
						CHECKED BY: FJS	
						DRAWN BY: JMA	
						DATE: 8/5/22	
0	2/12/23	RELEASE FOR CONSTRUCTION	ARM	FJS		SCALE: NONE	SIZE: D
NO.	DATE	REVISIONS	DRAWN BY	CHECKED BY	DRAWING NO. 1294P-E04-04		


1		2		3		4		5		6		7		8	
DEVICE ID		PART NUMBER		DESCRIPTION		MANUFACTURER		QTY							
AC114		SCE-AC1870B460V		AC, 1870 BTUH, TYPE 3R/4/12460/1/60 1.5A RUN, 5.0A START		SAGINAW		1							
DS102		194R-J60-1753		DISCONNECT SWITCH, FUSIBLE, 3-POLE, 60A, THRU-DOOR ROTARY		AB		1							
DS102		194R-PY		OPERATING HANDLE, DISCONNECTSWITCH, THRU-DOOR ROTARY		AB		1							
DS102		194R-S2		OPERATING SHAFT, DISCONNECT SWITCH, 21 LONG, USED ON 194R-P		AB		1							
FU102		JTD60ID		FUSE, CLASS J, 60A TIME-DELAY600V AC/300V DC, INDICATING		LITTELFUSE		3							
FU114-115		KLDR4		FUSE, CLASS CC, 4 AMPS, 600V, TIME-DELAY, NON-INDICATING		LITTELFUSE		2							
FU114-115		LPSC002ID		FUSE HOLDER, 2-POLE, 30ACCLASS CC, 600V AC/DC WBF1		LITTELFUSE		1							
GND BAR		PK12GTA		LOAD CENTER EQUIPMENT GROUNDBAR ASSY		SCHNEIDER ELECTRIC		1							
GND LUG		L70		GROUND LUG, 14 SOL-4 STRANDED1 CONDUCTOR		T&B		1							
MCP105,MCP129		140MT-D9E-C25		MCP, 18-25A, FRAME D		AB		2							
PDB1		EPBCP45		PWR DIST BLOCK, 1-POLE, 200 AMPS, 1 LINE SIDE OPENING PER PO		MARATHON SP		3							
TB1		1492-CJ18-10		JUMPER, TERMINAL BLOCK 10-POLEINSULATED, 8MM SCREW CENTER		AB		1							
TB1		1492-J4		TERMINAL BLOCK, GRAY, SCREW35A, 600V AC/DC, 22 - 10 AWG		AB		25							
TB1		1492-JG4		TERMINAL BLOCK, GRN/YEL, SCREW22 - 10 AWG, GROUND		AB		3							
TB1,TB2		1492-EAJ35		END ANCHOR, TERMINAL BLOCKNORMAL DUTY		AB		7							
TB1,TB2		1492-EBJ3		END BARRIER, TERMINAL BLOCKGRAY, USED ON 1492-J		AB		3							
TB1,TB2		1492-M6X12-ENG		MARKER CARD, TERMINAL BLOCKENGRAVED, 120/CARD, 1492-J		AB		1							
TB2		1492-J6		TERMINAL BLOCK, GRAY, SCREW50A, 600V AC/DC, 22 - 8 AWG		AB		6							
VFD105,VFD129		25B-D017N104		VFD, POWERFLEX 525, 480 VAC3-PHASE, 17 AMPS, FRAME C		AB		2							
		8760		CABLE, 1 PAIR, 18 AWG, PAIREDSHIELDED, 300 VOLTS, PVC GRAY		BELDEN		A/R							
		152371		LABEL, 480V, VOLTAGE LABEL1.125 X 4.125 , BLACK ON ORG		ICC		1							
		44315		LABEL, 480V, VOLTAGE LABEL0.5 X 2.25 , BLACK ON ORANGE		ICC		1							
		99454		LABEL, WARNING LABELARC FLASH, 3.5 H X 5 W		BRADY		1							
		1492-M8X5-ENG		MARKER CARD, TERMINAL BLOCKENGRAVED, 160/CARD, 1492-J/-L		AB		A/R							
		98.300.1800.0		DIN RAIL SLOTTED, WIELAND35MM X 7.5MM X 2M		WIELAND		A/R							
		C1.5WH6		COVER, PANEL CHANNEL, WHITE1.5 INCH DUCT COVER		PANDUIT		A/R							
		C1WH6		COVER, PANEL CHANNEL, WHITE1 INCH DUCT COVER		PANDUIT		A/R							
		CP3624		SUB PANEL, 34.20 X 22.20STEEL, WHITE FINISH		HOFFMAN		1							
		CSD362416M100		ENCLOSURE PER MOD DWGCSD362416		HOFFMAN		1							
		CMFK		WALL MOUNTING HARDWARE KIT		HOFFMAN		1							
		G1.5X4WH6		PANEL CHANNEL, 1.5X4 WHITE		PANDUIT		A/R							
		G1X4WH6		PANEL CHANNEL, 1X4 WHITE		PANDUIT		A/R							
		THT-19-435-1-PR		LABEL, SPEC/FUSE/TORQUEENGRAVED, SILVER, 3 X 2		ICC		3							
		THT-19-439-DC		LABEL CAUTION RISK OF ELECTRICSHOCK POWER DOWN UNIT 10 MIN		ICC		1							
		THT-19-439-HFC		LABEL, WARNING - RISK OF FIREOR ELECTRICAL SHOCK		ICC		1							
		THT-19-439-M		LABEL, WARNING - THIS PANELHAS MULTIPLE SOURCES		ICC		1							
		THT-5-435-10-PR		LABEL, ID, ENGRAVEDSILVER, 1 X 0.5		ICC		A/R							
		THT-80-427-5-PR		LABEL, SELF-LAM SMALLENGRAVED, 0.5 X 0.75		ICC		A/R							
		THT-9-427-10-PR		LABEL, SELF LAM (LARGE)ENGRAVED, 1 X 1.4375		ICC		A/R							

					 FUEL TECH, INC. 27601 BELLA VISTA PKWY, WARRENVILLE, IL 60555 UC DAVIS MEDICAL CENTER SACRAMENTO, CA	APPROVED BY: SMM	
						CHECKED BY: FJS	
						DRAWN BY: JMA	
						DATE: 8/5/22	
0	2/12/23	RELEASE FOR CONSTRUCTION	ARM	FJS	SCALE: NONE	SIZE: D	
NO.	DATE	REVISIONS	DRAWN BY	CHECKED BY	BLOWER PANEL BILL OF MATERIALS		DRAWING NO. 1294P-E04-05

DESIGNS REPRESENTED ON THIS DRAWING ARE THE PROPERTY OF FUEL TECH AND ARE CONFIDENTIAL. ALL RIGHTS ARE RESERVED. ANY USE OTHER THAN THAT DESCRIBED IN THE CUSTOMER CONTRACT REQUIRES WRITTEN PERMISSION.

1		2		3		4		5		6		7		8	
---	--	---	--	---	--	---	--	---	--	---	--	---	--	---	--

					 FUEL TECH Technologies to enable clean efficient energy FUEL TECH, INC. 27601 BELLA VISTA PKWY, WARRENVILLE, IL 60555	APPROVED BY: SMM		
						CHECKED BY: FJS		
						DRAWN BY: JMA		
						DATE: 8/5/22		
0	2/12/23	RELEASE FOR CONSTRUCTION	ARM	FJS	UC DAVIS MEDICAL CENTER SACRAMENTO, CA		SCALE: NONE	SIZE: D
NO.	DATE	REVISIONS	DRAWN BY	CHECKED BY	BLOWER PANEL BILL OF MATERIALS		DRAWING NO. 1294P-E04-05	

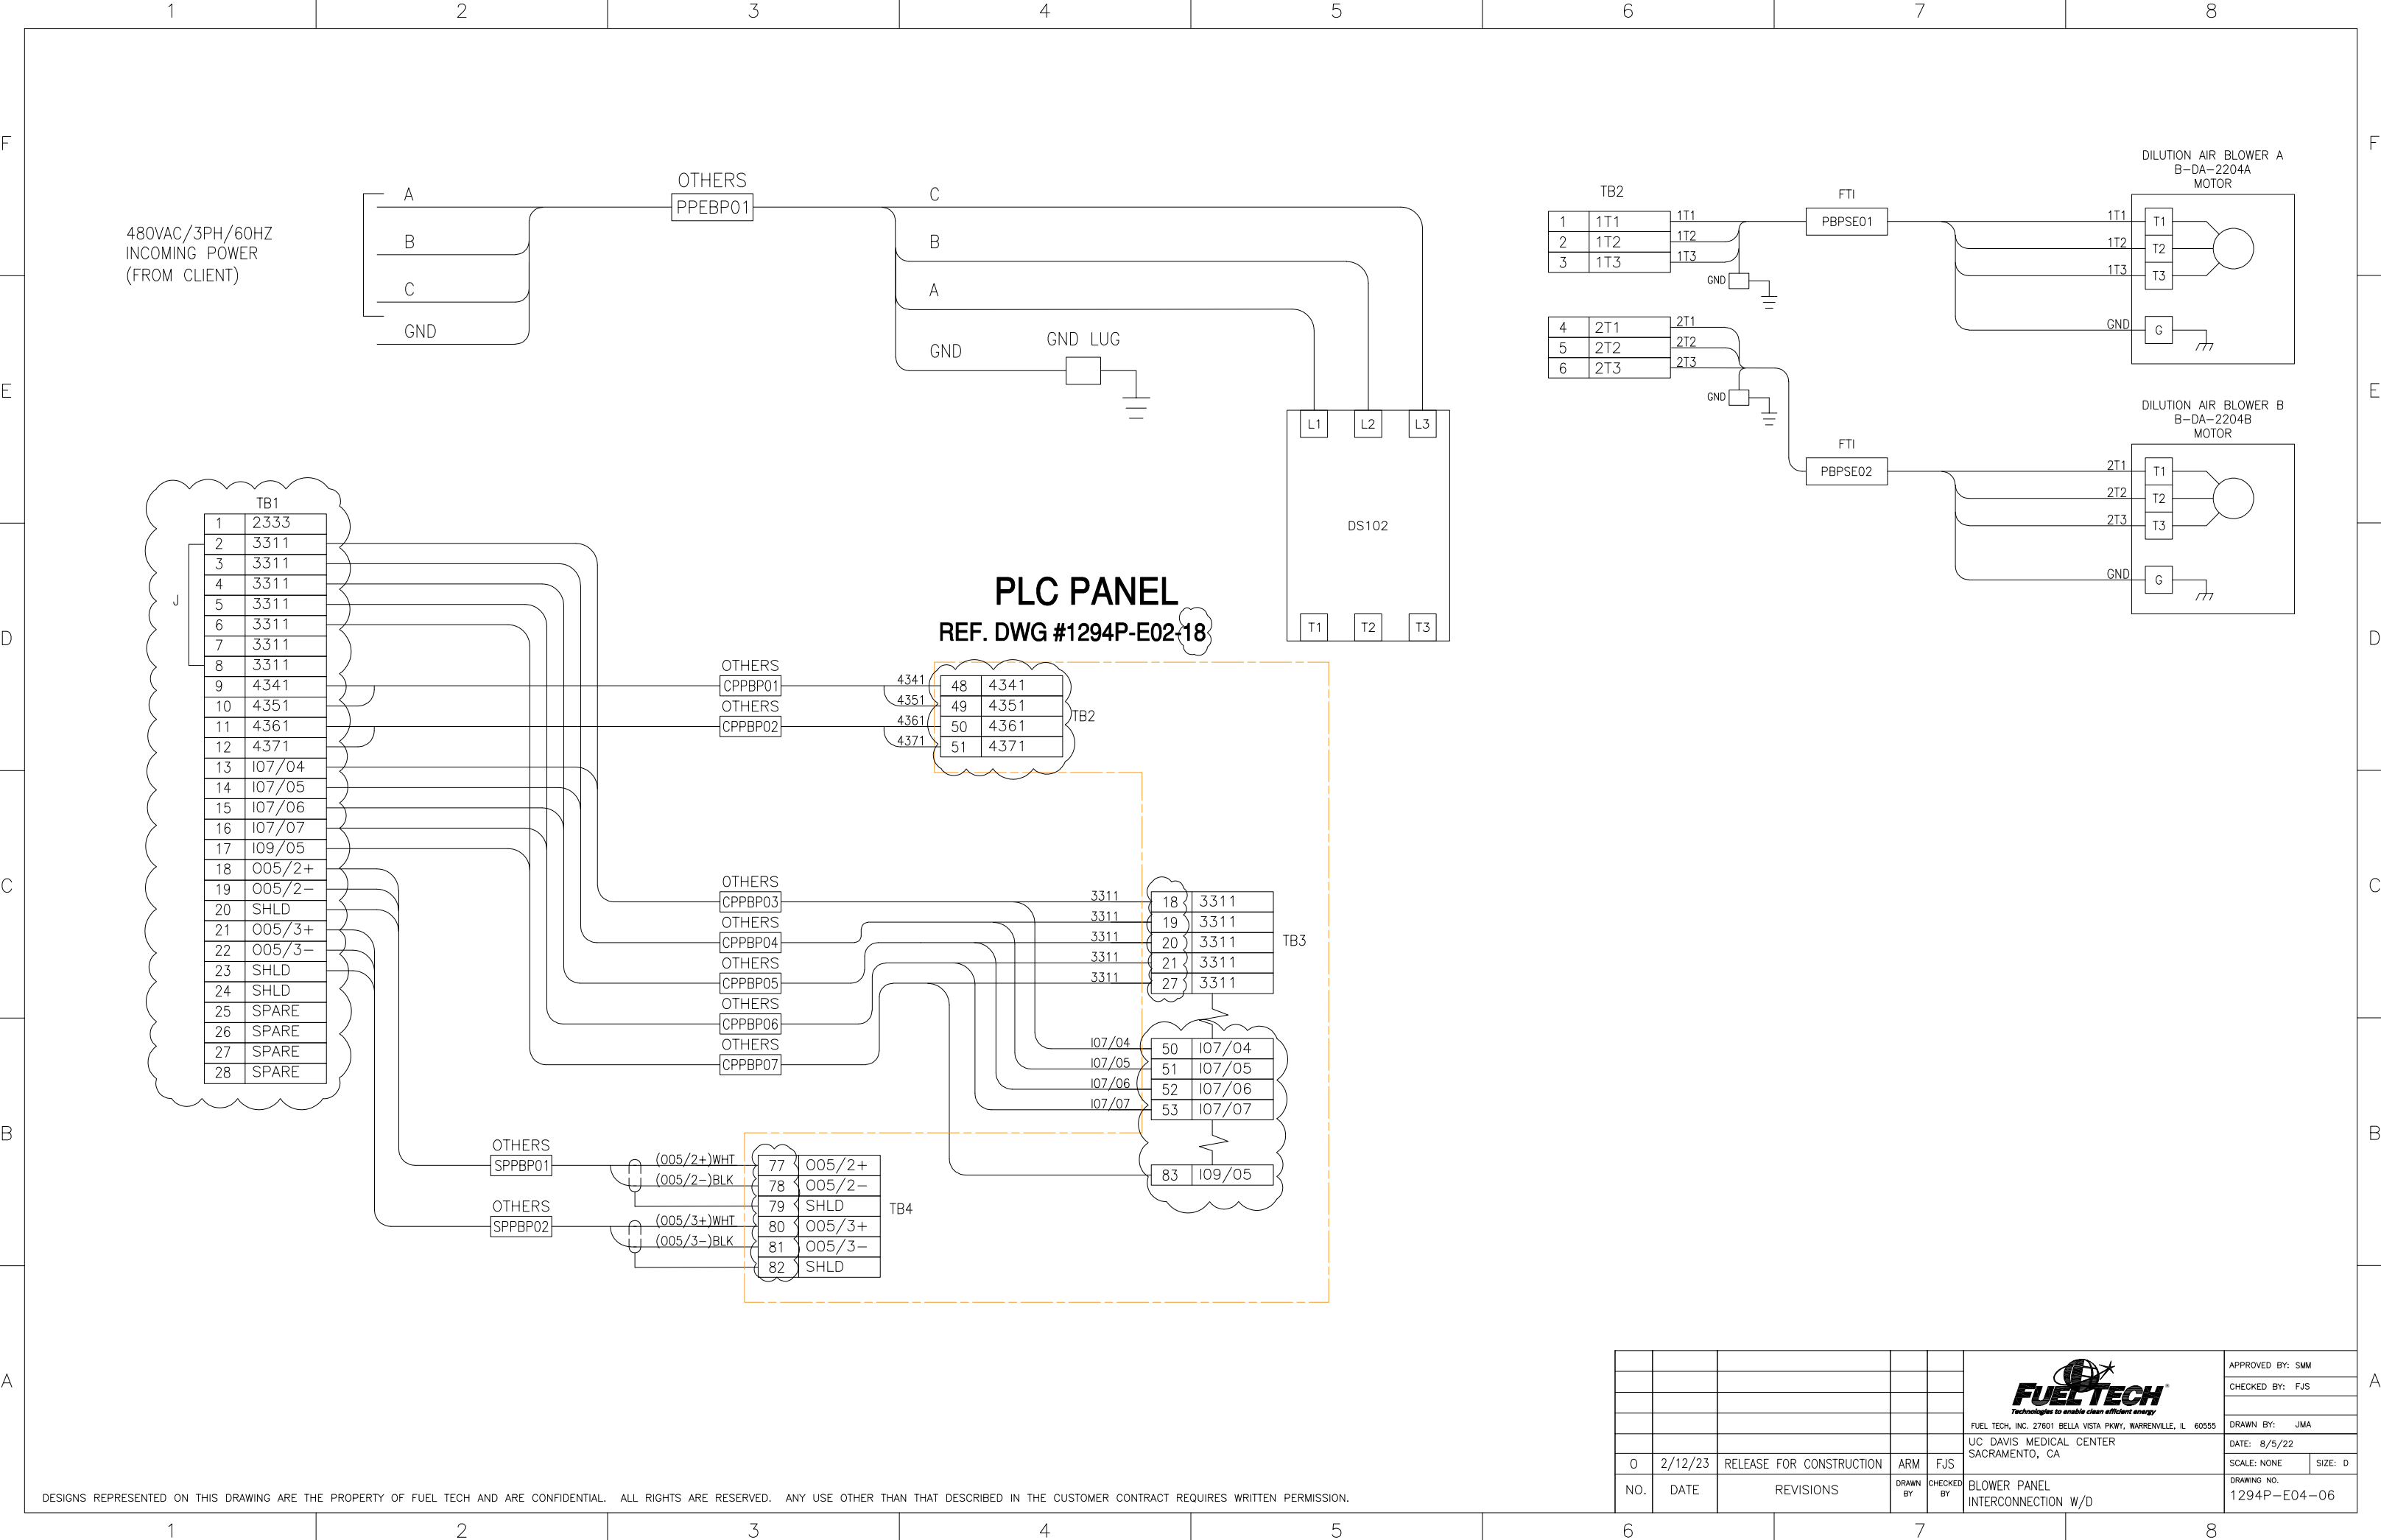

F

E

D

C

B

A

1

2

3

4

5

6

7

8

INTERCONNECT CABLE/WIRE LIST

CABLE NO.	NO. COND.	WIRE SIZE	FROM		TO		WIRE NUMBERS	CABLING BY
			LOCATION	DEVICE	LOCATION	DEVICE		
PPEBP01	2 + 1	CLIENT-DEFINED	CLIENT	480VAC,3PH,60HZ SOURCE	BLOWER PANEL	DS102	A B C GND	OTHERS
PBPSE01	3+1	#12 AWG 600V 90C MIN	BLOWER PANEL	TB2	B-DA-2204A	DILUTION AIR BLOWER A	1T1 1T2 1T3 GND	FTI
PBPSE02	3+1	#12 AWG 600V 90C MIN	BLOWER PANEL	TB2	B-DA-2204B	DILUTION AIR BLOWER B	2T1 2T2 2T3 GND	FTI
CPPBP01	2 WIRE CABLE	#14 AWG 600V 90C MIN	PLC PANEL	TB2	BLOWER PANEL	TB1	4341 4351	OTHERS
CPPBP02	2 WIRE CABLE	#14 AWG 600V 90C MIN	PLC PANEL	TB2	BLOWER PANEL	TB1	4361 4371	OTHERS
CPPBP03	2 WIRE CABLE	#14 AWG 600V 90C MIN	PLC PANEL	TB3	BLOWER PANEL	TB1	3311 I07/04	OTHERS
CPPBP04	2 WIRE CABLE	#14 AWG 600V 90C MIN	PLC PANEL	TB3	BLOWER PANEL	TB1	3311 I07/05	OTHERS
CPPBP05	2 WIRE CABLE	#14 AWG 600V 90C MIN	PLC PANEL	TB3	BLOWER PANEL	TB1	3311 I07/06	OTHERS
CPPBP06	2 WIRE CABLE	#14 AWG 600V 90C MIN	PLC PANEL	TB3	BLOWER PANEL	TB1	3311 I07/07	OTHERS
CPPBP07	2 WIRE CABLE	#14 AWG 600V 90C MIN	PLC PANEL	TB3	BLOWER PANEL	TB1	3311 I09/05	OTHERS
SPPBP01	2 WIRE CABLE	#16 AWG SIGNAL SHIELDED	PLC PANEL	TB4	BLOWER PANEL	TB1	005/2+ 005/2- SHLD	OTHERS
SPPBP02	2 WIRE CABLE	#16 AWG SIGNAL SHIELDED	PLC PANEL	TB4	BLOWER PANEL	TB1	005/3+ 005/3- SHLD	OTHERS

DESIGNS REPRESENTED ON THIS DRAWING ARE THE PROPERTY OF FUEL TECH AND ARE CONFIDENTIAL. ALL RIGHTS ARE RESERVED. ANY USE OTHER THAN THAT DESCRIBED IN THE CUSTOMER CONTRACT REQUIRES WRITTEN PERMISSION.

								 FUEL TECH, INC. 27601 BELLA VISTA PKWY, WARRENVILLE, IL 60555 UC DAVIS MEDICAL CENTER SACRAMENTO, CA	APPROVED BY: SMM	
									CHECKED BY: FJS	
									DRAWN BY: JMA	
									DATE: 8/5/22	
0	2/12/23	RELEASE FOR CONSTRUCTION	ARM	FJS				SCALE: NONE	SIZE: D	
NO.	DATE	REVISIONS	DRAWN BY	CHECKED BY	BLOWER PANEL CABLE LISTING			DRAWING NO. 1294P-E04-07		

1

2

3

4


5


6

7

8

A

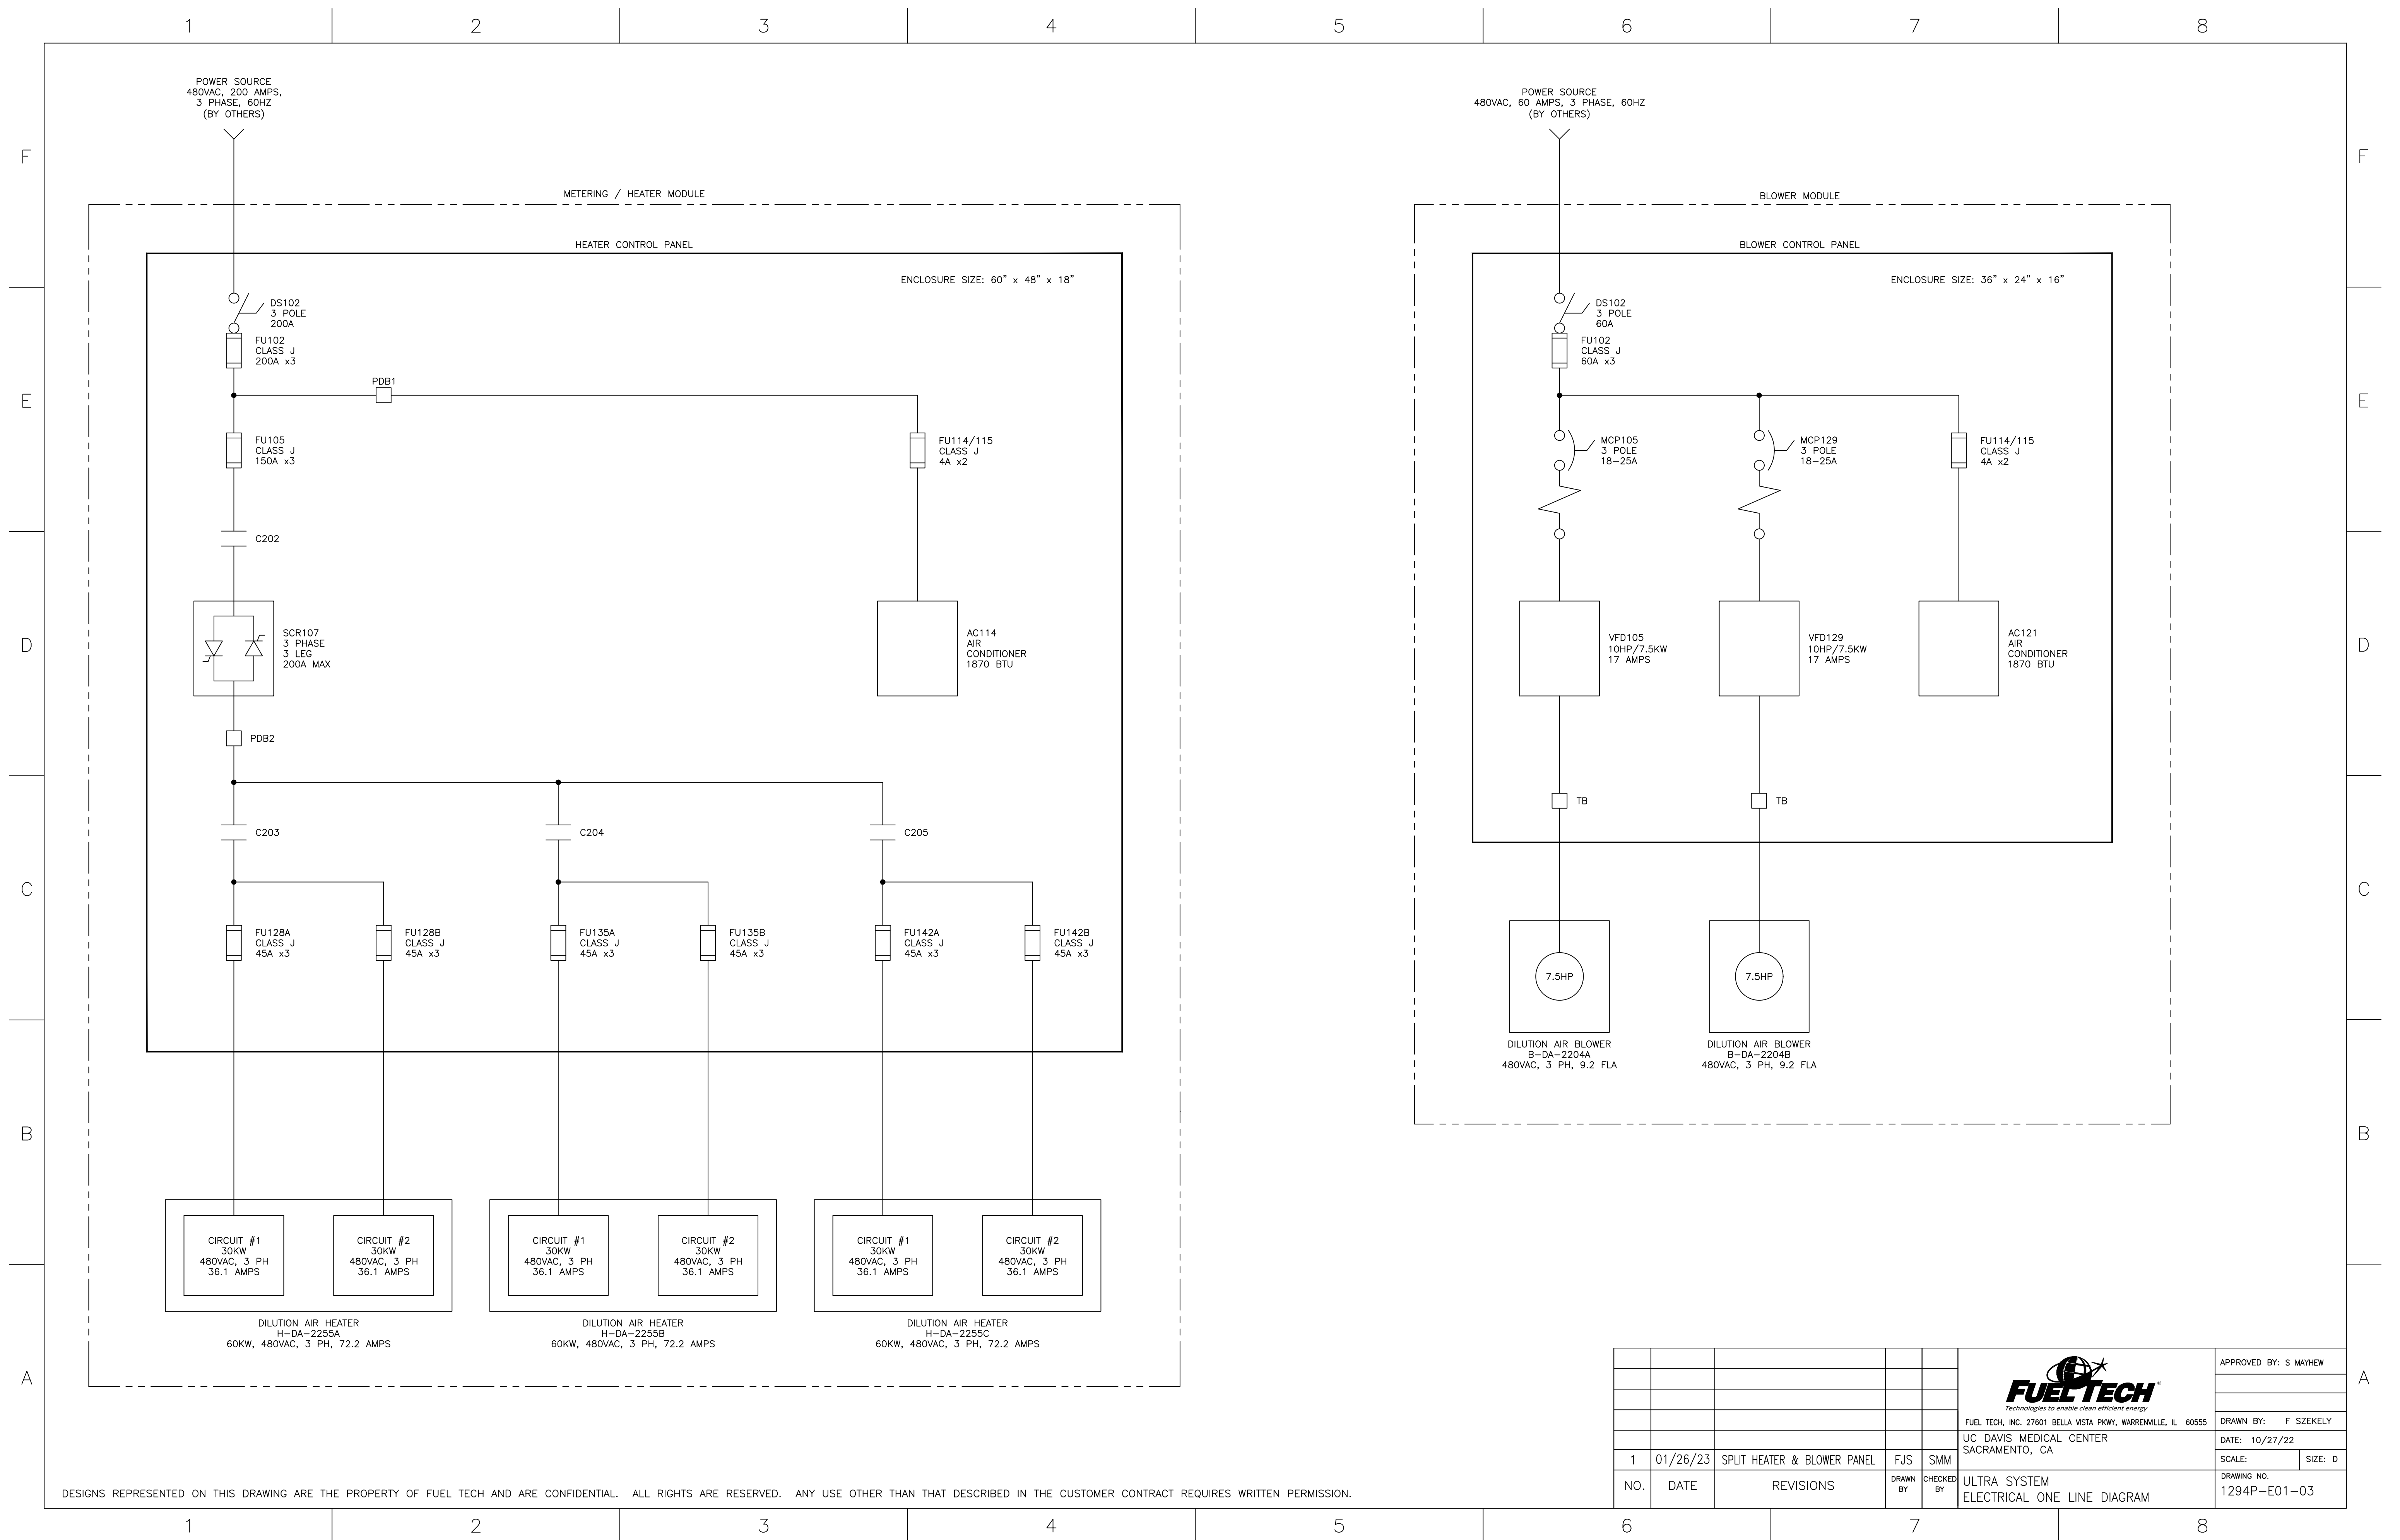

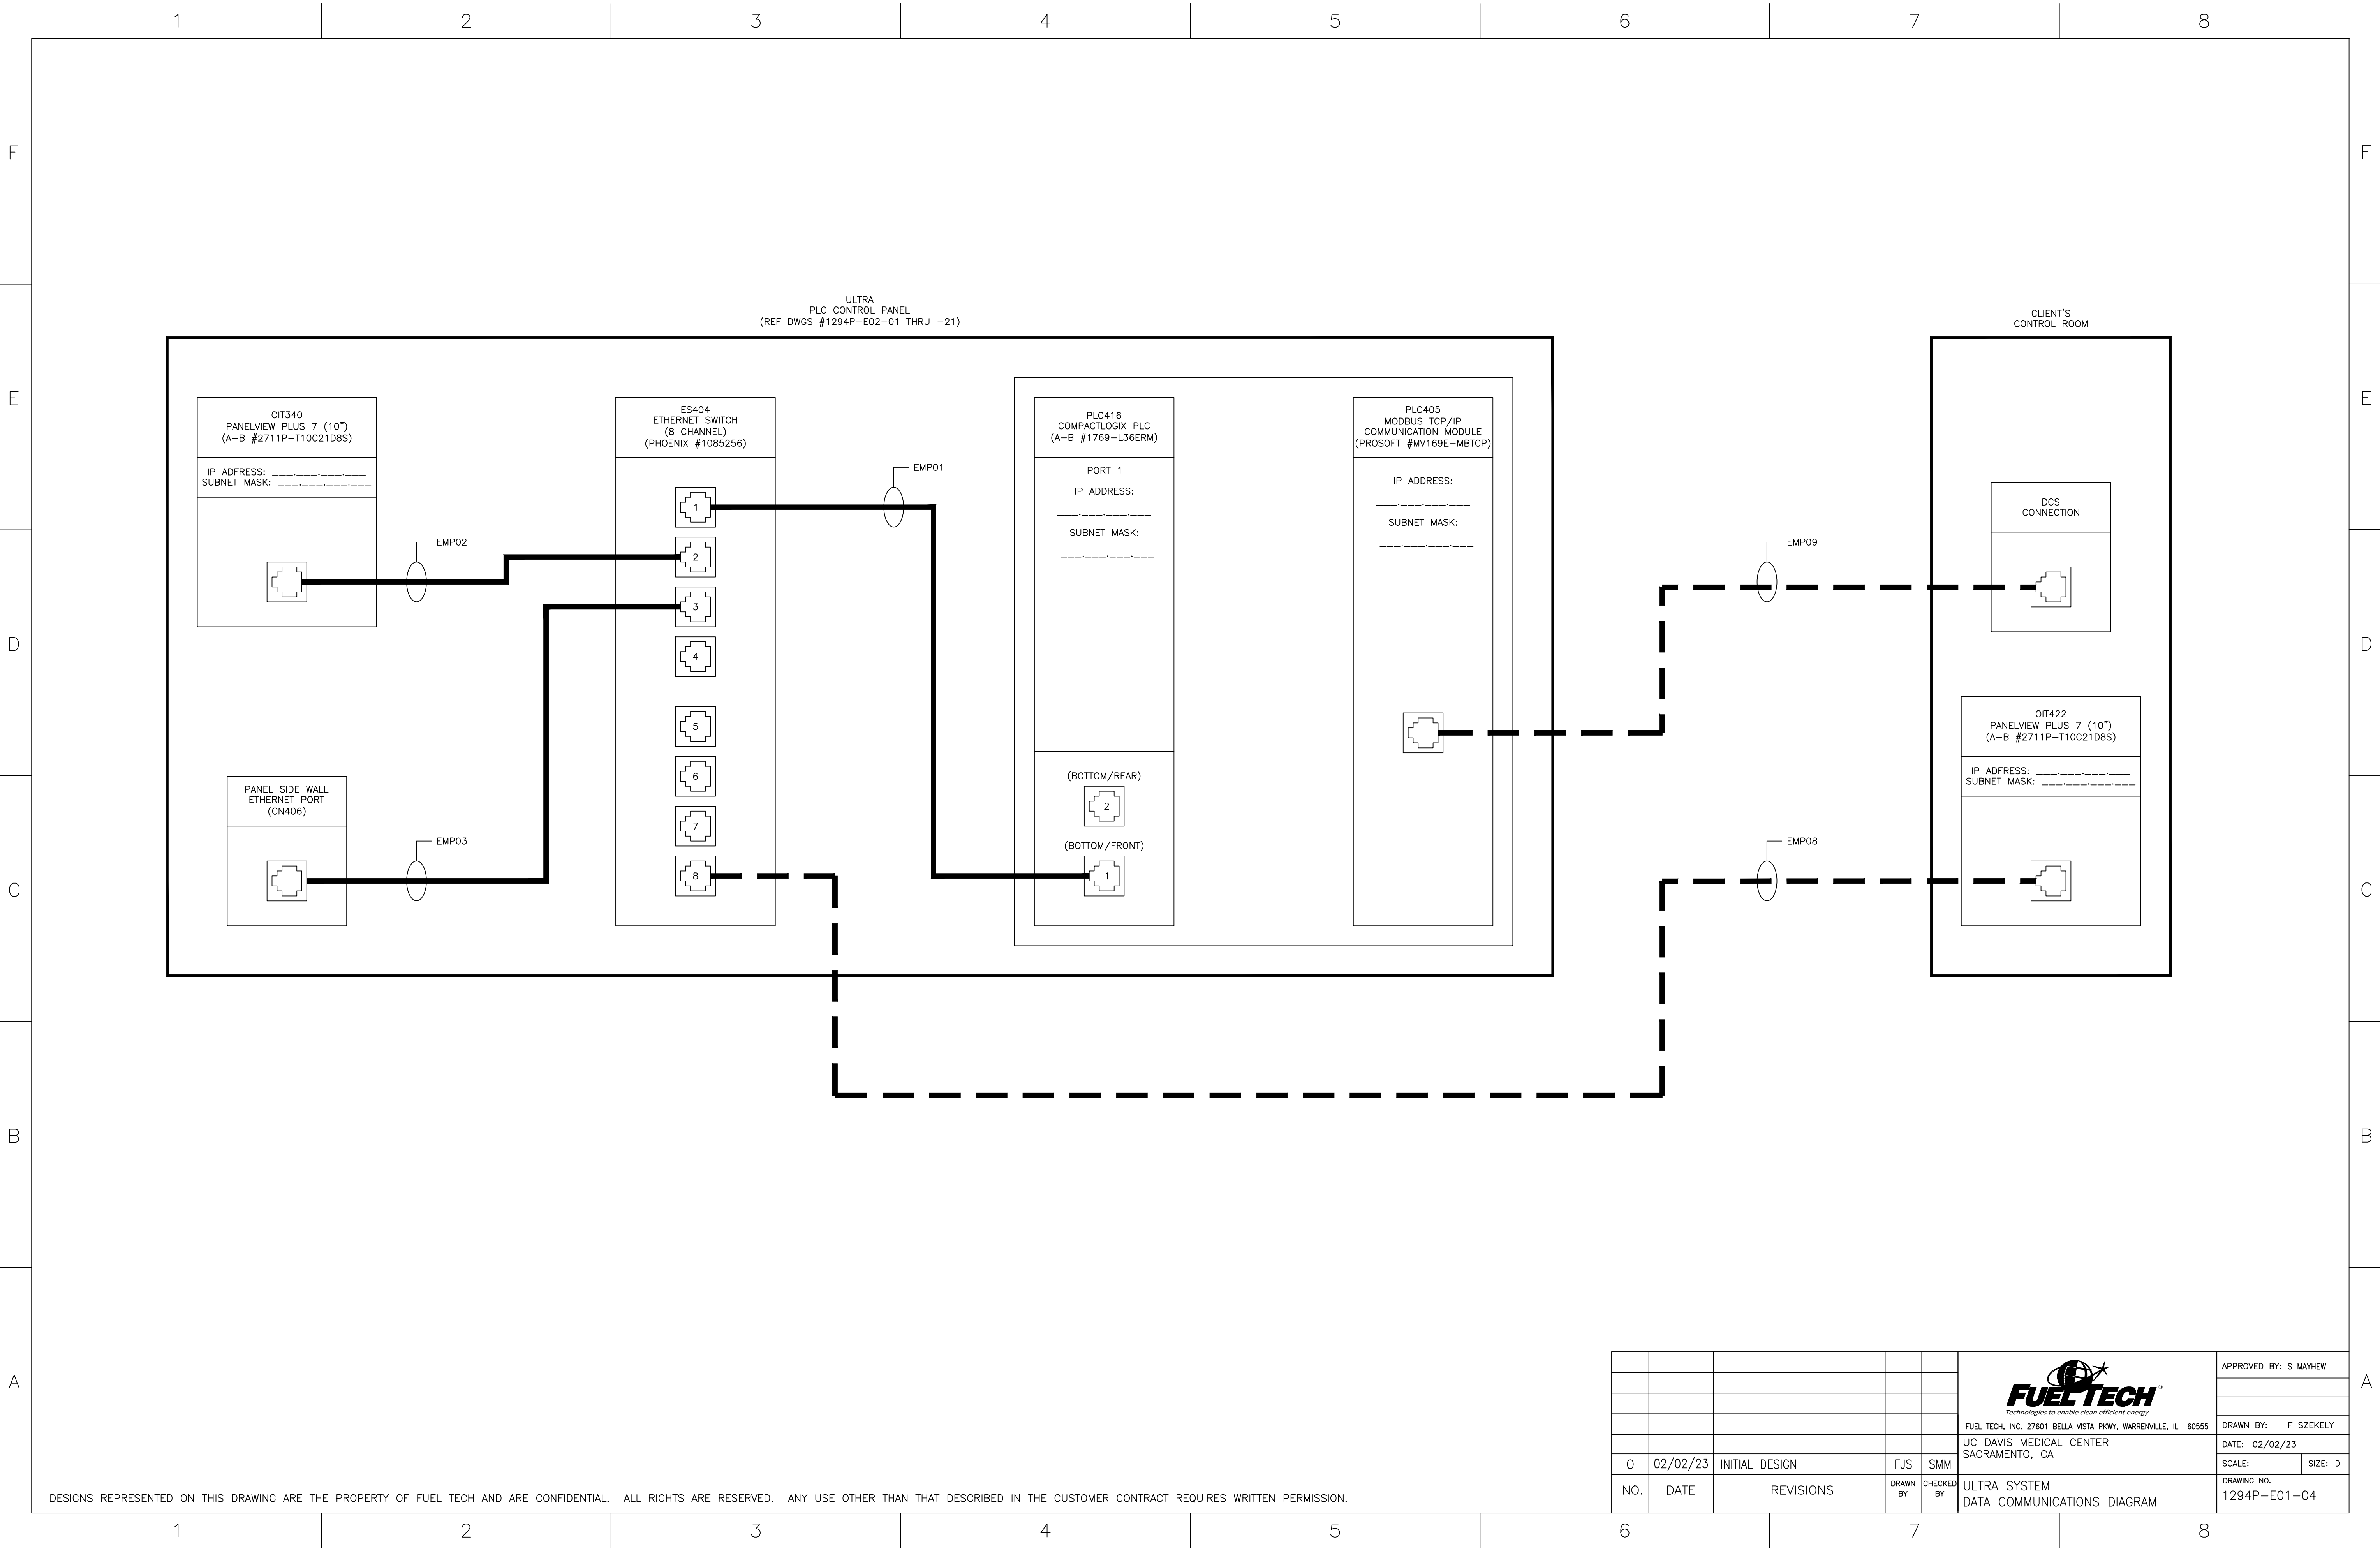

F

E

D

C

B

A

INSTRUMENT IDENTIFICATION TABLE

FIRST LETTER			SUCCEEDING LETTERS		
	MEASURED OR INITIATING VARIABLE	MODIFIER	READOUT OR PASSIVE FUNCTION	OUTPUT FUNCTION	MODIFIER
A	ANALYSIS		ALARM		
B	BURNER, COMBUSTION		USER'S CHOICE	USER'S CHOICE	USER'S CHOICE
C	CONDUCTIVITY			CONTROL	CLOSED
D	DENSITY	DIFFERENTIAL			DIVERT
E	VOLTAGE		SENSOR (PRIMARY ELEMENT)		
F	FLOW RATE	RATIO (FRACTION)			FORWARD
G	USER'S CHOICE		GLASS, VIEWING DEVICE		
H	HAND				HIGH, OPEN
I	CURRENT (ELECTRIC)		INDICATE		
J	POWER	SCAN			
K	TIME, TIME SCHEDULE	TIME RATE OF CHANGE		CONTROL STATION	
L	LEVEL		LIGHT		LOW, CLOSED
M	USER'S CHOICE	MOMENTARY			MIDDLE, INTERMEDIATE
N	USER'S CHOICE		USER'S CHOICE	USER'S CHOICE	USER'S CHOICE
O	USER'S CHOICE		ORIFICE, RESTRICTION		OPEN
P	PRESSURE, VACUUM		POINT (TEST) CONNECTION		
Q	QUANTITY	INTEGRATE, TOTALIZE			
R	RADIATION		RECORD		REVERSE
S	SPEED, FREQUENCY	SAFETY		SWITCH	
T	TEMPERATURE			TRANSMIT	
U	MULTIVARIABLE		MULTIFUNCTION	MULTIFUNCTION	MULTIFUNCTION
V	VIBRATION, MECHANICAL ANALYSIS			VALVE, DAMPER, LOUVER	
W	WEIGHT, FORCE		WELL		
X	UNCLASSIFIED	X AXIS	UNCLASSIFIED	UNCLASSIFIED	UNCLASSIFIED
Y	EVENT, STATE OR PRESENCE	Y AXIS		RELAY, COMPUTE, CONVERT	
Z	POSITION, DIMENSION	Z AXIS		DRIVER, ACTUATOR, UNCLASSIFIED FINAL CONTROL ELEMENT	


SYSTEM CODES

AA — ANHYDROUS AMMONIA
AHC — ACOUSTIC HORN CLEANER
AW — AQUEOUS AMMONIA (19%)
CA — COMBUSTION AIR
CW — COOLING WATER
DW — DILUTION WATER
DA — DILUTION AIR
FW — FLUSH WATER
DAG — DILUTE AMMONIA GAS
HA — HERT AIR
IA — INSTRUMENT AIR
NG — NATURAL GAS

OFA — SECONDARY/TERTIARY AIR
OIL — OIL
PA — PRIMARY AIR
PC — PULVERIZED COAL
PW — PROCESS WATER
SA — SERVICE AIR
SB — SOOT BLOWER
UE — UREA (SOLUTION)
UED — UREA PRILL, DRY
FG — FLUE GAS
OX — OXYGEN

COMPONENT TAGGING

XX — UNIT (OPT'L)
AAA — DEVICE/EQUIP/COMPONENT
XXX — SYSTEM (UE/DW)

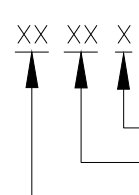


EXAMPLE: 01-P-UE-0101A
OPTIONAL FOR DUPLEX/REDUNDANT "A", "B" OR SERIES LOOP
UNIQUE ID

DEVICE/EQUIPMENT INITIALS

AC — ACCUMULATOR
AG — AGITATOR/MIXER
AH — SONIC HORN
B — BLOWER
DI — DIAPHRAGM ISOLATOR
EJ — EXPANSION JOINT
FIL — FILTER
H — HEATER
TDL — TUNABLE DIODE LASER
PRB — PROBE
PD — PULSATION DAMPENER

INJ — INJECTOR
LPA — LARGE PARTICLE ASH SCREEN
M — MOTOR
MX — STATIC MIXER
P — PUMP
SCW — SCREW CONVEYOR
SIL — SILENCER
STR — STRAINER
TNK — TANK
CYC — CYCLONE
C — COMPRESSOR
V — VESSEL

INSTRUMENT TAGGING

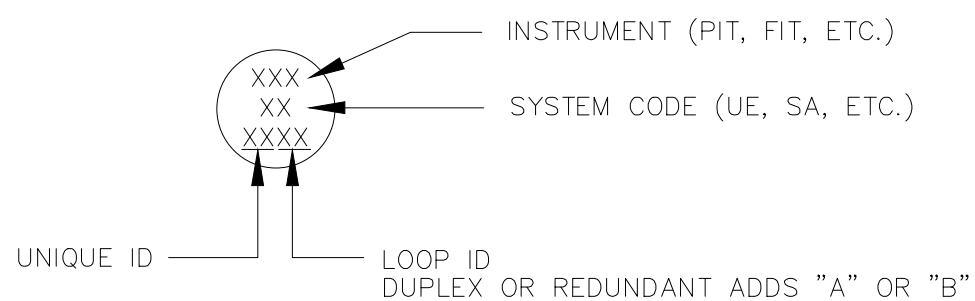

VALVE CODES


SYM — DEFINITION

AOV — AIR-OPERATED VALVE
BPRV — BACK PRESSURE REGULATOR VALVE
CV — CHECK VALVE
FCV — FLOW CONTROL VALVE
HV — HAND VALVE
MOV — MOTOR-OPERATED VALVE
NC — NORMALLY CLOSED
PCV — PRESSURE CONTROL VALVE
PRV — PRESSURE REGULATOR VALVE
ROV — ROTARY VALVE
RV — RELIEF VALVE
SOV — SOLENOID-OPERATED VALVE
VB — VACUUM BREAKER


VALVE SYMBOLS

TYPE	OPEN	CLOSED
BALL		
GATE		
GLOBE		
PLUG		
NEEDLE		
BUTTERFLY		
KNIFE GATE		
PRESSURE RELIEF		
CHECK		
3-WAY		
4-WAY		
ROTARY		
PRESSURE REGULATOR (INTERNAL, DOWNSTREAM)		
PRESSURE REGULATOR (INTERNAL, BACKPRESSURE)		

CONTROL VALVE ACTUATORS

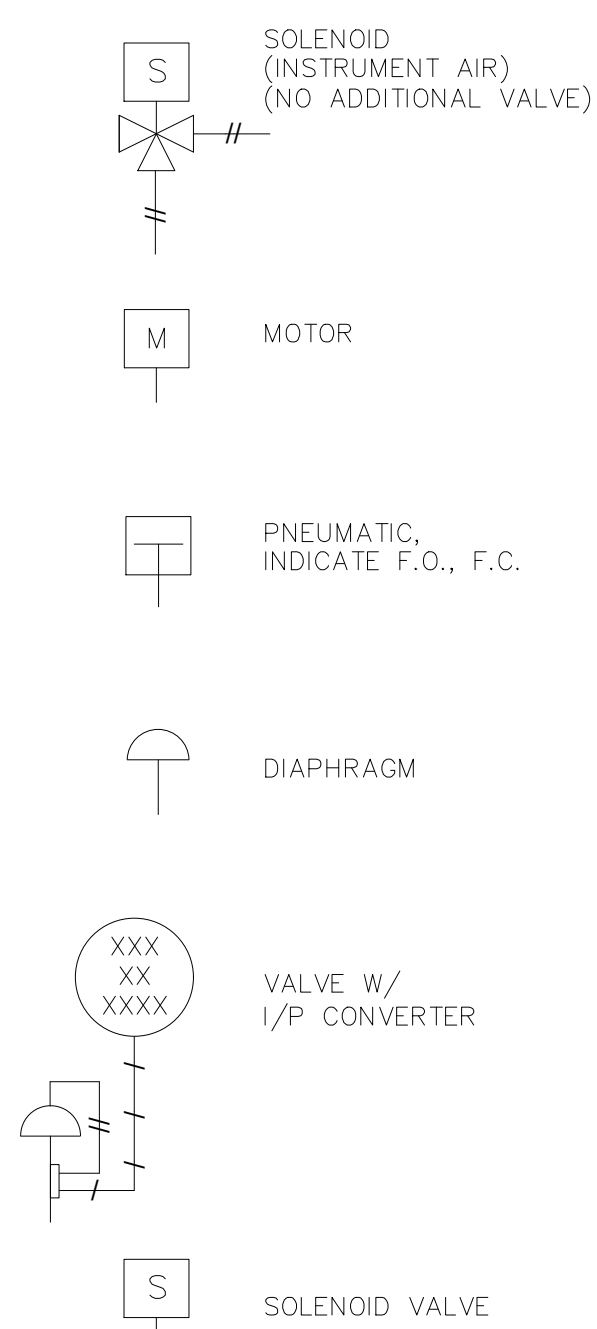


INSTRUMENT SYMBOLS

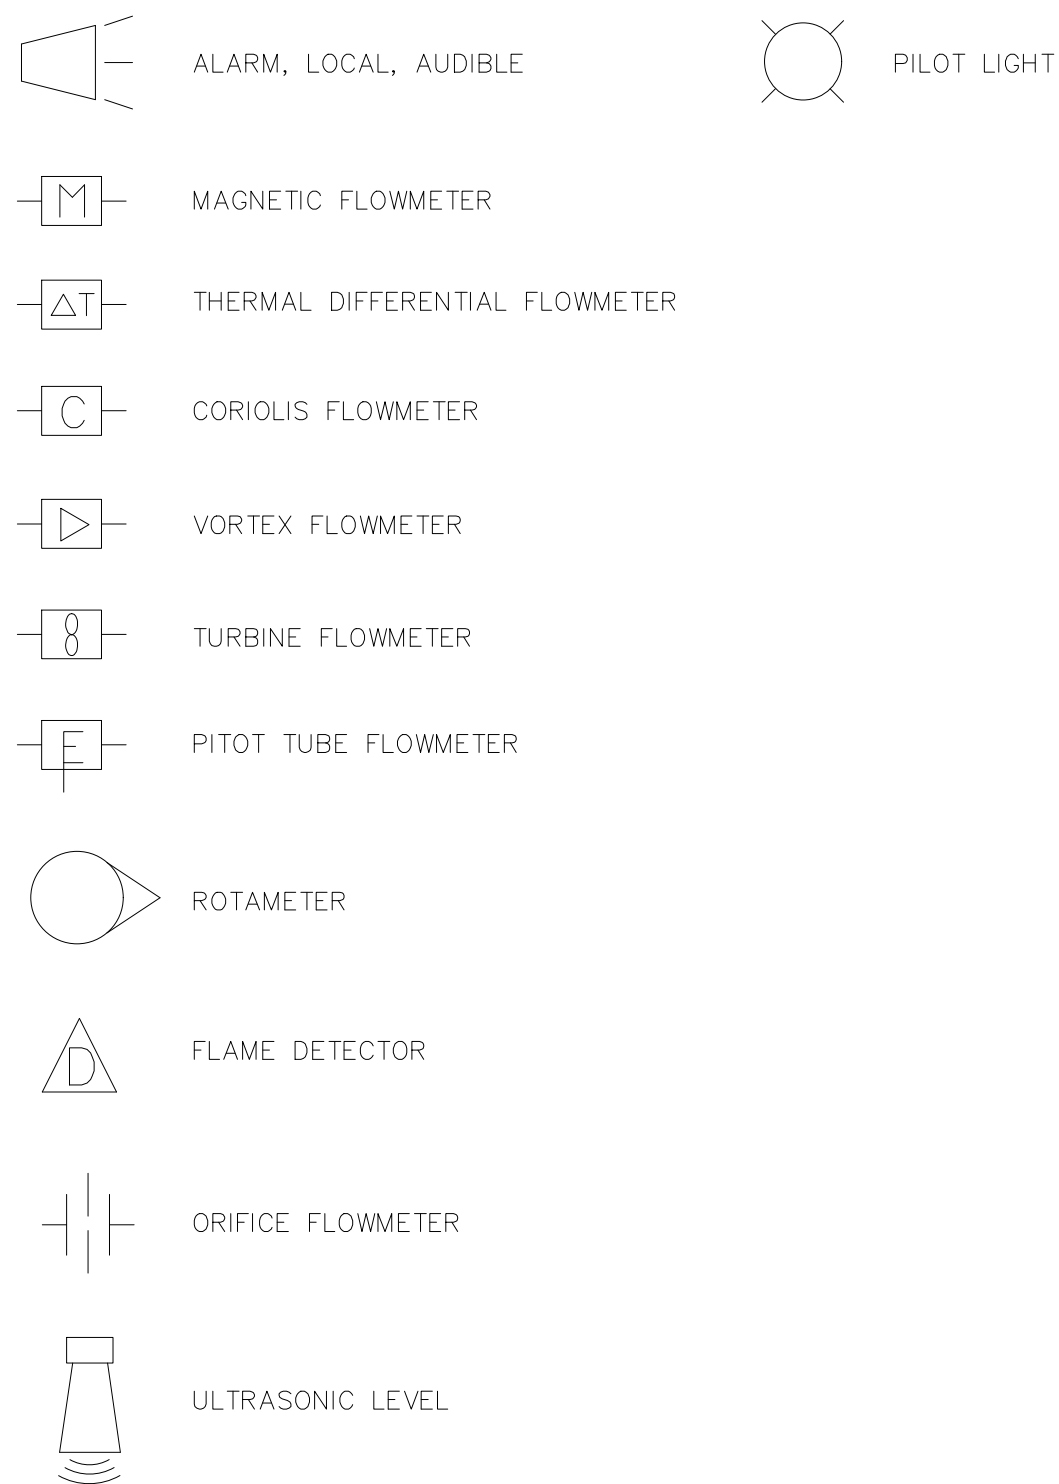


INSTRUMENTS

	FIELD MOUNT	PRIMARY LOCATION NORMALLY ACCESSIBLE TO OPERATOR	AUXILIARY LOCATION NORMALLY ACCESSIBLE TO OPERATOR	PRIMARY LOCATION NORMALLY INACCESSIBLE TO OPERATOR	AUXILIARY LOCATION NORMALLY INACCESSIBLE TO OPERATOR
DISCRETE					
SHARED DISP. SHARED CONTROL					


LINE SYMBOLS

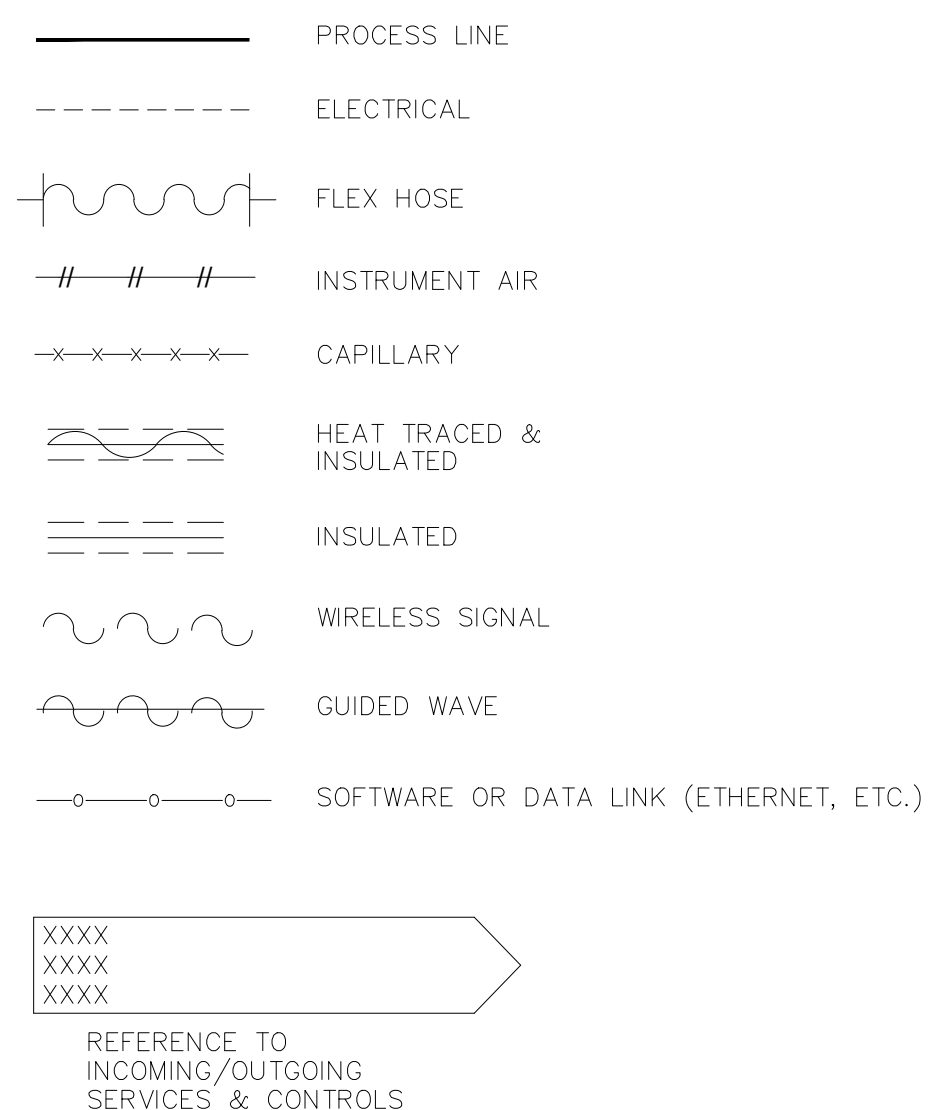


EQUIPMENT

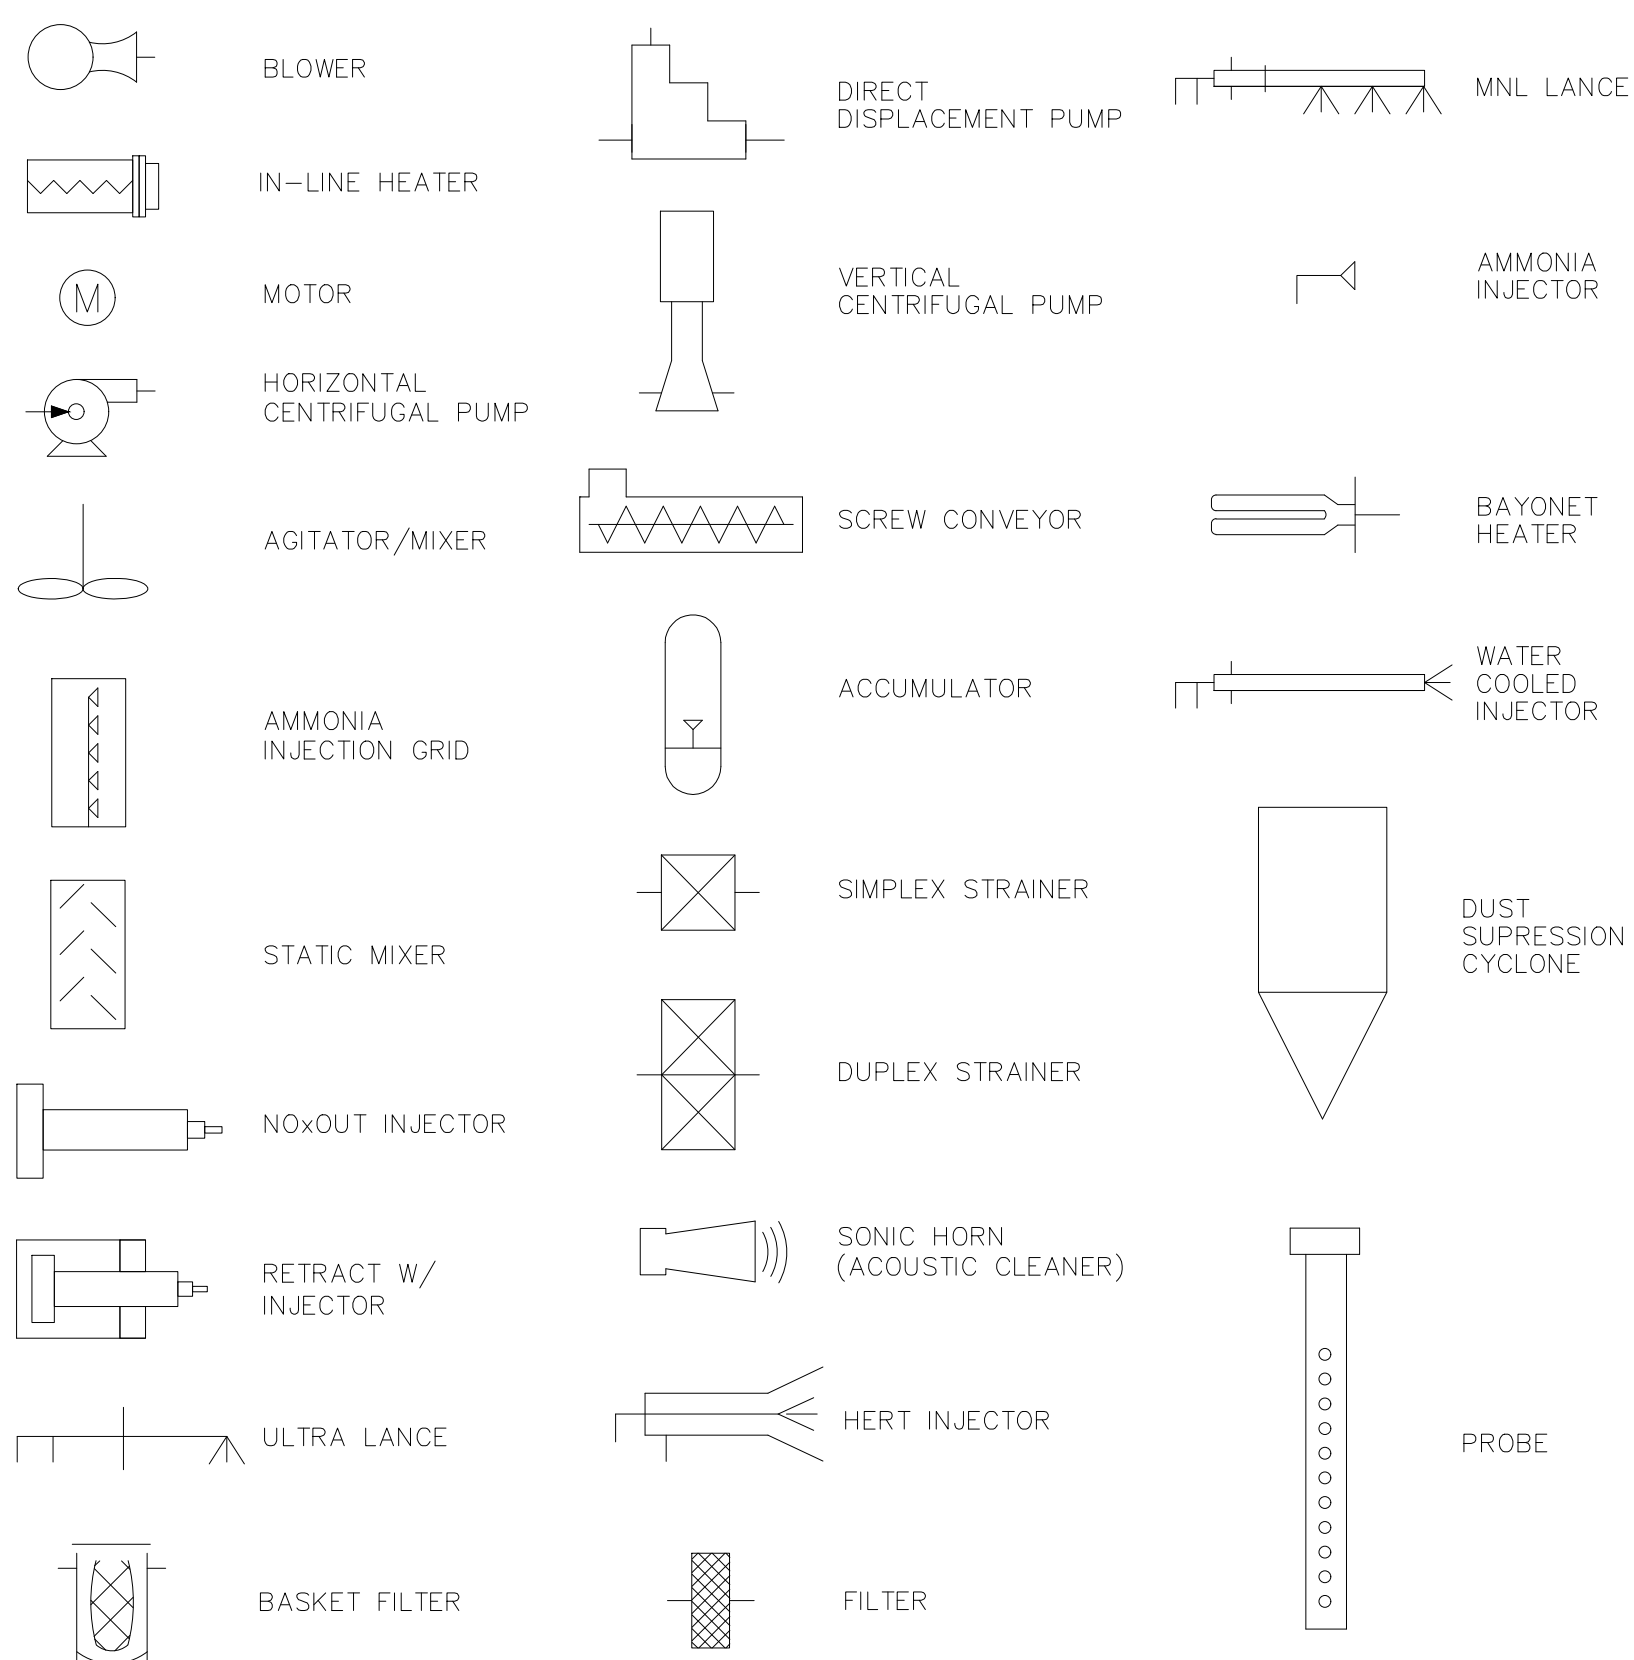

PIPING SPECIALTIES

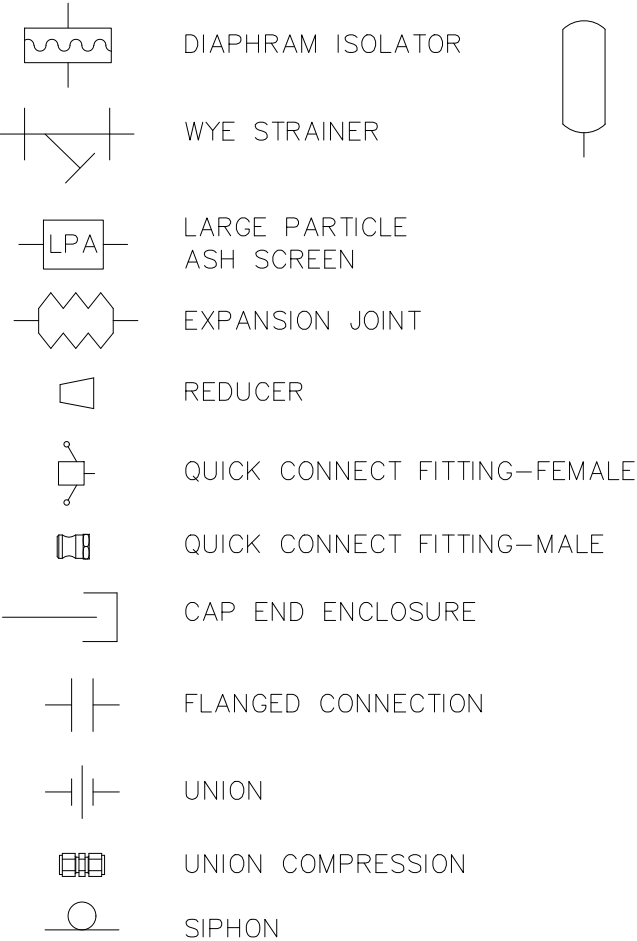

MISC. SYMBOLS

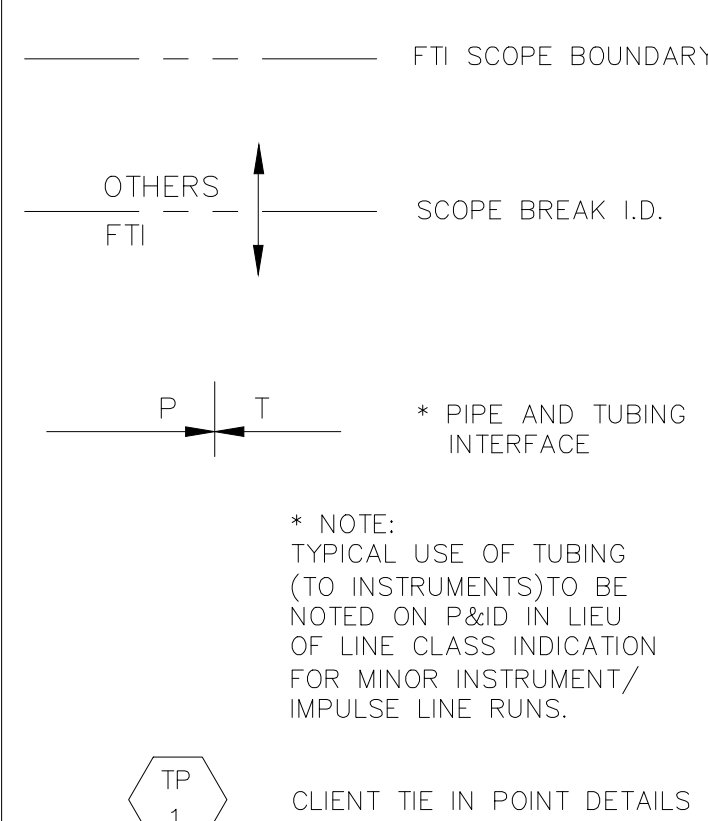

PIPE LINE CLASS

LINE CLASS:

SS1	SCH. 10S, GR. 304L, WITH 150# CLASS FITTINGS
SS2	SCH. 40S, GR. 304L, WITH 150# CLASS FITTINGS
SS3	SCH. 40S, GR. 304L, WITH 300# CLASS FITTINGS
SS4	SCH. 40S, GR. 316L, WITH 150# CLASS FITTINGS
SS5	SCH. 40S, GR. 316L, WITH 300# CLASS FITTINGS
CS1	SCH. 40, CARBON STEEL, 150# CLASS FITTINGS
CS2	SCH. 80, CARBON STEEL, 150# CLASS FITTINGS
CS3	SCH. 40, CARBON STEEL, 300# CLASS FITTINGS
CS4	SCH. 80, CARBON STEEL, 300# CLASS FITTINGS
TB1	TUBING, 316L, 0.9mm (0.035") WALL THICKNESS
TB2	TUBING, 316L, 1.2mm (0.049") WALL THICKNESS
TB3	TUBING, POLYURETHANE, 0.063" WALL THICKNESS
FRP1	SCH. 40 FRP PIPE
DUCT	DUCTWORK CONFORMING TO + XX/- XX PRESSURE RATING
CPVC	SCH. 80 CPVC
PVC	SCH. 80 PVC



FUEL TECH, INC. 27601 BELLA VISTA PKWY, WARRENVILLE, IL 60555

UC DAVIS MEDICAL CENTER

APPROVED BY: K. KRAUSE
CHECKED BY: A. TOPACIO
DRAWN BY: M. HARTMAN

DATE: 6/20/2022

SCALE: NONE SIZE: D

DRAWING NO.
1294P-M02-01-R0

F


E


D

C


B

A

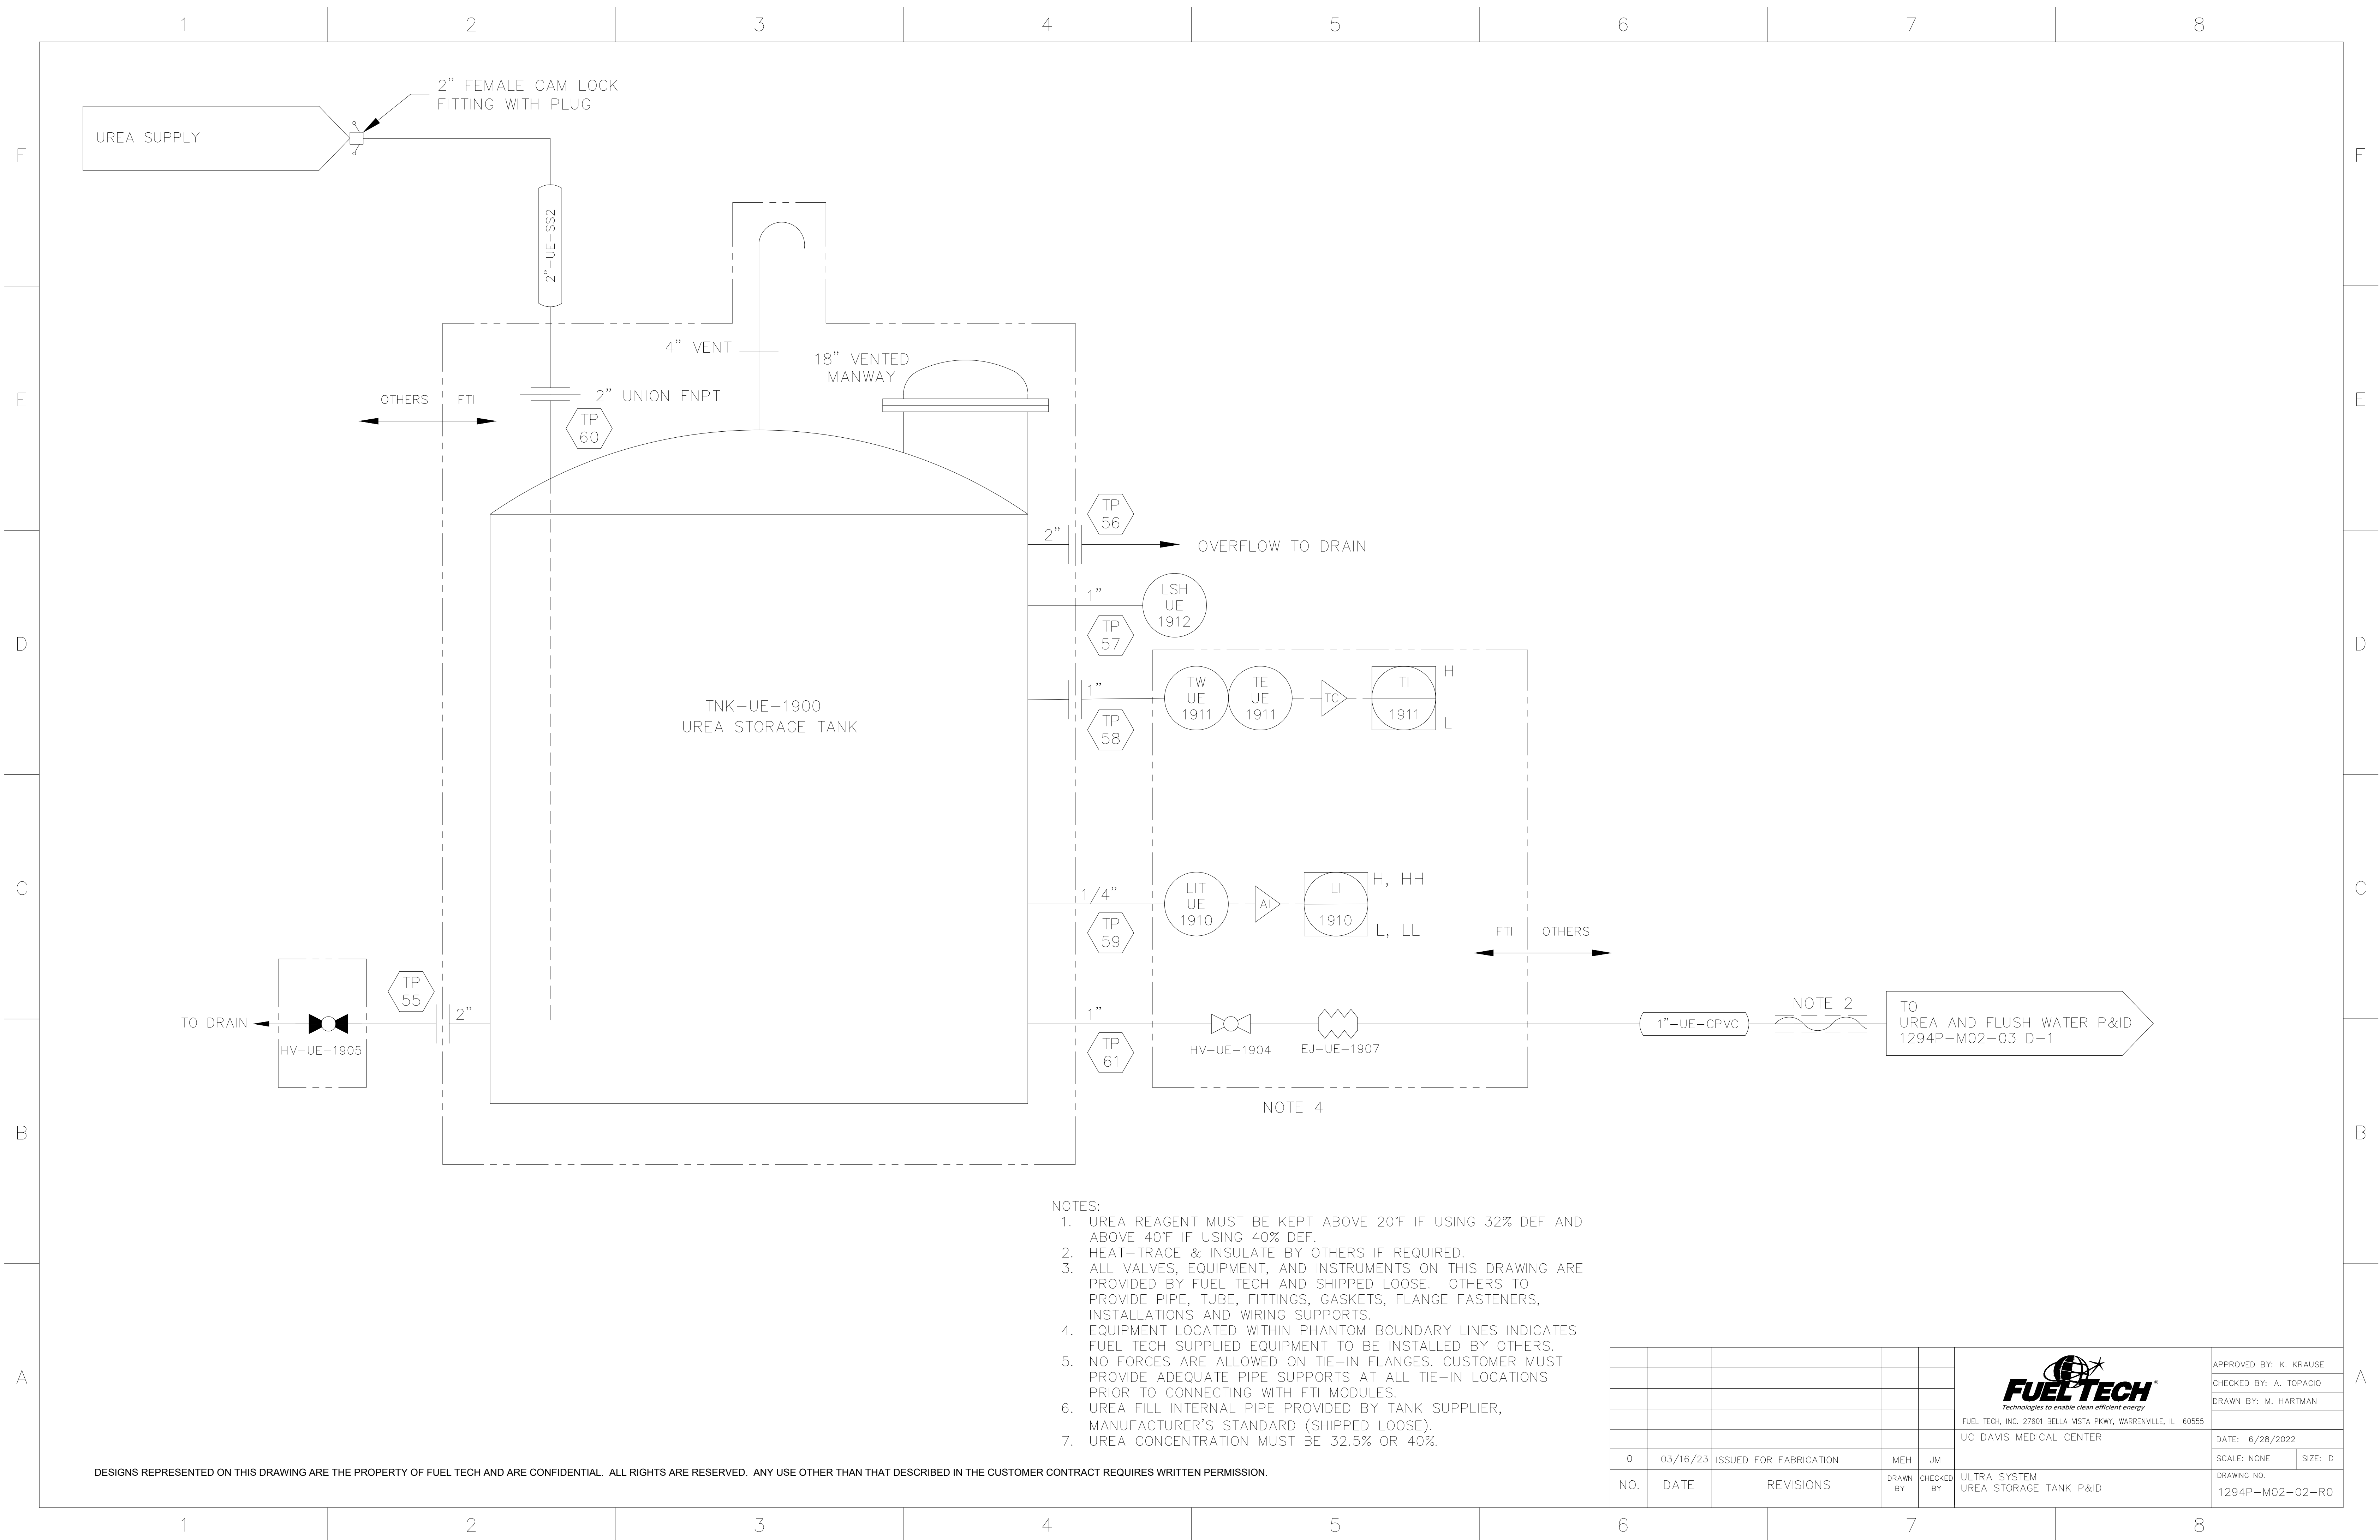

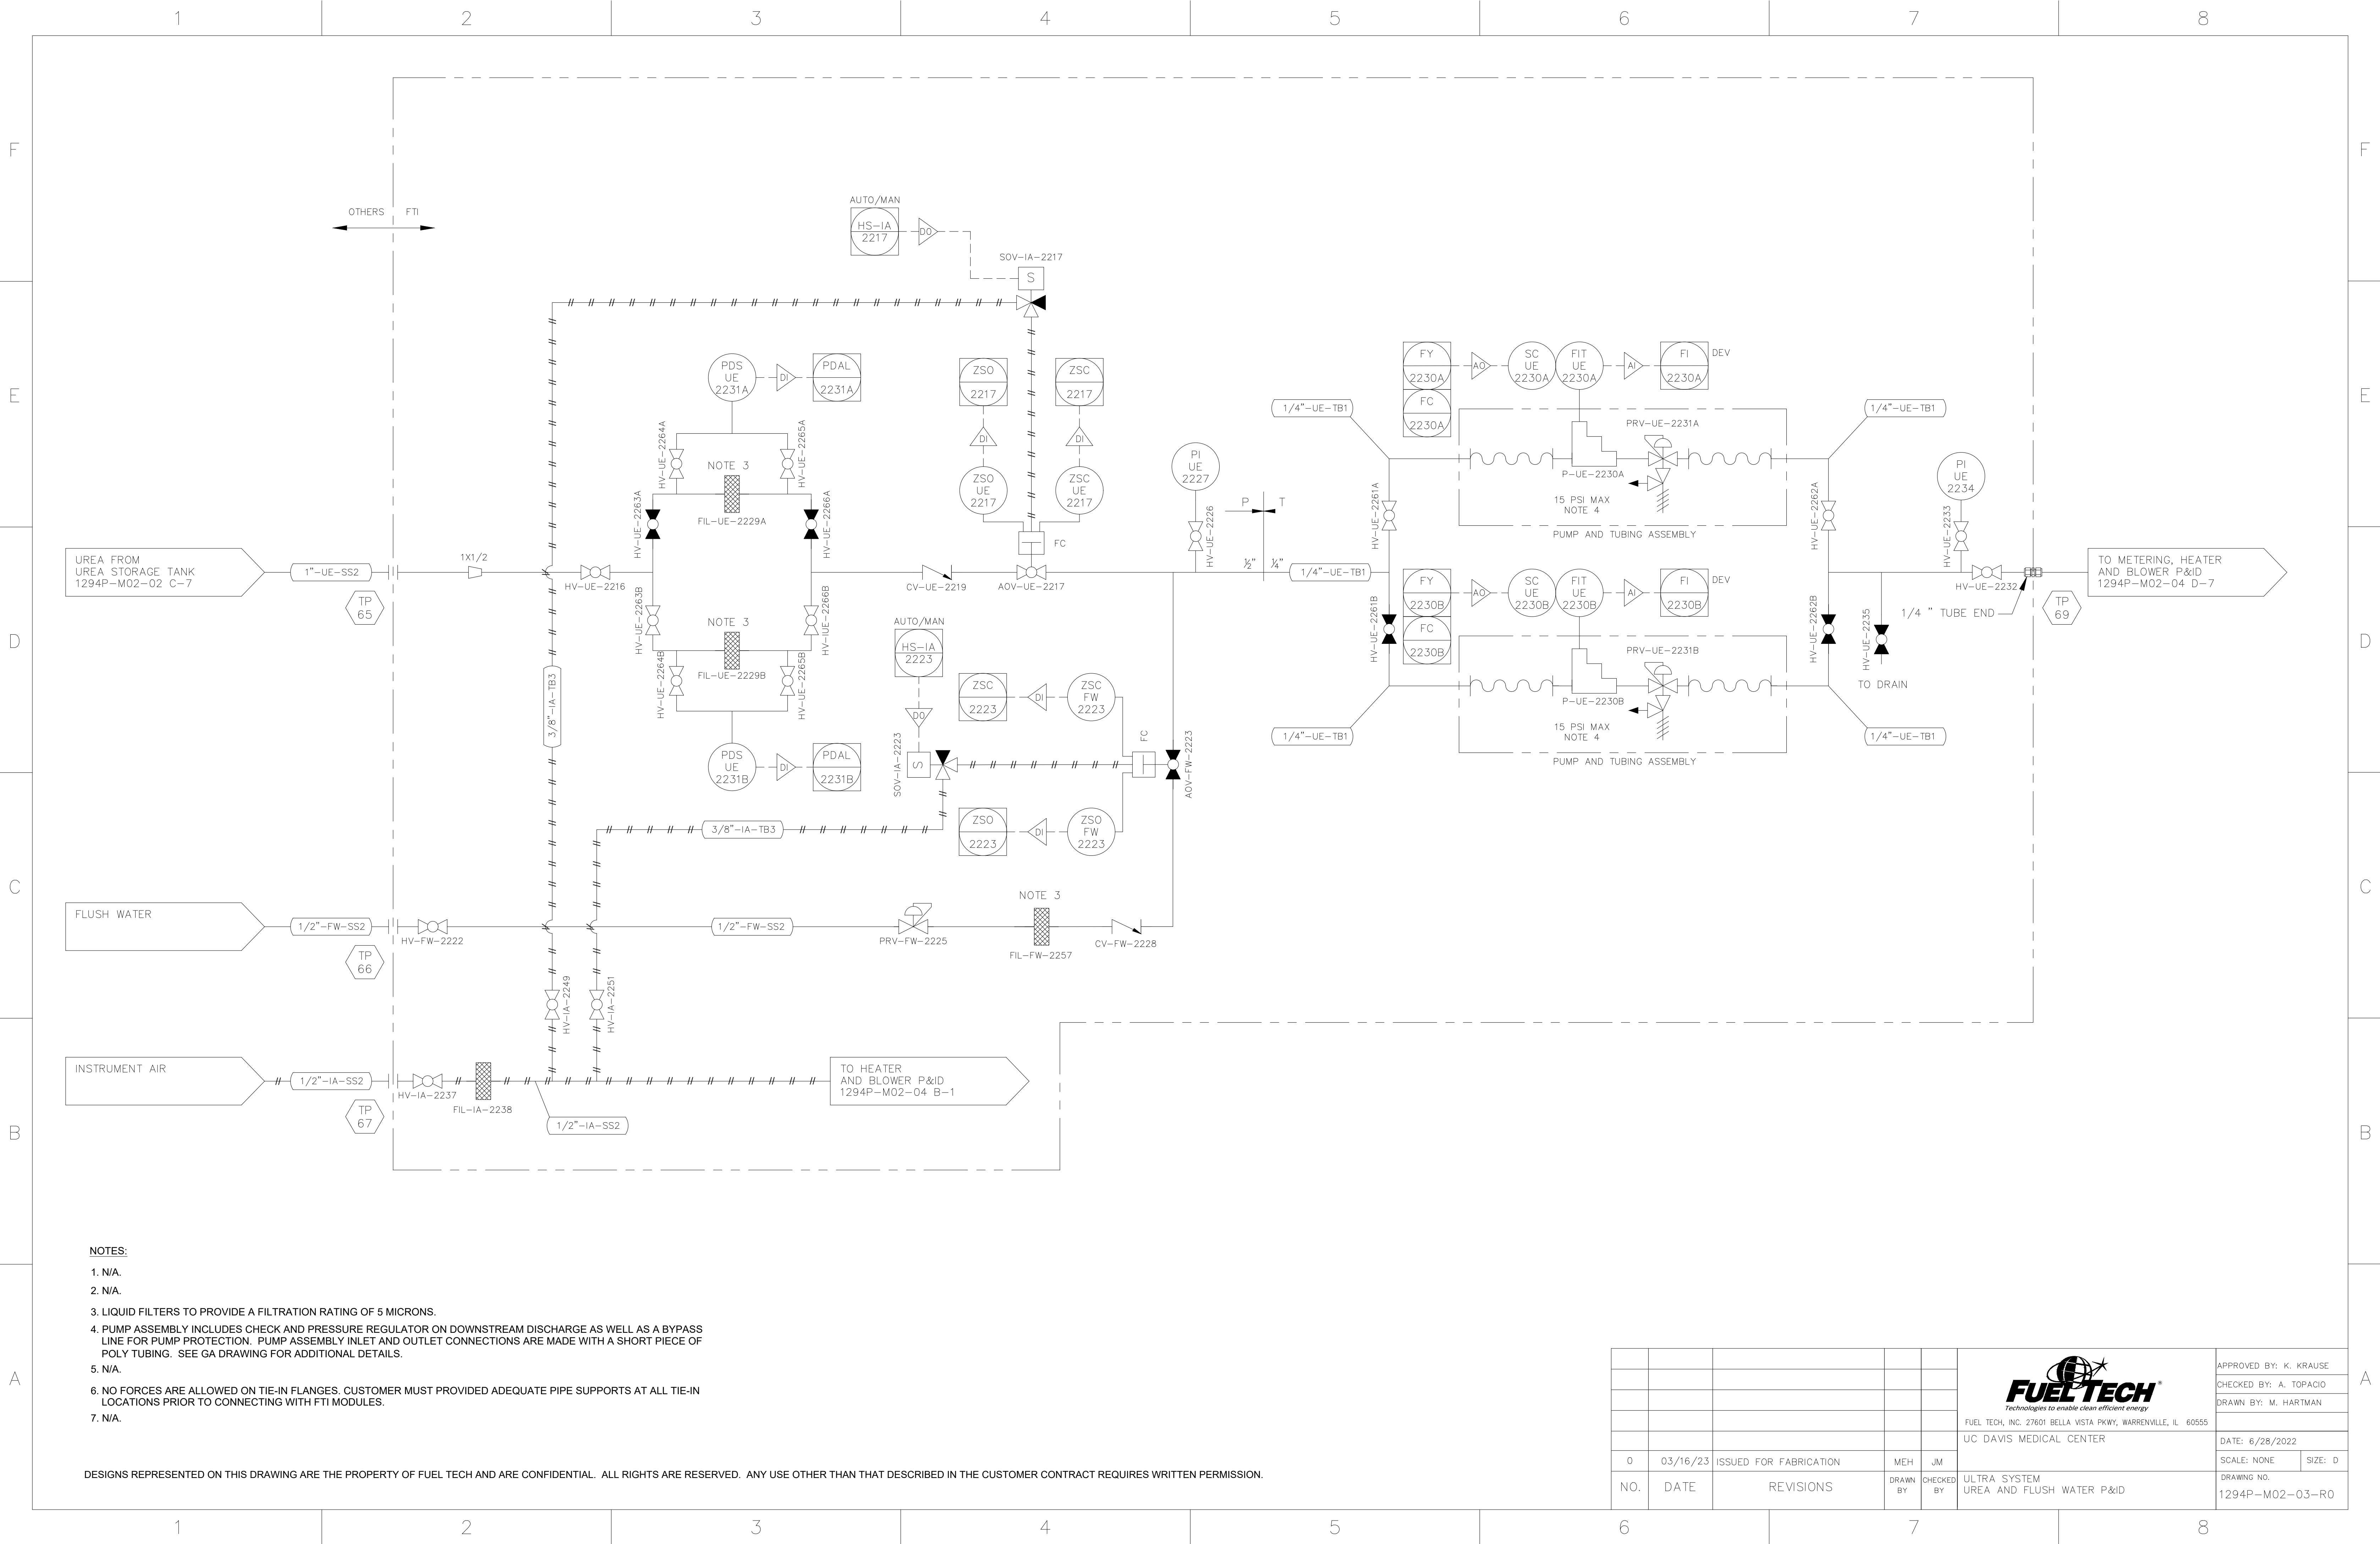


PARTS LIST		
ITEM	TAG	DESCRIPTION
1	PDS-UE-2231B	DIFFERENTIAL PRESSURE SWITCH 1/4" FNPT HIGH/LOW
2	PDS-UE-2231A	DIFFERENTIAL PRESSURE SWITCH 1/4" FNPT HIGH/LOW
3	EJ-DA-2261A	EXPANSION JOINT 4"
4	EJ-DA-2261B	EXPANSION JOINT 4"
5	EJ-DA-2261C	EXPANSION JOINT 4"
6	FIL-UE-2229B	FILTER 1/2"
7	FIL-FW-2257	FILTER 1/2"
8	FIL-UE-2229A	FILTER 1/2"
9	FIL-IA-2238	FILTER 1/2"
10	FIT-IA-2244	FLOW METER 1/2"
11	H-DA-2255C	HEATER 4" X 4"
12	H-DA-2255A	HEATER 4" X 4"
13	H-DA-2255B	HEATER 4" X 4"
14		HEATER PANEL 60" x 58" x 18"
15	OR-DA-2224C	ORIFICE PLATE 4" X 2 1/2" BORE
16	OR-DA-2224A	ORIFICE PLATE 4" X 2 1/2" BORE
17	OR-DA-2224B	ORIFICE PLATE 4" X 2 1/2" BORE
18		PLC PANEL 60" x 36" x 16"
19	PI-UE-2234	PRESSURE GAUGE 1/2"
20	PI-UE-2227	PRESSURE GAUGE 1/2"
21	PI-IA-2242	PRESSURE GAUGE 1/2"
22	PI-DA-2215A	PRESSURE GAUGE 1/8" MAGNEHELIC
23	PI-DA-2260	PRESSURE GAUGE 1/8" MAGNEHELIC
24	PI-DA-2215C	PRESSURE GAUGE 1/8" MAGNEHELIC
25	PI-DA-2215B	PRESSURE GAUGE 1/8" MAGNEHELIC
26	PIT-DA-2208	PRESSURE TRANSMITTER
27	P-UE-2230B	PUMP 1/4" DOSING
28	P-UE-2230A	PUMP 1/4" DOSING
29	HV-DA-2207	VALVE 2 WAY 1/2"
30	AOV-FW-2223	VALVE AOV 1/2"
31	AOV-UE-2217	VALVE AOV 1/2"
32	HV-UE-2216	VALVE BALL 1/2"
33	HV-FW-2222	VALVE BALL 1/2"
34	HV-UE-2266A	VALVE BALL 1/2"
35	HV-UE-2263A	VALVE BALL 1/2"
36	HV-UE-2266B	VALVE BALL 1/2"
37	HV-UE-2263B	VALVE BALL 1/2"
38	HV-IA-2237	VALVE BALL 1/2"
39	HV-UE-2226	VALVE BALL 1/2"
40	HV-IA-2241	VALVE BALL 1/2"
41	HV-IA-2258	VALVE BALL 1/2"
42	HV-UE-2232	VALVE BALL 1/4" COMP
43	HV-UE-2262A	VALVE BALL 1/4" COMP
44	HV-UE-2262B	VALVE BALL 1/4" COMP
45	HV-UE-2261A	VALVE BALL 1/4" COMP
46	HV-UE-2235	VALVE BALL 1/4" COMP
47	HV-UE-2233	VALVE BALL 1/4" COMP
48	HV-UE-2261B	VALVE BALL 1/4" COMP
49	HV-UE-2265A	VALVE BALL 3/8" COMP
50	HV-UE-2264A	VALVE BALL 3/8" COMP
51	HV-DA-2218A	VALVE BALL 3/8" COMP
52	HV-DA-2218C	VALVE BALL 3/8" COMP
53	HV-DA-2218B	VALVE BALL 3/8" COMP
54	HV-DA-2210B	VALVE BALL 3/8" COMP
55	HV-DA-2210C	VALVE BALL 3/8" COMP
56	HV-IA-22451	VALVE BALL 3/8" COMP
57	HV-IA-2249	VALVE BALL 3/8" COMP
58	HV-DA-2210A	VALVE BALL 3/8" COMP
59	HV-UE-2264B	VALVE BALL 3/8" COMP
60	HV-UE-2265B	VALVE BALL 3/8" COMP
61	HV-PA-2259	VALVE BALL 3/8" COMP
62	HV-DA-2211B	VALVE BUTTERFLY 4"
63	HV-DA-2211A	VALVE BUTTERFLY 4"
64	HV-DA-2214B	VALVE BUTTERFLY 4"
65	HV-DA-2214A	VALVE BUTTERFLY 4"
66	HV-DA-2214C	VALVE BUTTERFLY 4"
67	HV-DA-2211C	VALVE BUTTERFLY 4"
68	CV-UE-2219	VALVE CHECK 1/2"
69	CV-FW-2228	VALVE CHECK 1/2"
70	PRV-IA-2239	VALVE PRV 1/2"
71	SOV-IA-2240	VALVE SOLENOID 1/2"

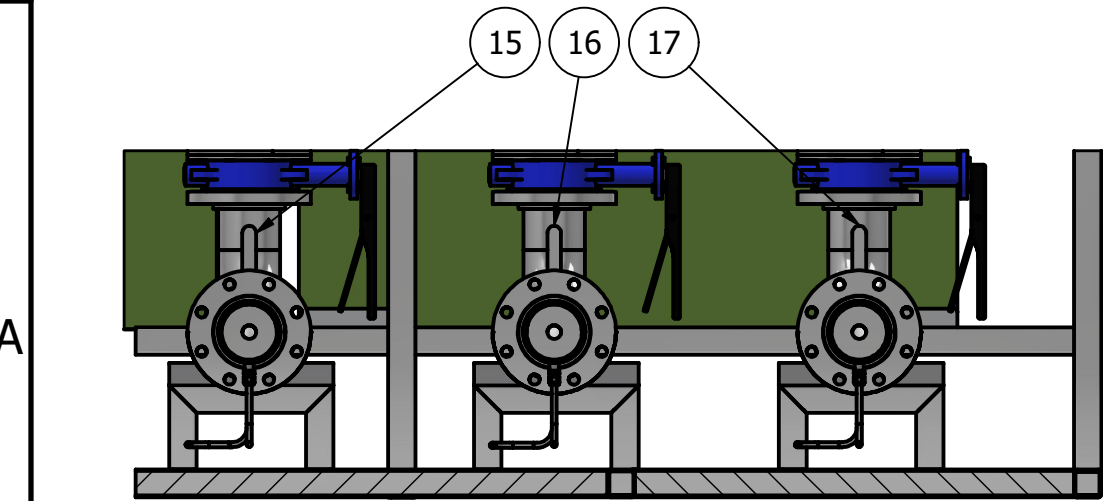


SECTION D-D



DESIGNS REPRESENTED ON THIS DRAWING ARE THE PROPERTY OF FUEL TECH AND ARE CONFIDENTIAL. ALL RIGHTS RESERVED. ANY USE OTHER THAN THAT DESCRIBED IN THE CUSTOMER CONTRACT REQUIRES WRITTEN PERMISSION.

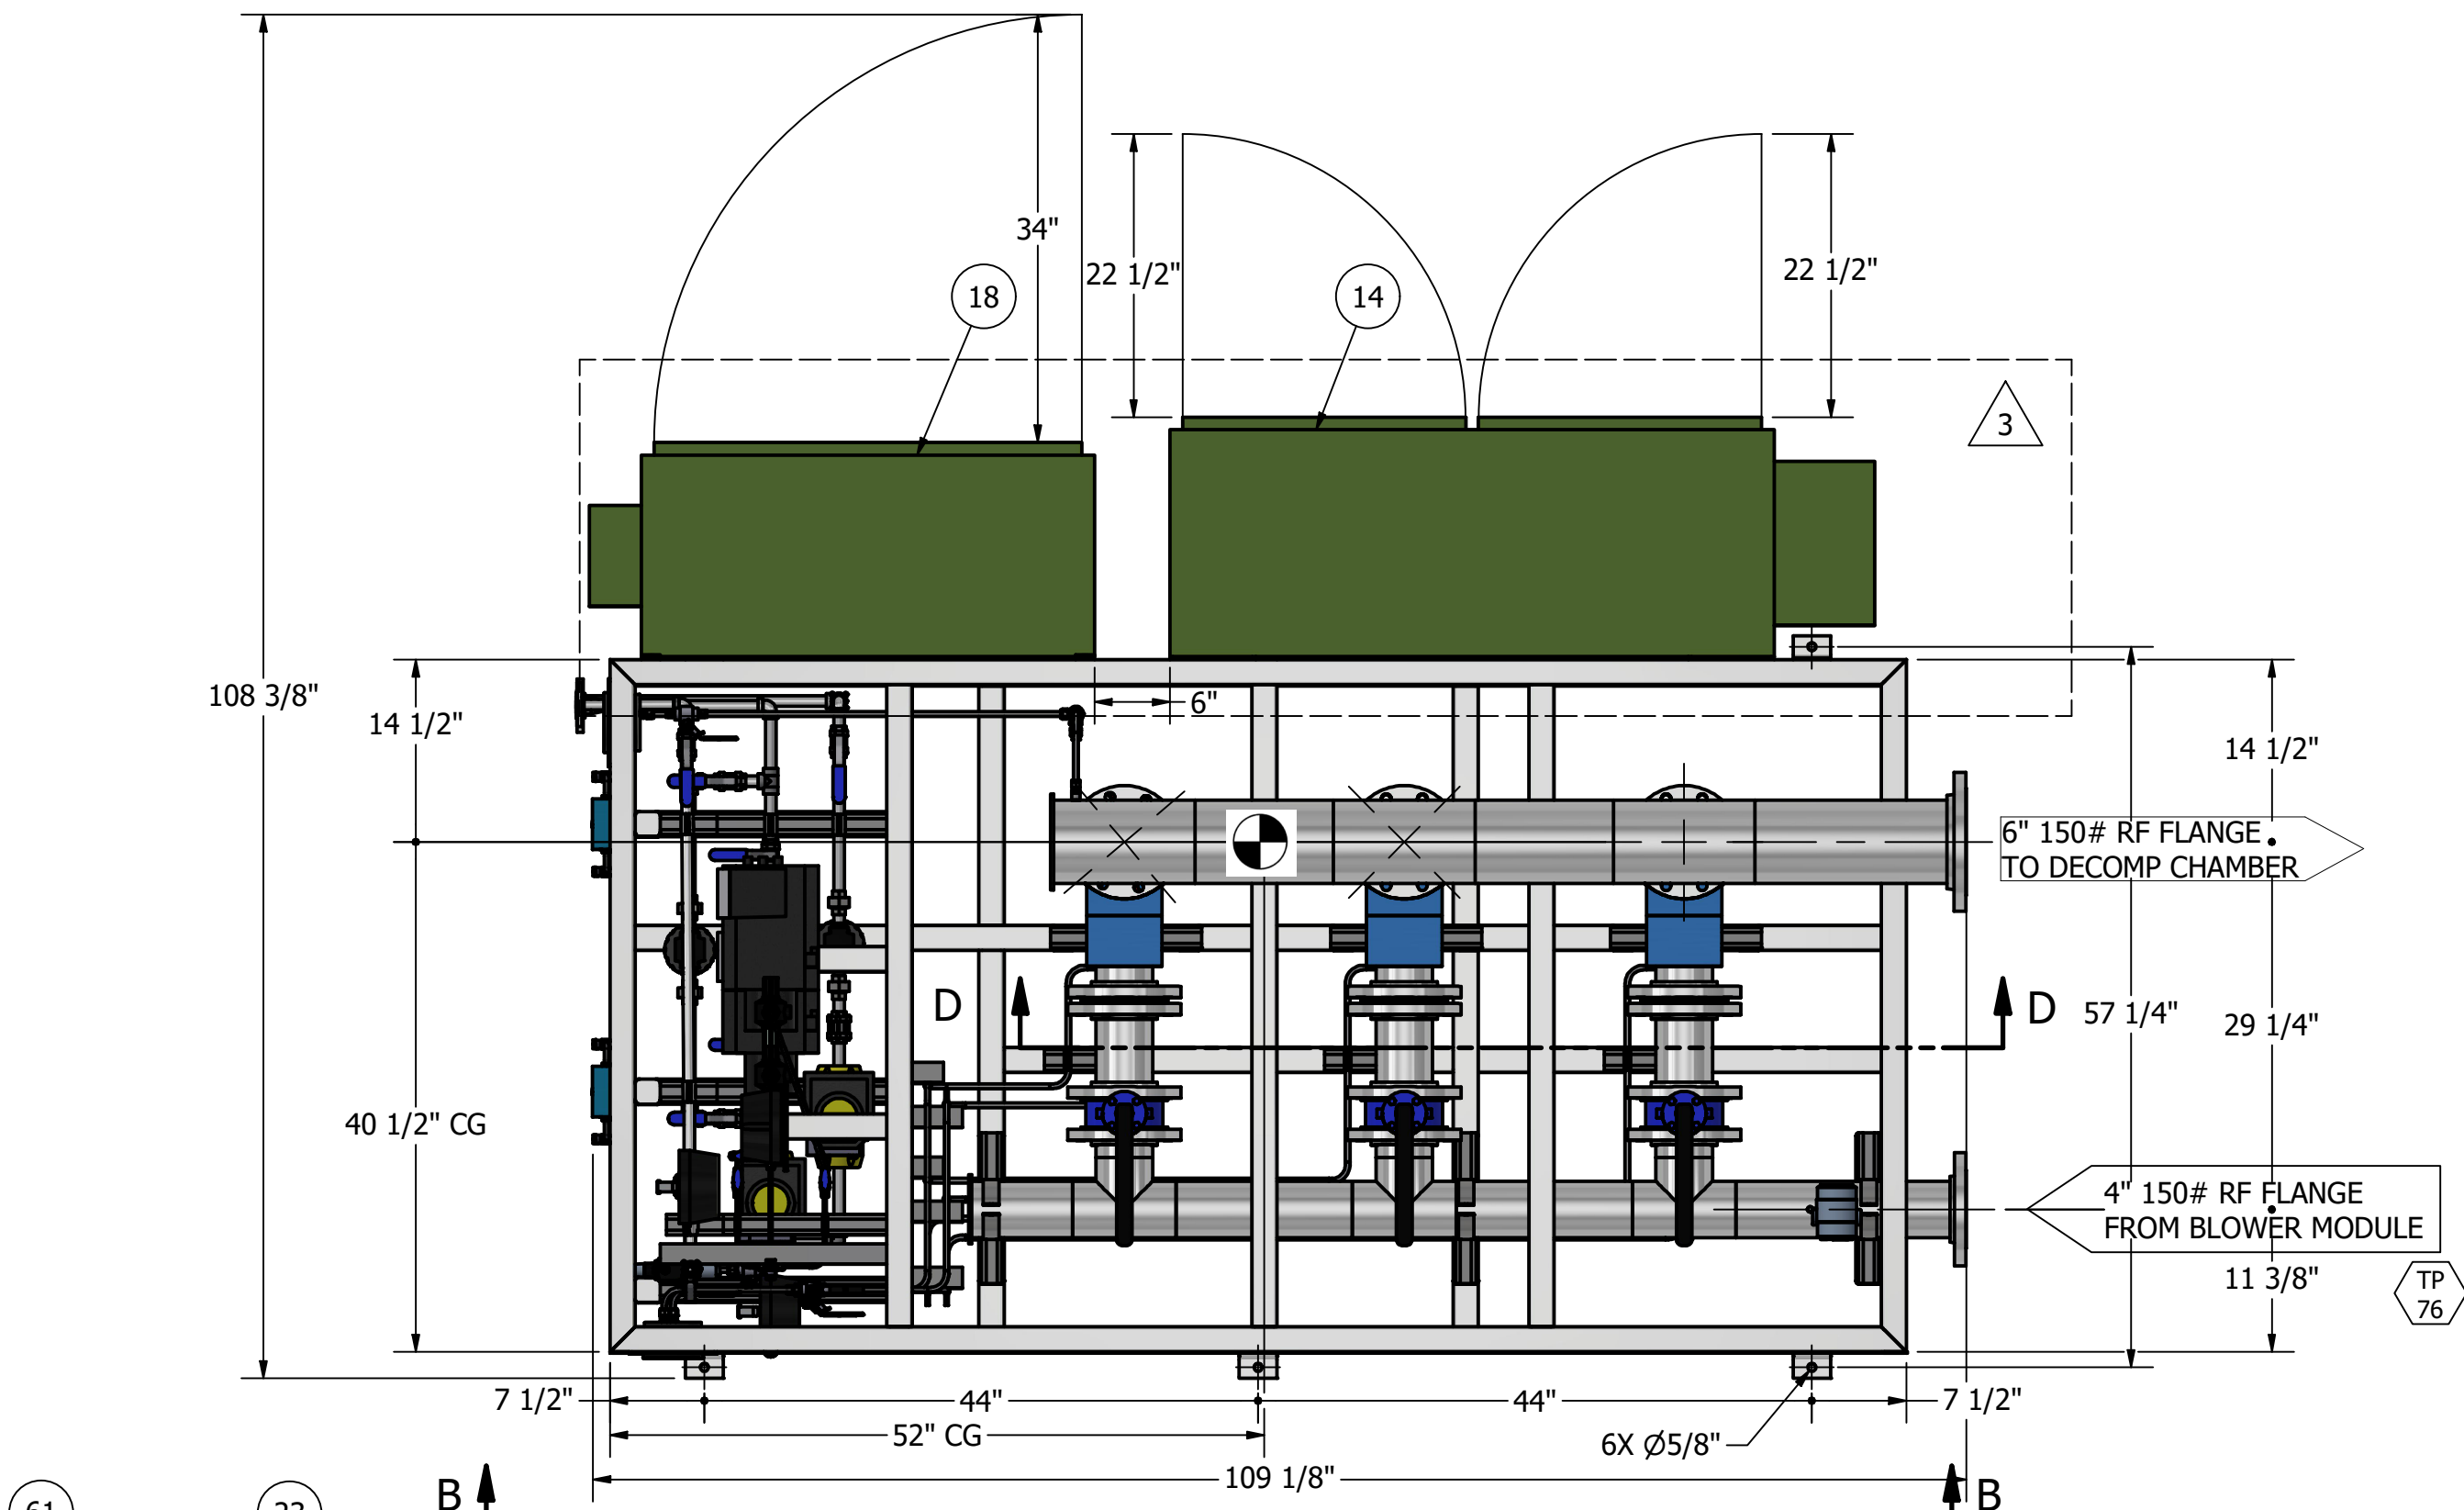

SECTION C-C

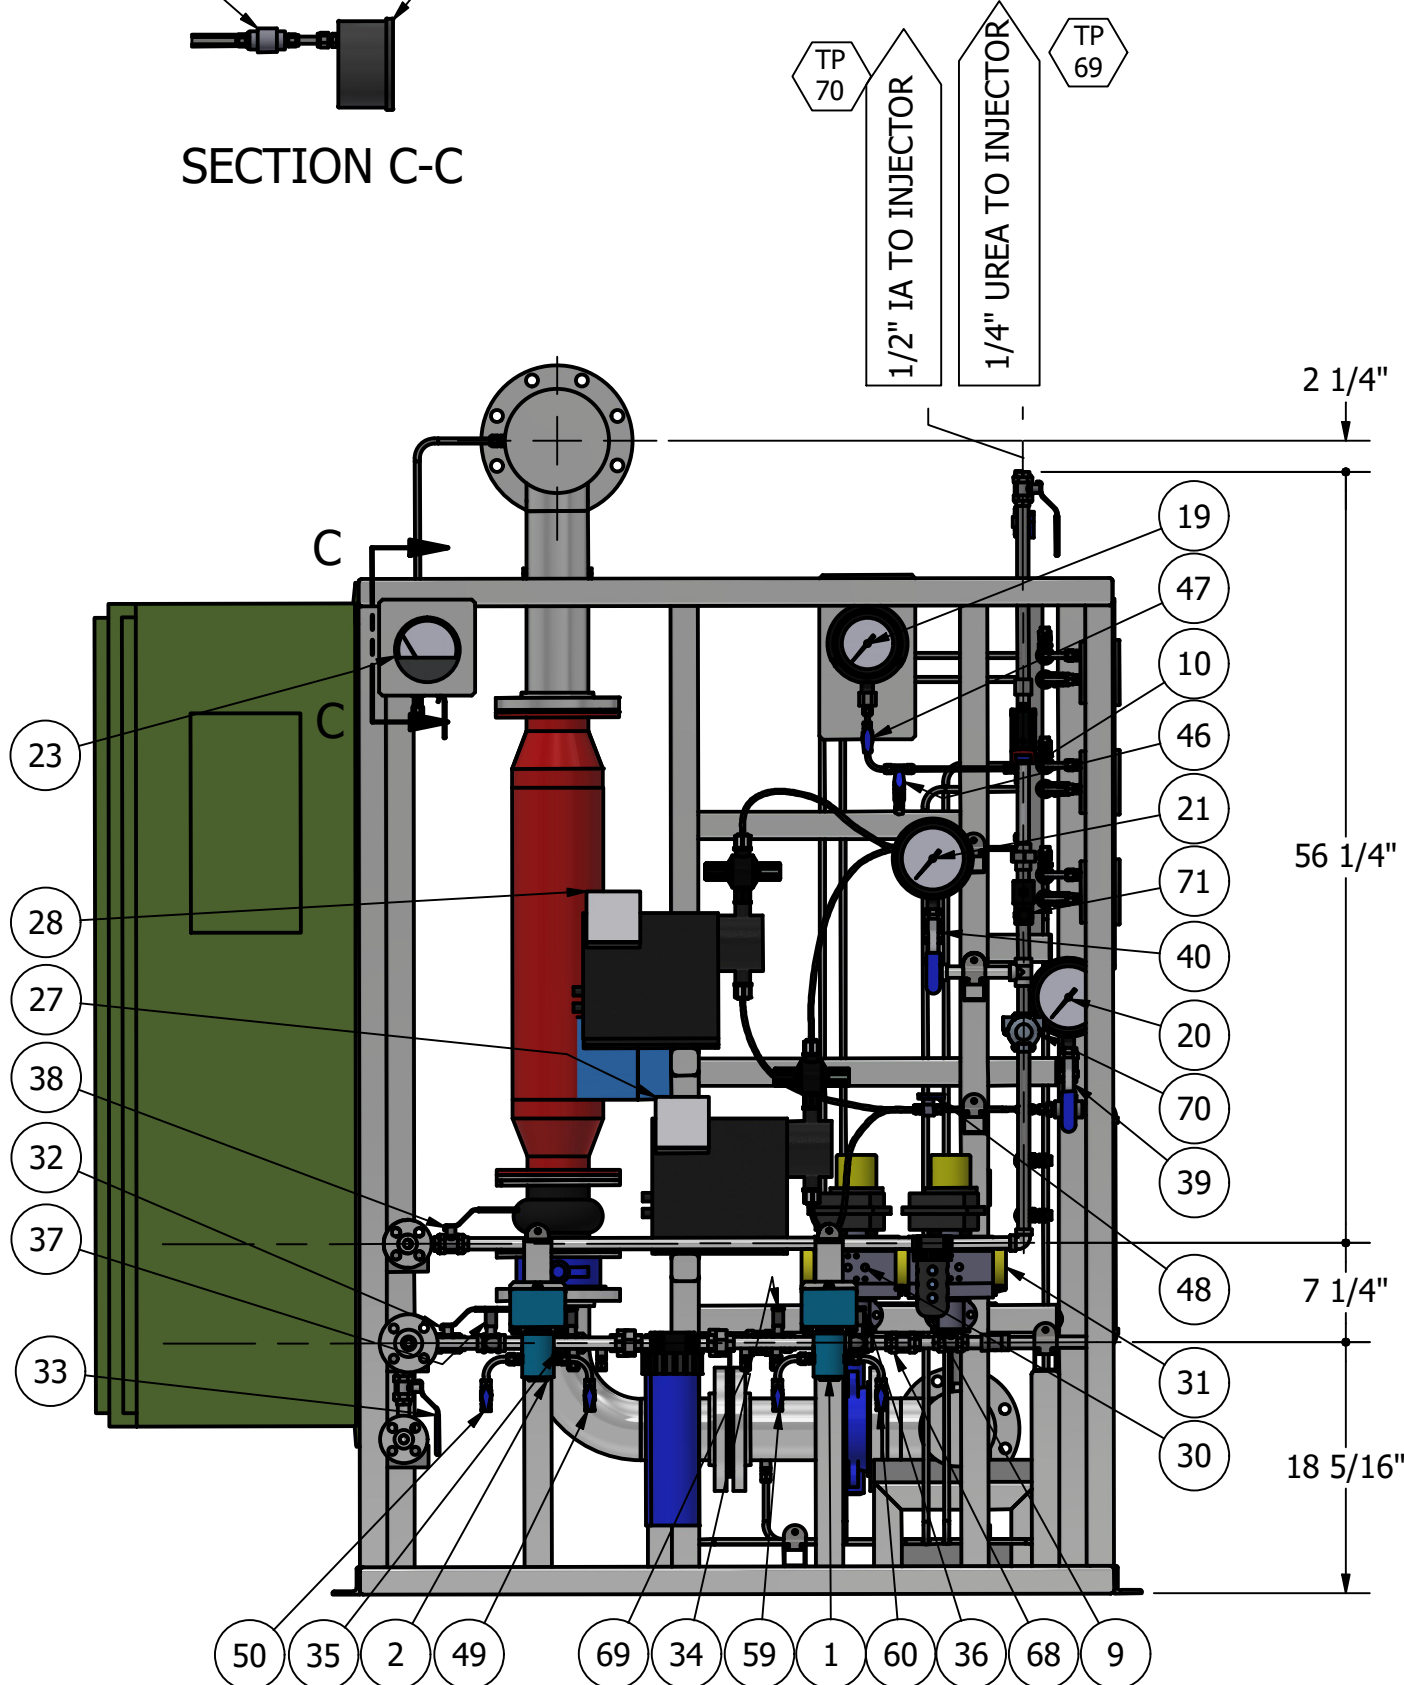

VIEW A-A
LEFT


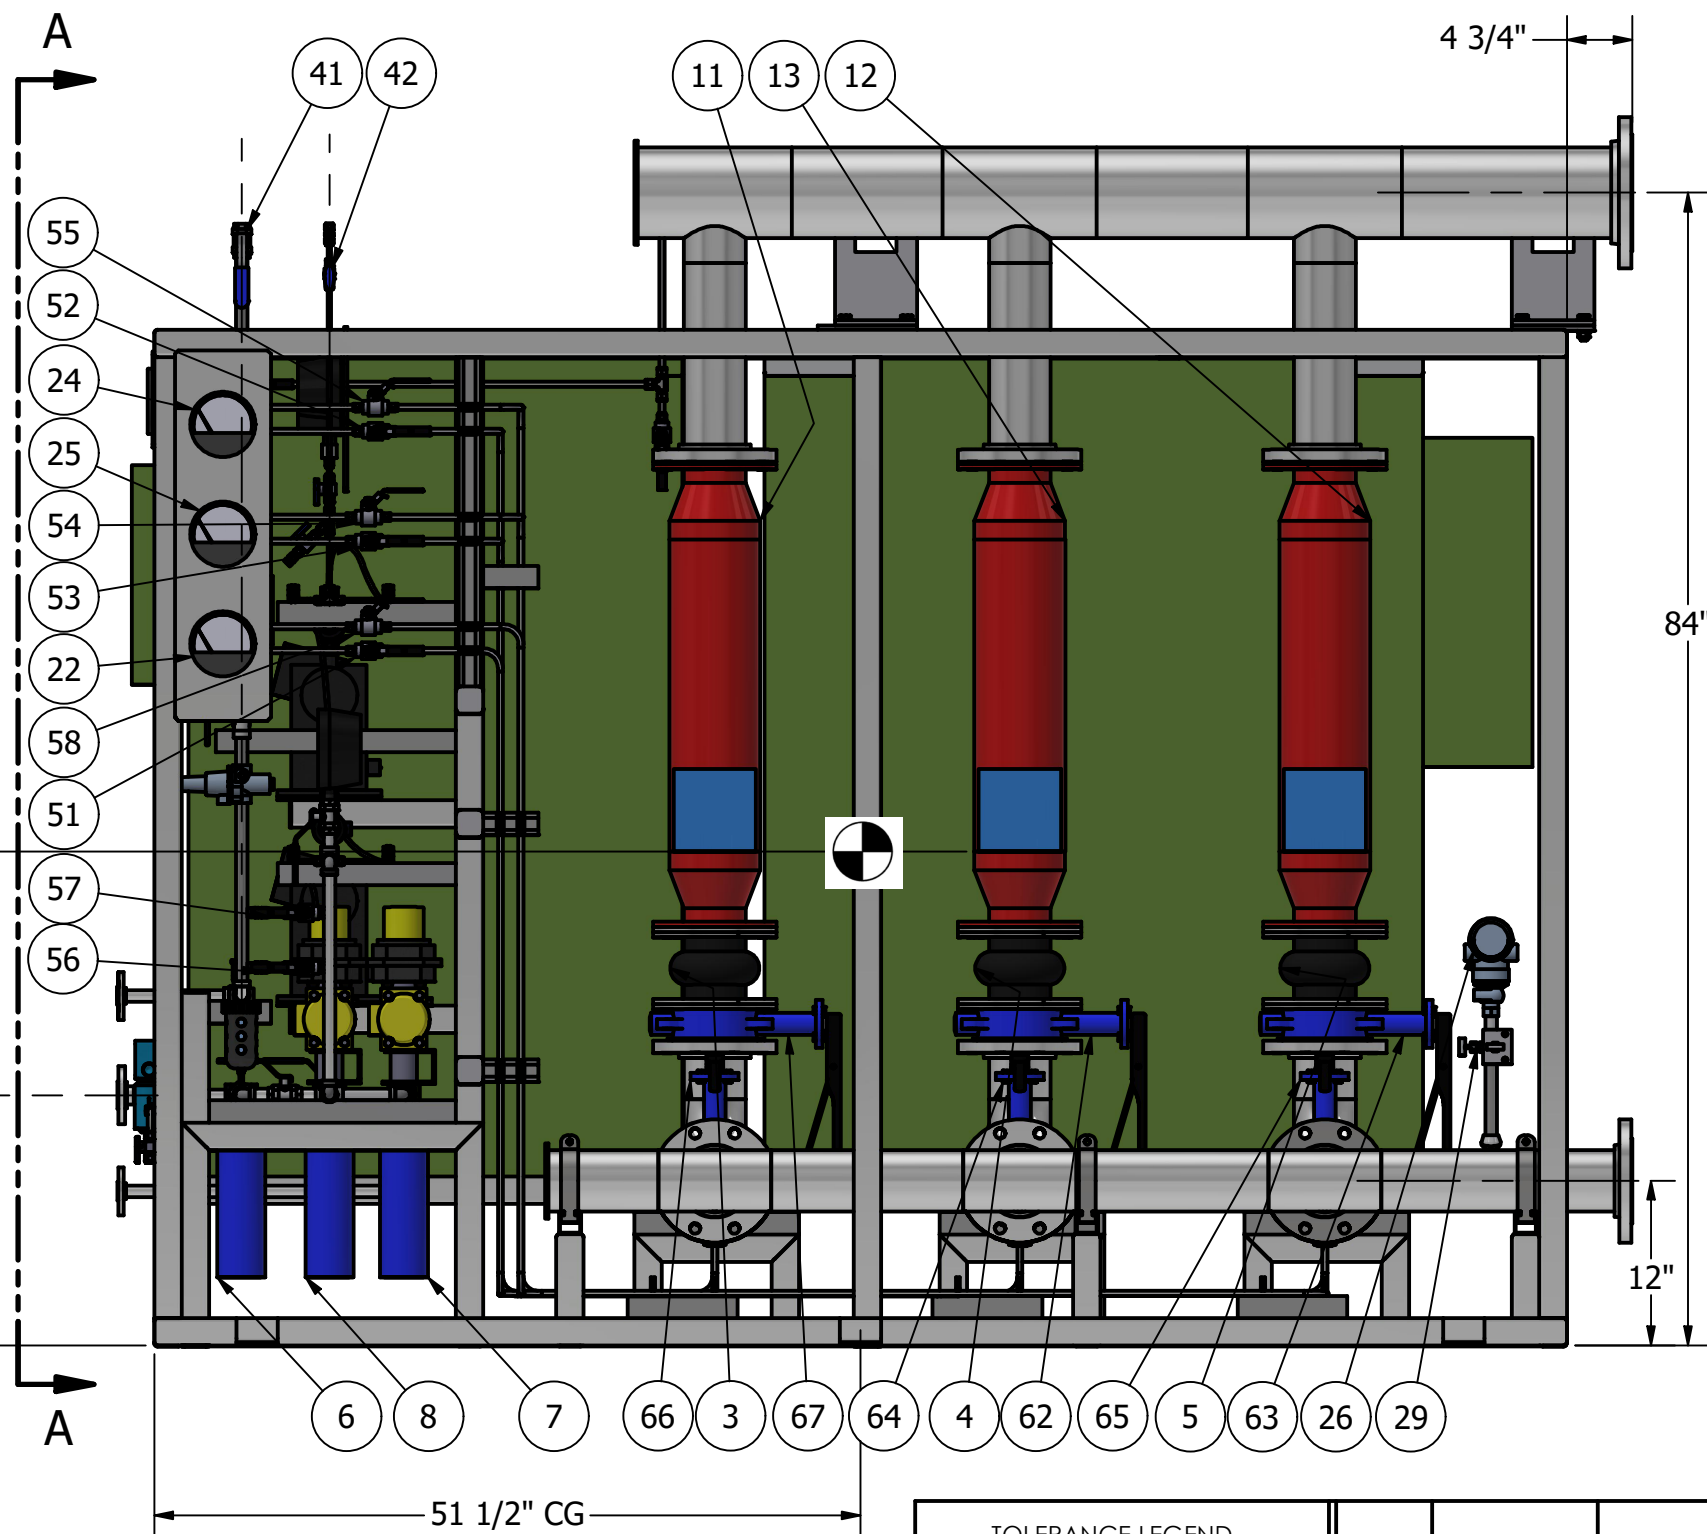
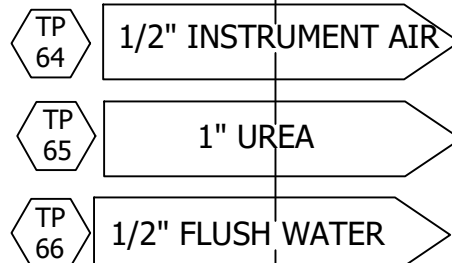


VIEW B-B
FRONT

NOTE: NO FORCES ARE ALLOWED ON TIE-IN FLANGES. CUSTOMER MUST PROVIDE ADEQUATE PIPE SUPPORTS AT ALL TIE-IN LOCATIONS PRIOR TO CONNECTING WITH FUEL TECH PIPING MODULES.

TOLERANCE LEGEND (UNLESS NOTED)					
.XX = ± .03"					
.XXX = ± .010"	3	1/12/23	ISSUE FOR FABRICATION	DG	AT
FRACTIONS = ± 1/8"	2	11/17/22	CLIENT COMMENTS/TIE POINTS	DG	AT
ANGLES = ± 3°	1	9/22/22	CLIENT COMMENTS/TIE POINTS	DG	AT
CUSTOMER TIE - INS = ± 1/4"	NO.	DATE	REVISIONS	DRAWN BY	CHECKED BY




 FUEL TECH, INC. 27401 BELLA VISTA PKWY, WARRENVILLE, IL 60555		APPROVED BY: K. KRAUSE	
		CHECKED BY: A. TOPACIO	
UC DAVIS MEDICAL CENTER		DRAWN BY: D. GHILARDI	
		DATE: 7/29/22	
ULTRA SYSTEM METERING AND HEATER MODULE		SCALE: NONE	SIZE: D
		DRAWING NO. 1294P-M03-01-GA-R3	

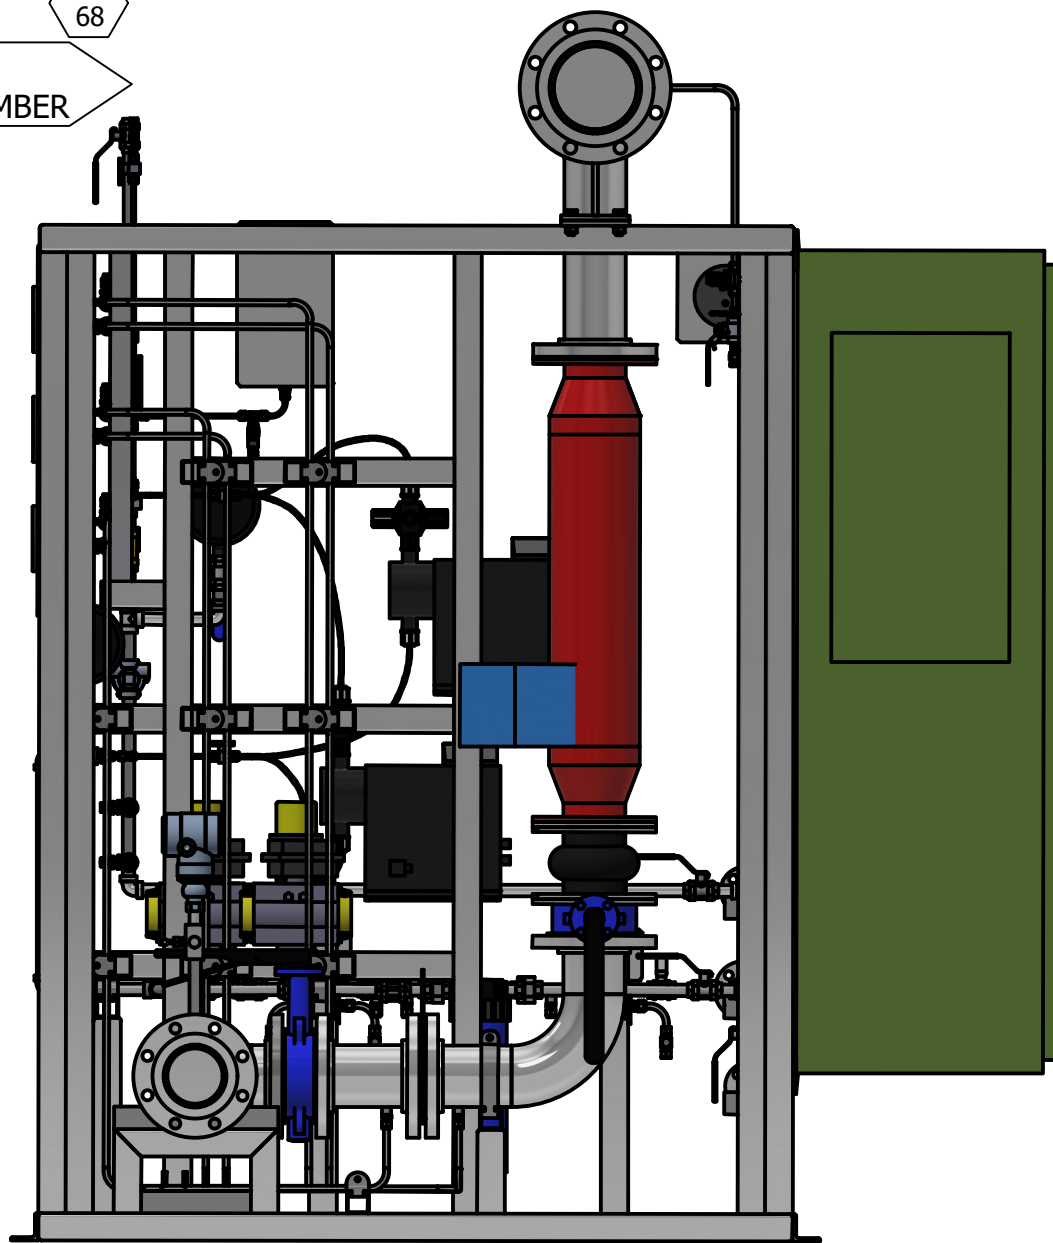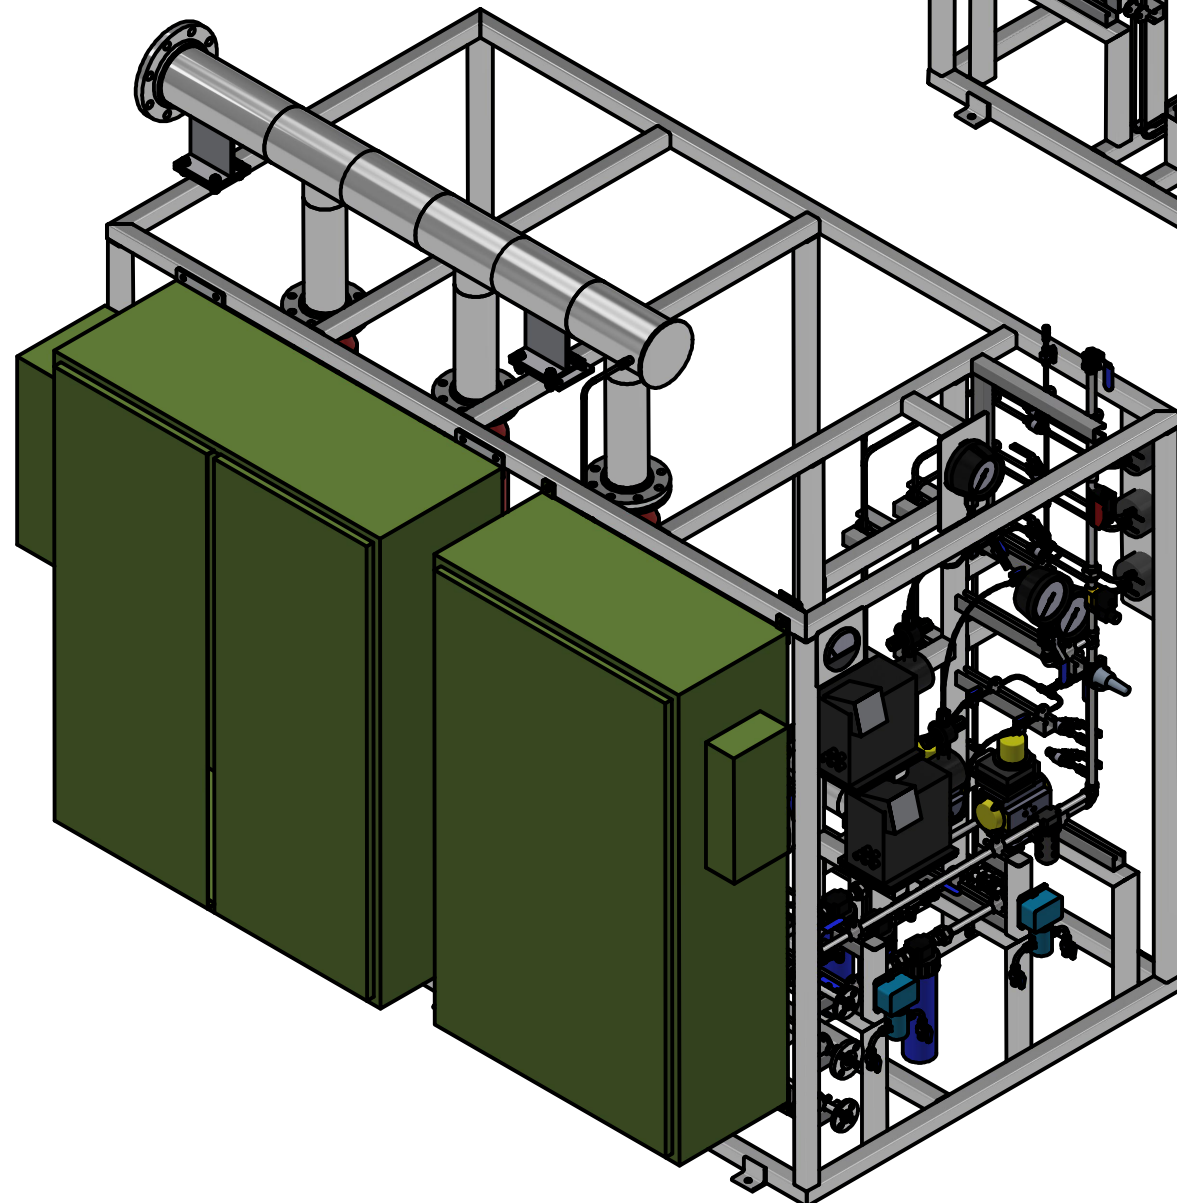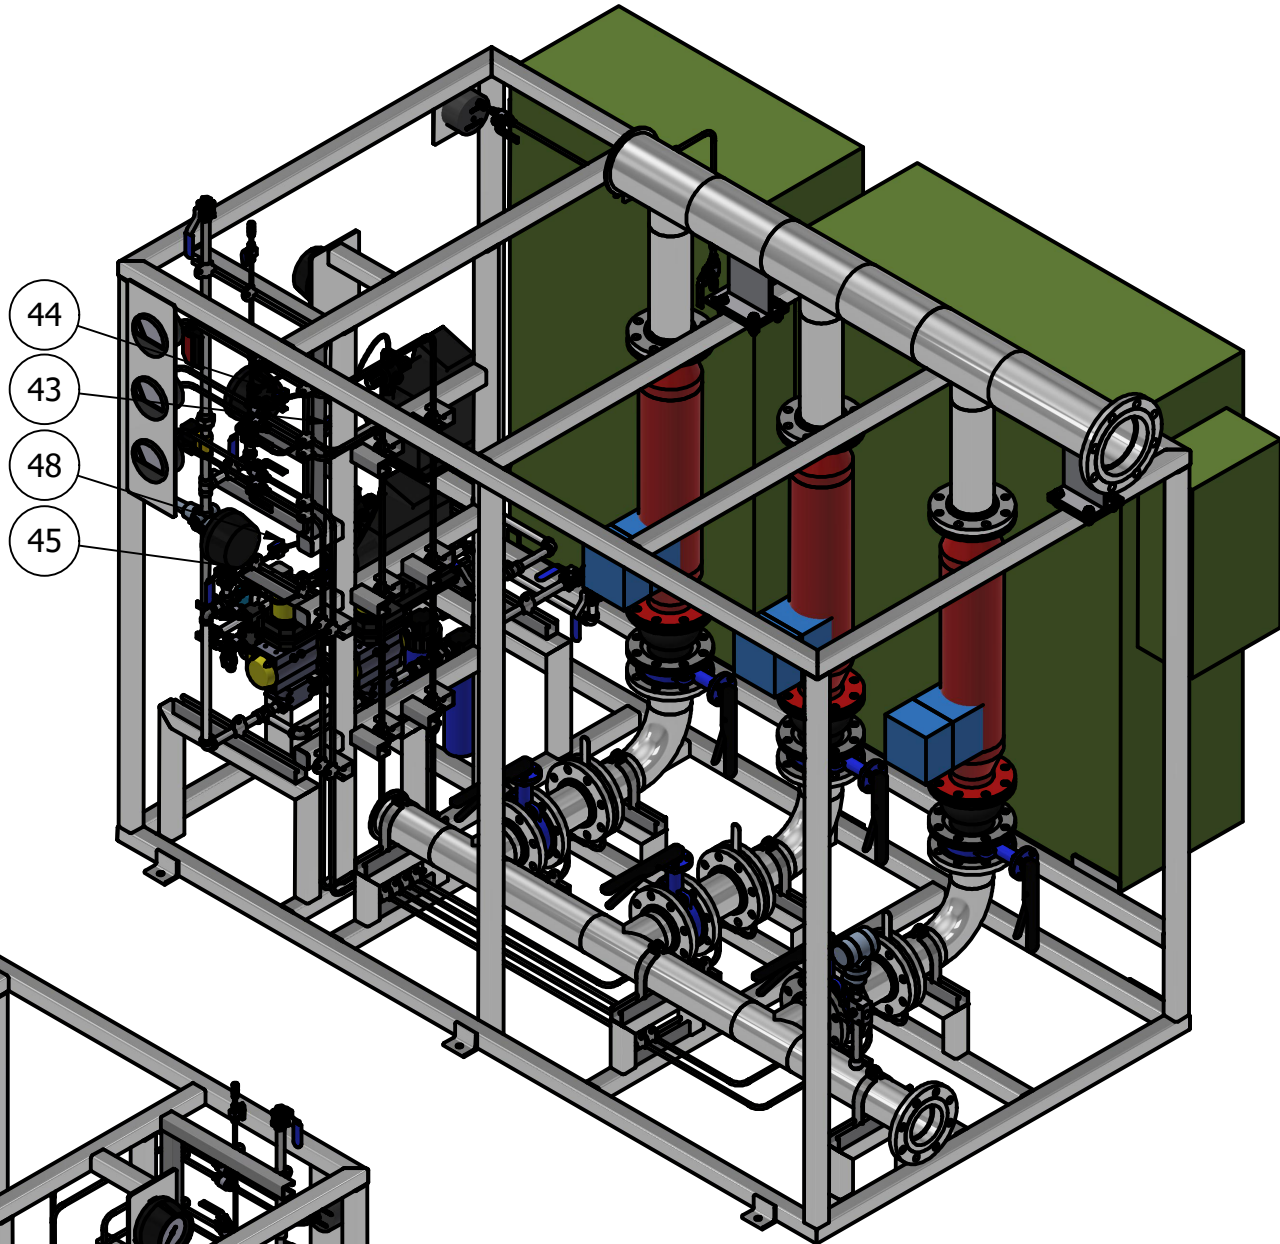



RIGHT

ESTIMATED WEIGHT IS 2,700#

PARTS LIST		
ITEM	TAG	DESCRIPTION
1	B-DA-2204A	BLOWER 4"
2	B-DA-2204B	BLOWER 4"
3		EXPANSION JOINT 4"
4		EXPANSION JOINT 4"
5	PI-DA-2203B	PRESSURE GAUGE 1/8" MAGNEHELIC
6	PI-DA-2203A	PRESSURE GAUGE 1/8" MAGNEHELIC
7	SIL-DA-2201B	SILENCER
8	SIL-DA-2201A	SILENCER
9		SUPPORT FRAME 1294P-M03-02-FRM
10	AOV-DA-2209A	VALVE AUTOMATIC ON/OFF 4"
11	AOV-DA-2209B	VALVE AUTOMATIC ON/OFF 4"
12	HV-DA-2202B	VALVE BALL 3/8" COMP
13	HV-DA-2202A	VALVE BALL 3/8" COMP

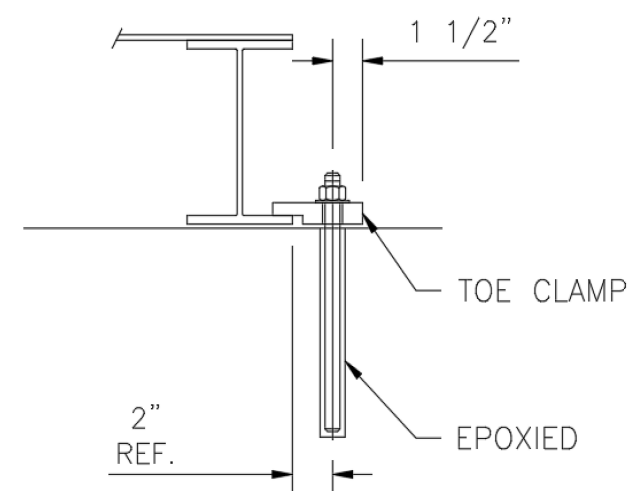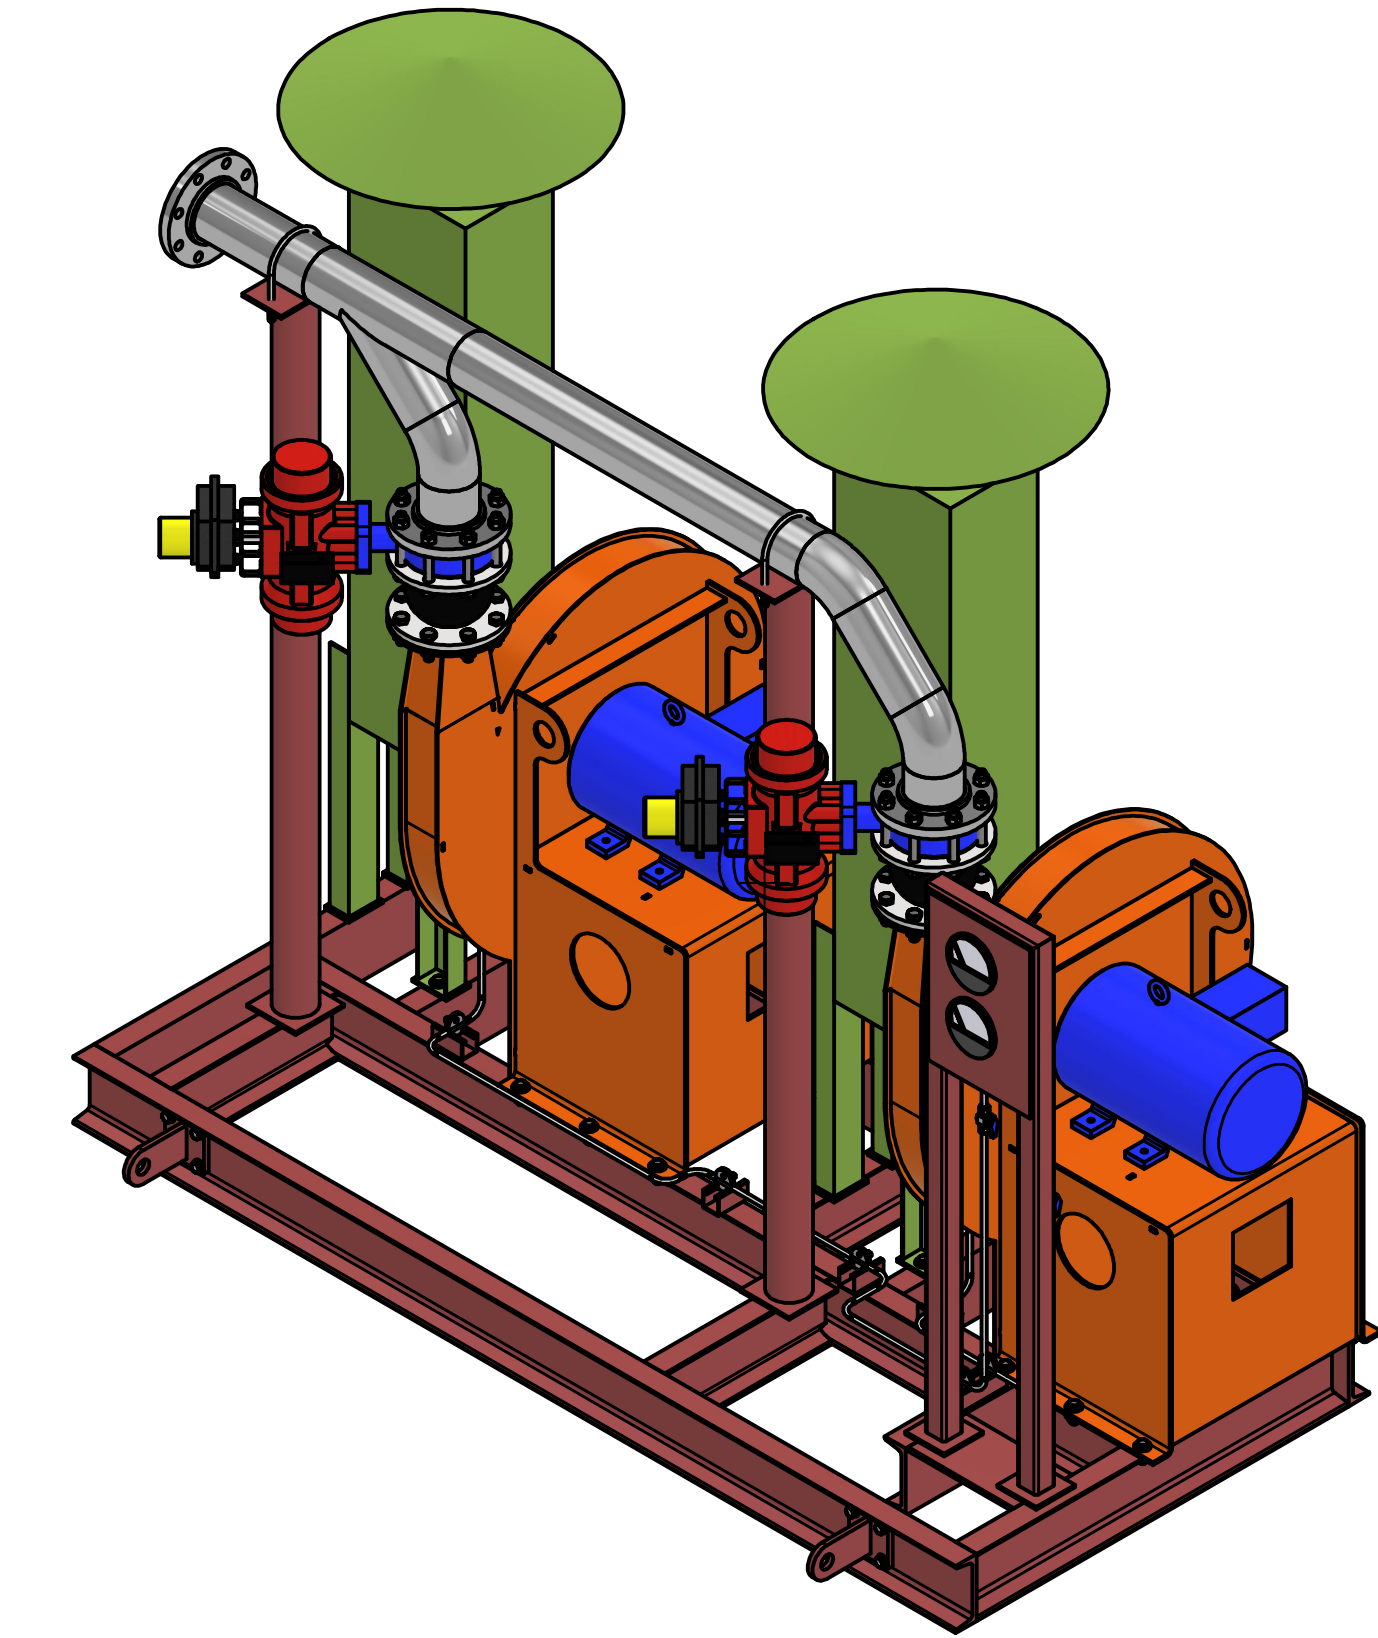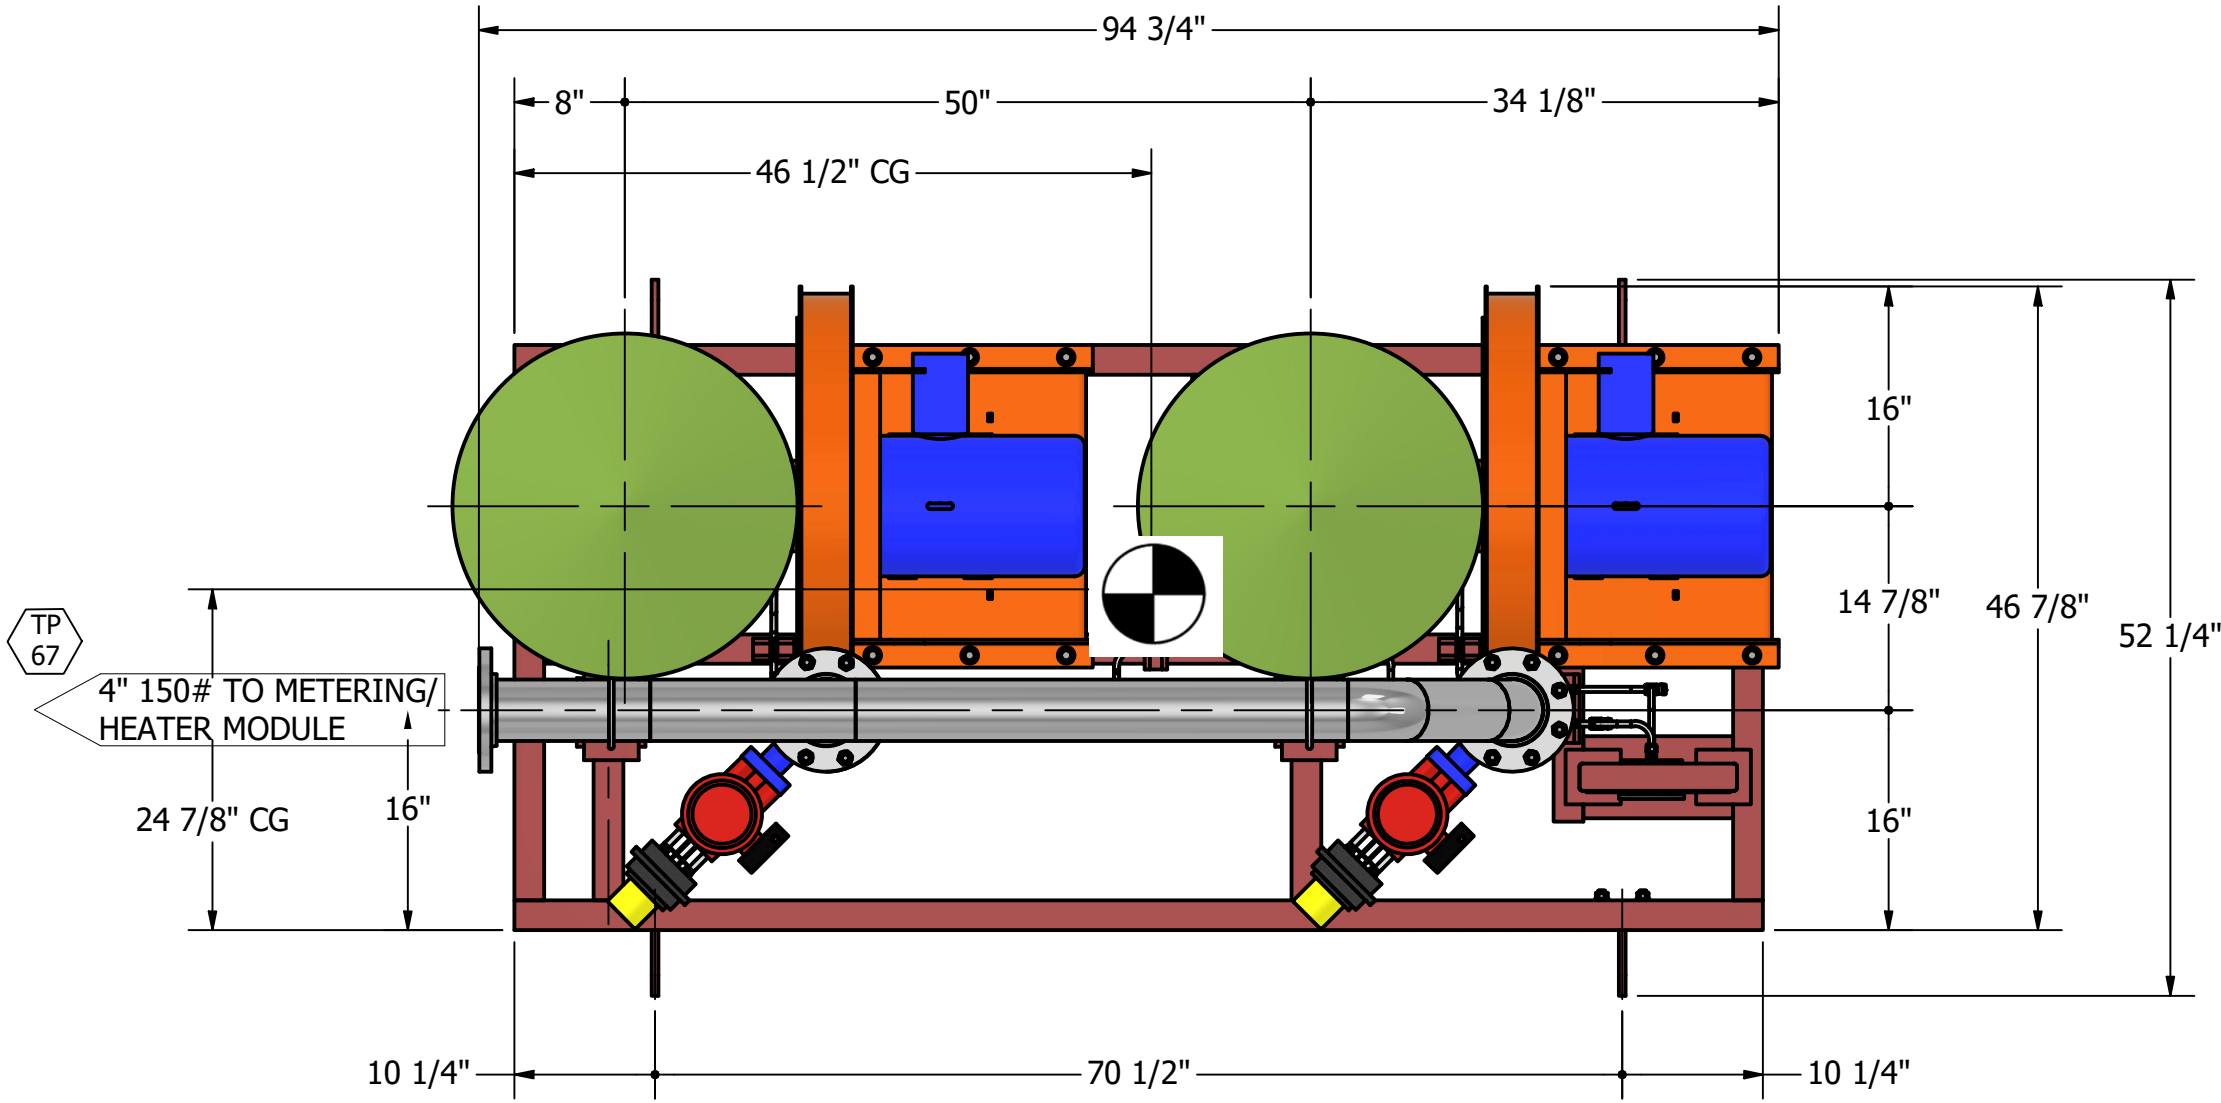


TYPICAL ANCHORAGE EXAMPLE

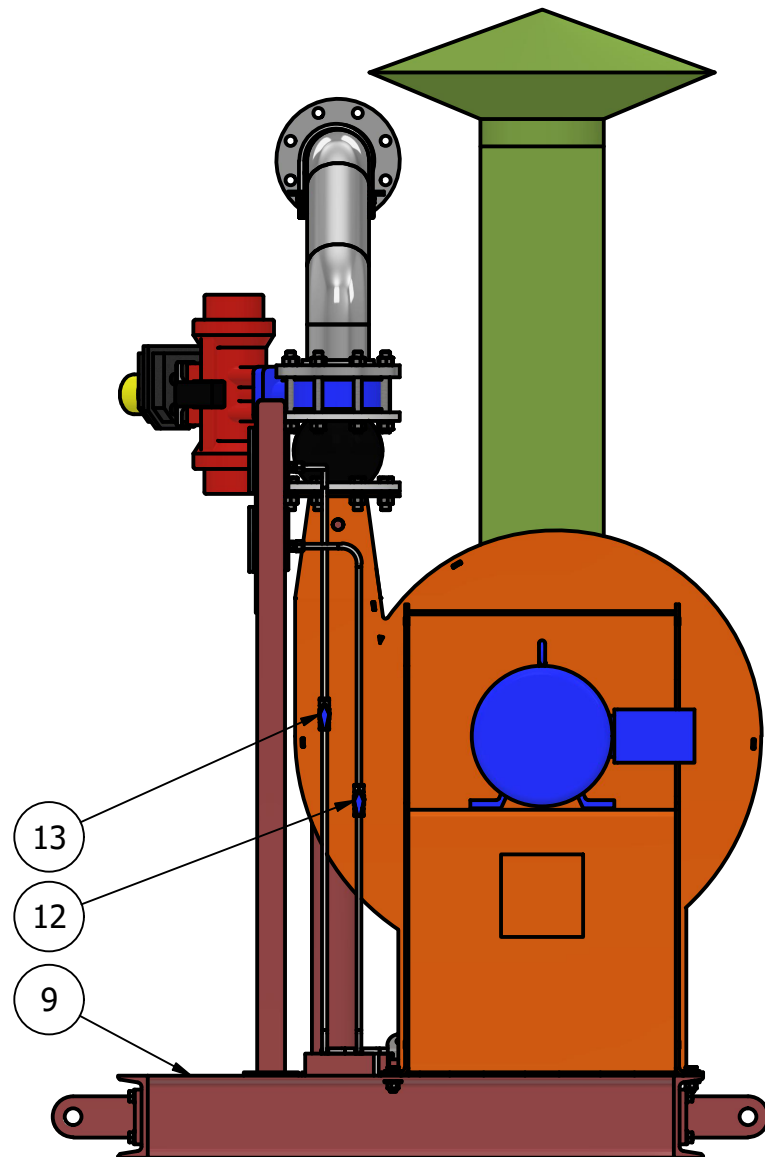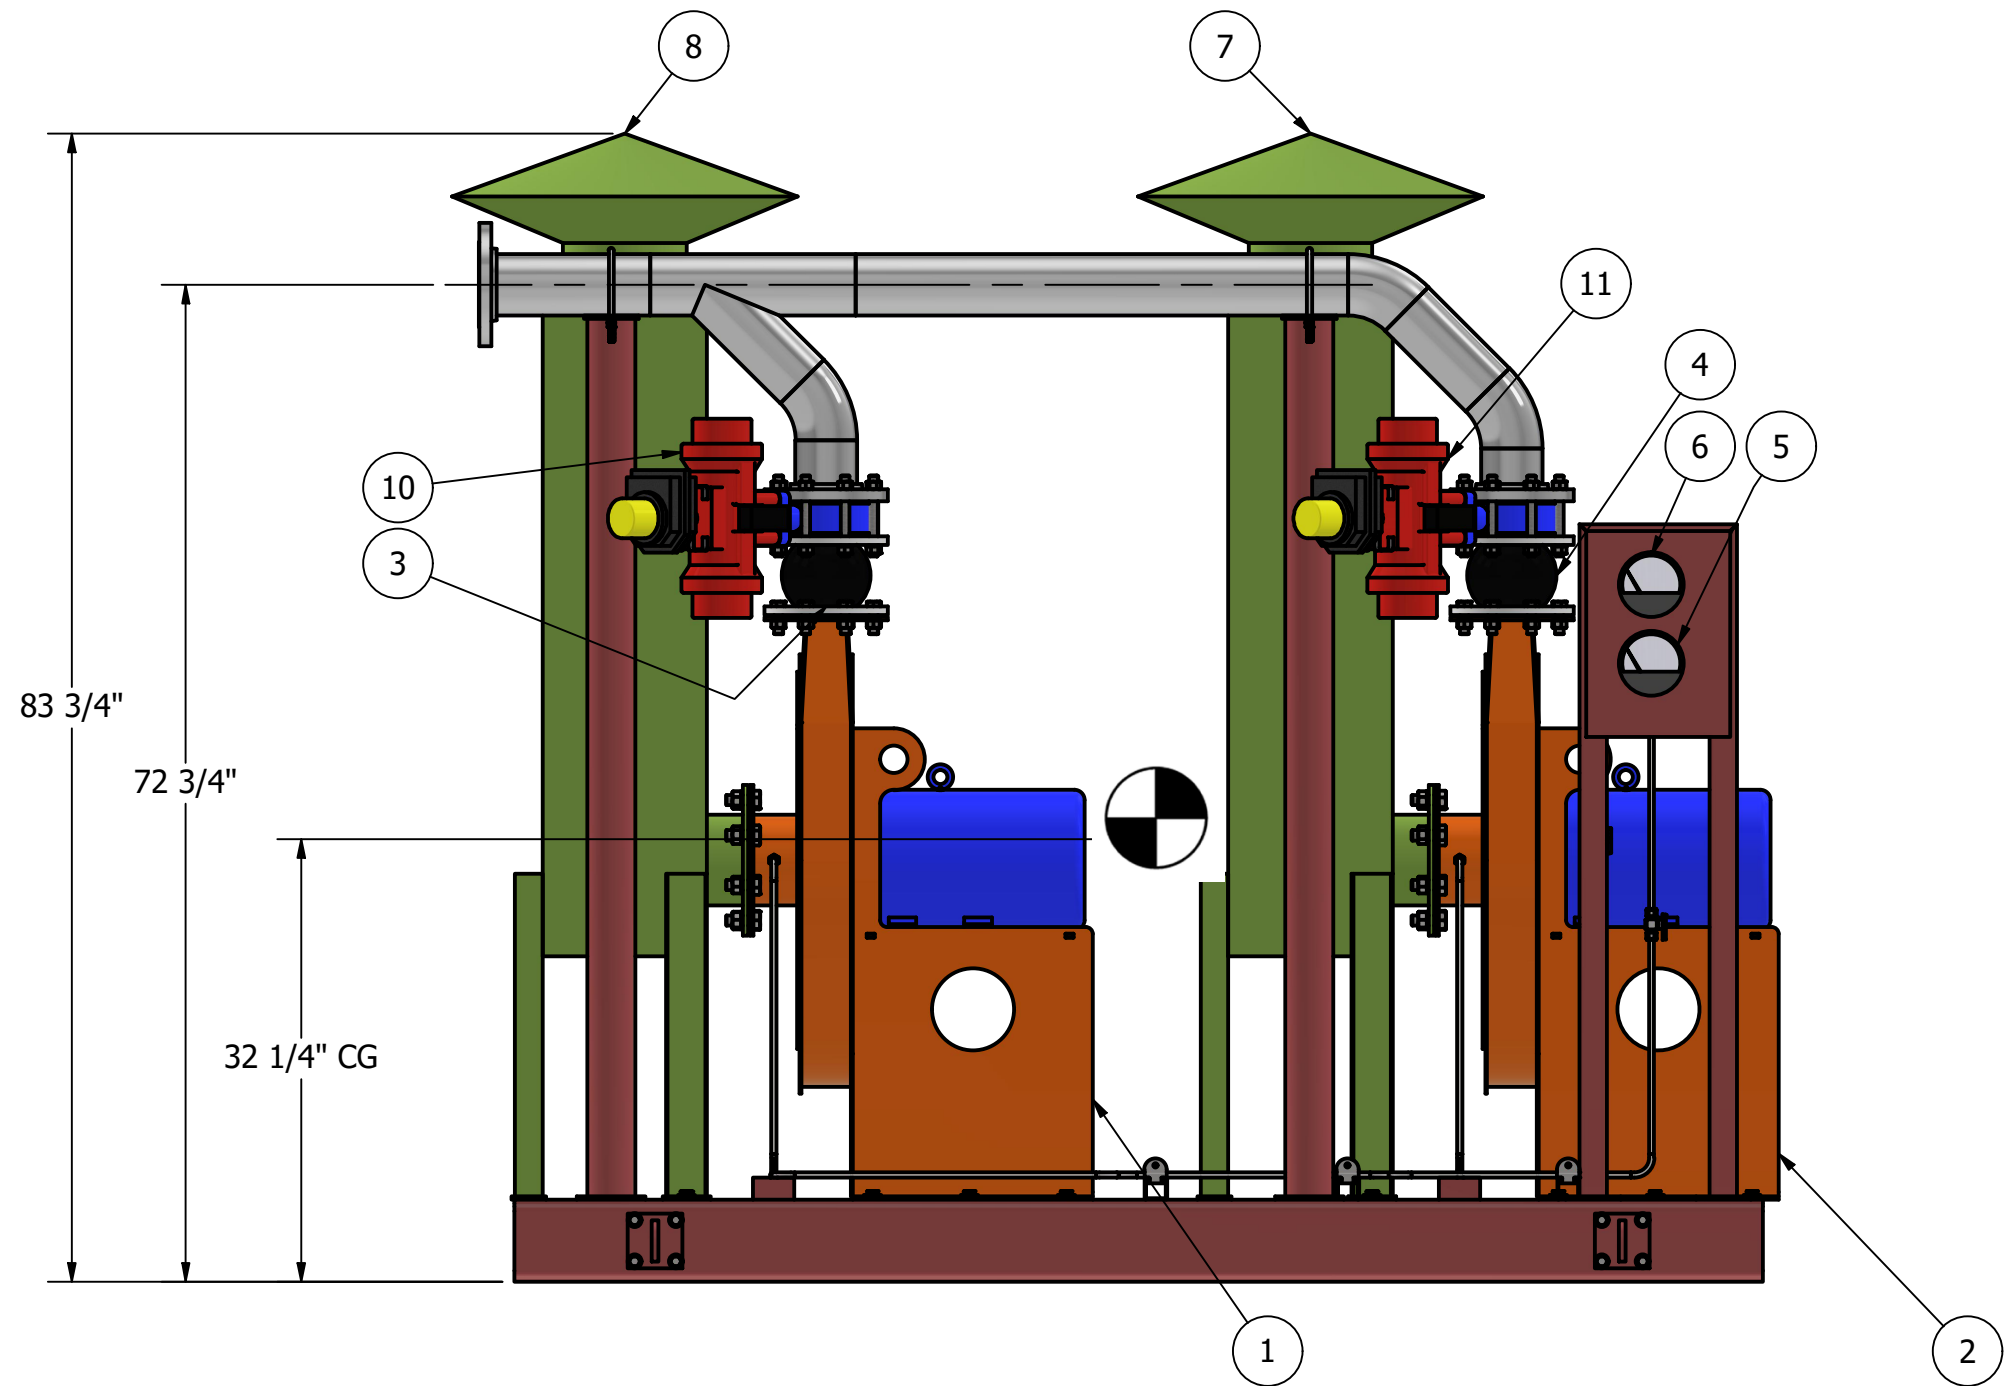

FULL ASSEMBLY WEIGHT IS 2,300 LBS
BLOWER W/MOTOR WEIGHT IS 428 LBS EACH
MOTOR WEIGHT IS 165 LBS EACH
SILENCER WEIGHT IS 175 LBS EACH
PRIME SUPPORT FRAME WITH ONE COAT
OF RUST INHIBITING PRIMER AND APPLY
ONE TOP COAT OF GRAY EXTERIOR ENAMEL.


DESIGNS REPRESENTED ON THIS DRAWING ARE THE PROPERTY OF FUEL TECH AND ARE CONFIDENTIAL. ALL RIGHTS RESERVED. ANY USE OTHER THAN THAT DESCRIBED IN THE CUSTOMER CONTRACT REQUIRES WRITTEN PERMISSION.

TOLERANCE LEGEND (UNLESS NOTED)						 FUEL TECH Technologies to enable clean efficient energy FUEL TECH, INC. 27601 BELLA VISTA PKWY, WARRENVILLE, IL 60555	APPROVED BY: K. KRAUSE	
.XX = ± .03"							CHECKED BY: A. TOPACIO	
.XXX = ± .010"	3	1/19/23	ISSUE FOR FABRICATION	DG	AT		DRAWN BY: D. GHILARDI	
FRACTIONS = ± 1/8"	2	10/10/22	ADDED CENTER OF GRAVITY	DG	AT		DATE: 8/12/22	
ANGLES = ± 3°	1	9/26/22	CLIENT COMMENTS	DG	AT		SCALE: NONE	SIZE: D
CUSTOMER TIE - INS = ± 1/4"	NO.	DATE	REVISIONS	DRAWN BY	CHECKED BY	UC DAVIS MEDICAL CENTER	DRAWING NO. 1294P-M03-02-GA-R3	
						ULTRA SYSTEM BLOWER MODULE		

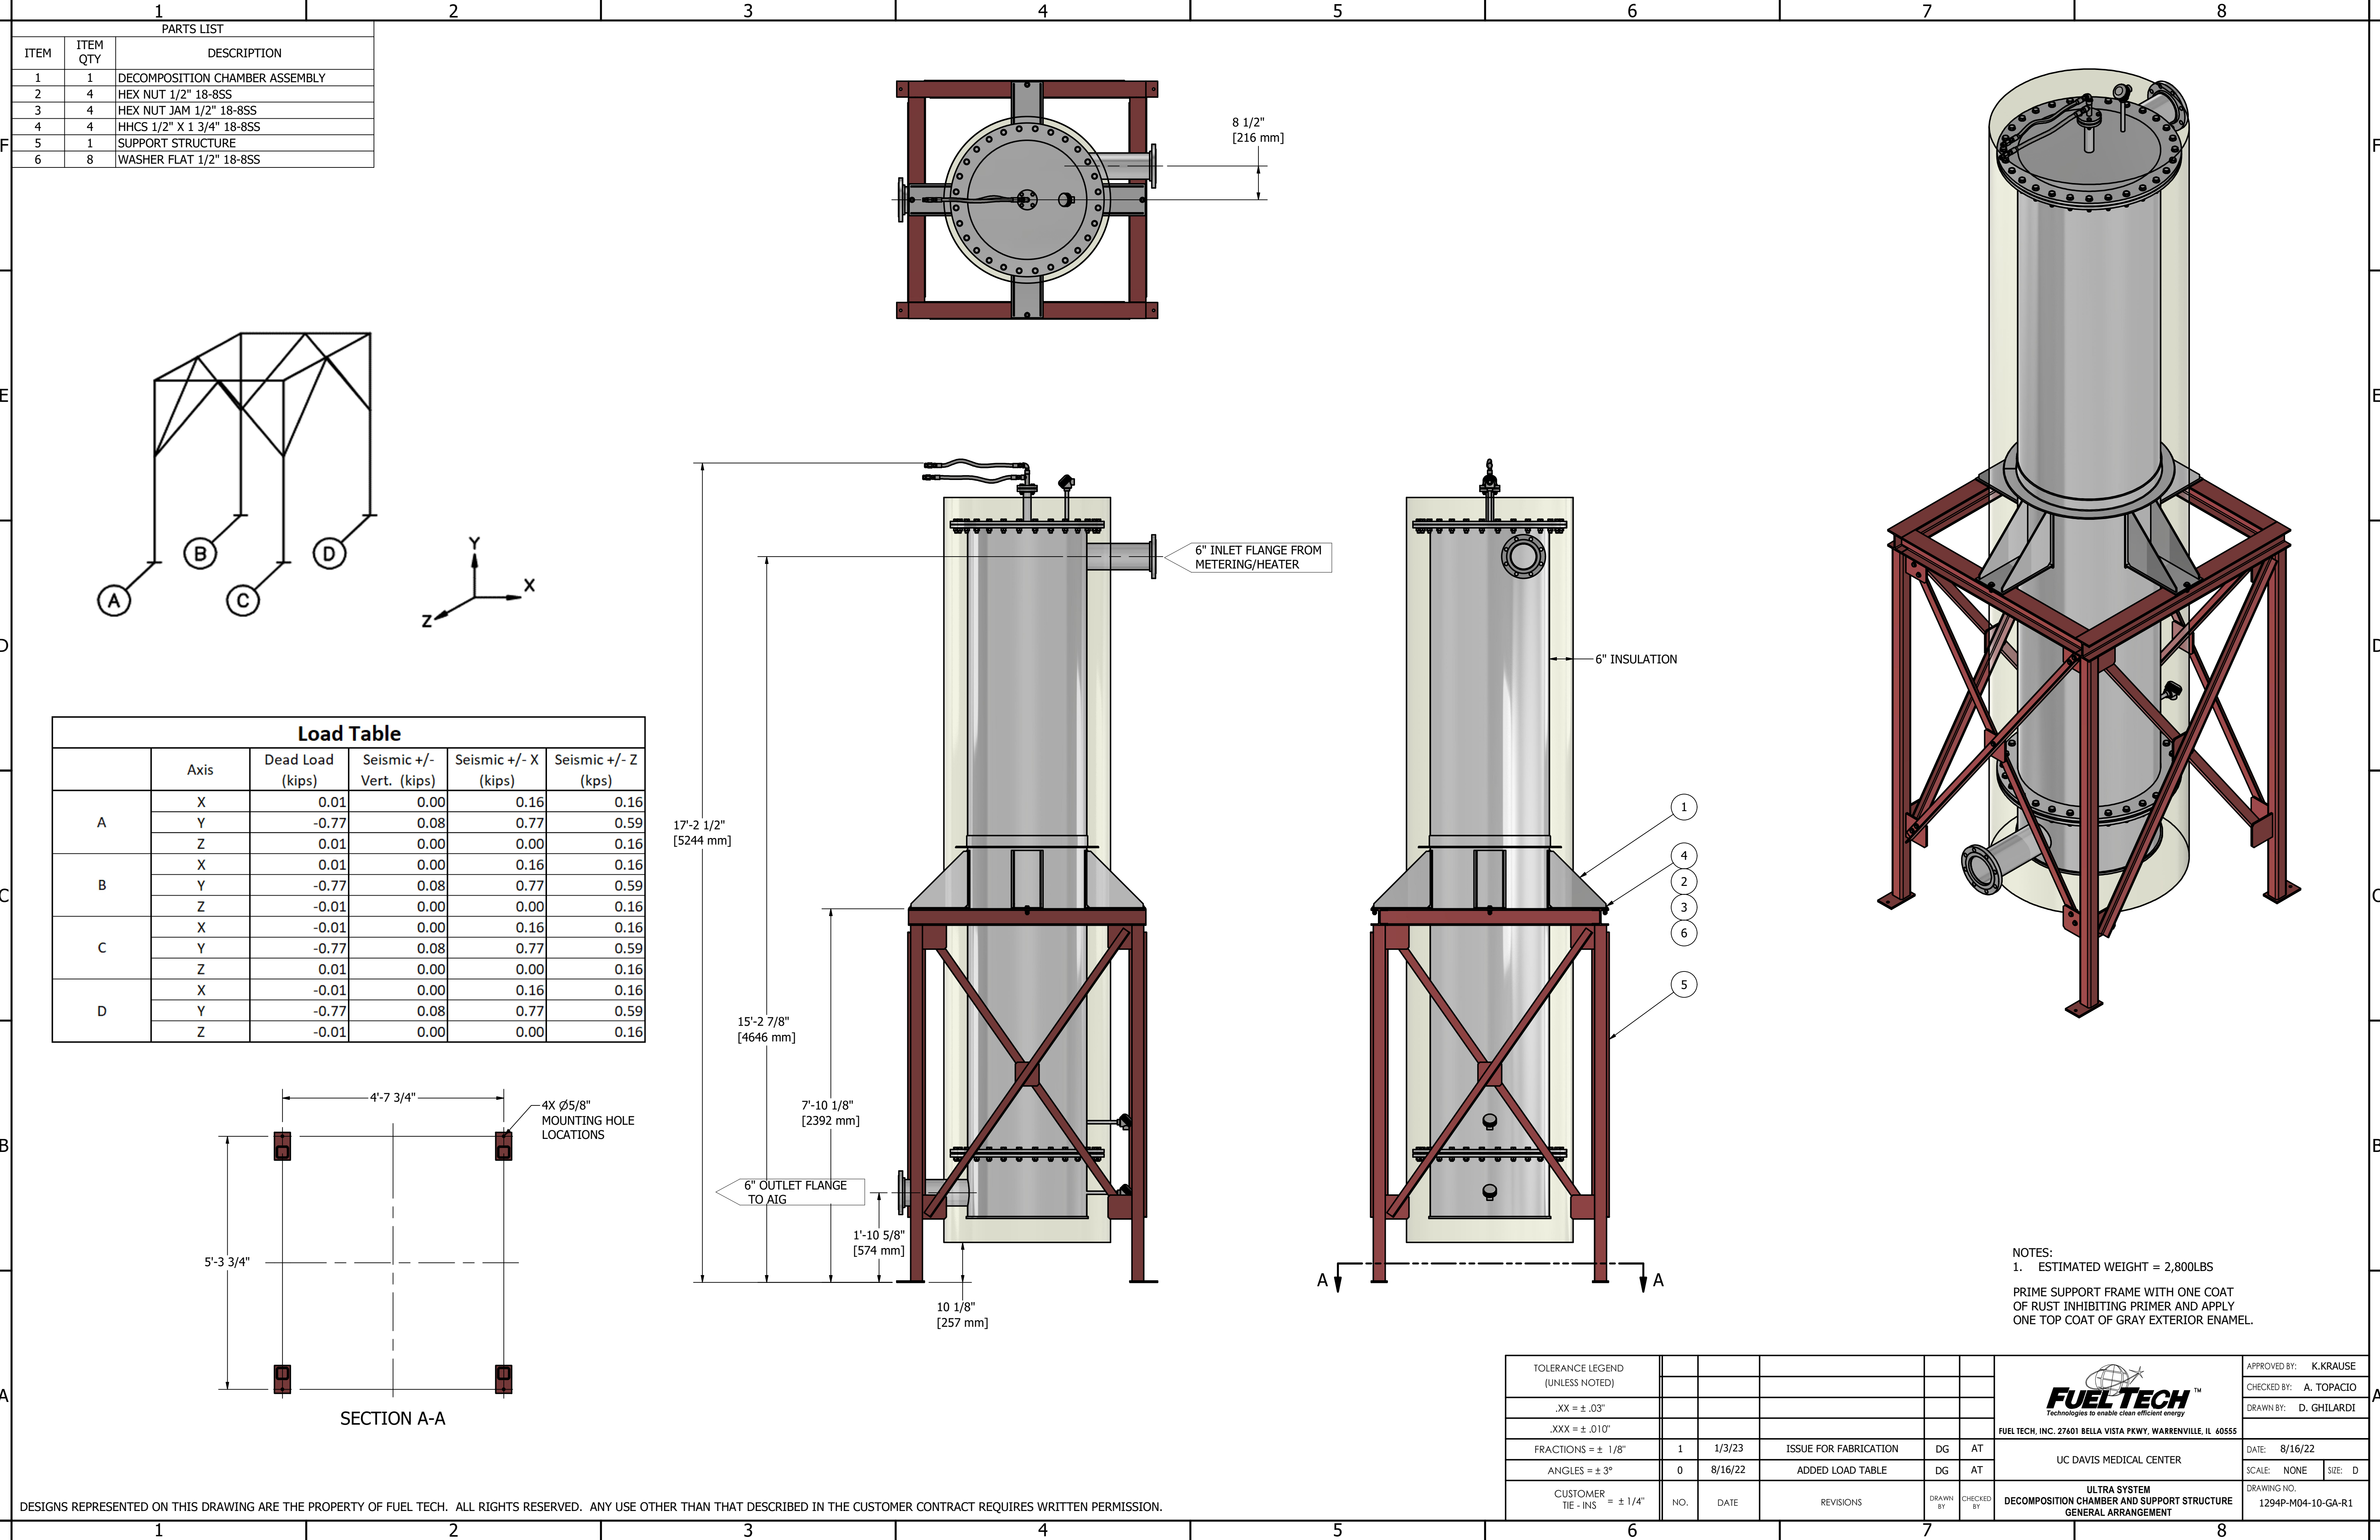

PARTS LIST		
ITEM	ITEM QTY	DESCRIPTION
1	1	DECOMPOSITION CHAMBER ASSEMBLY
2	4	HEX NUT 1/2" 18-8SS
3	4	HEX NUT JAM 1/2" 18-8SS
4	4	HHCS 1/2" X 1 3/4" 18-8SS
5	1	SUPPORT STRUCTURE
6	8	WASHER FLAT 1/2" 18-8SS

Load Table					
	Axis	Dead Load (kips)	Seismic +/- Vert. (kips)	Seismic +/- X (kips)	Seismic +/- Z (kps)
A	X	0.01	0.00	0.16	0.16
	Y	-0.77	0.08	0.77	0.59
	Z	0.01	0.00	0.00	0.16
B	X	0.01	0.00	0.16	0.16
	Y	-0.77	0.08	0.77	0.59
	Z	-0.01	0.00	0.00	0.16
C	X	-0.01	0.00	0.16	0.16
	Y	-0.77	0.08	0.77	0.59
	Z	0.01	0.00	0.00	0.16
D	X	-0.01	0.00	0.16	0.16
	Y	-0.77	0.08	0.77	0.59
	Z	-0.01	0.00	0.00	0.16

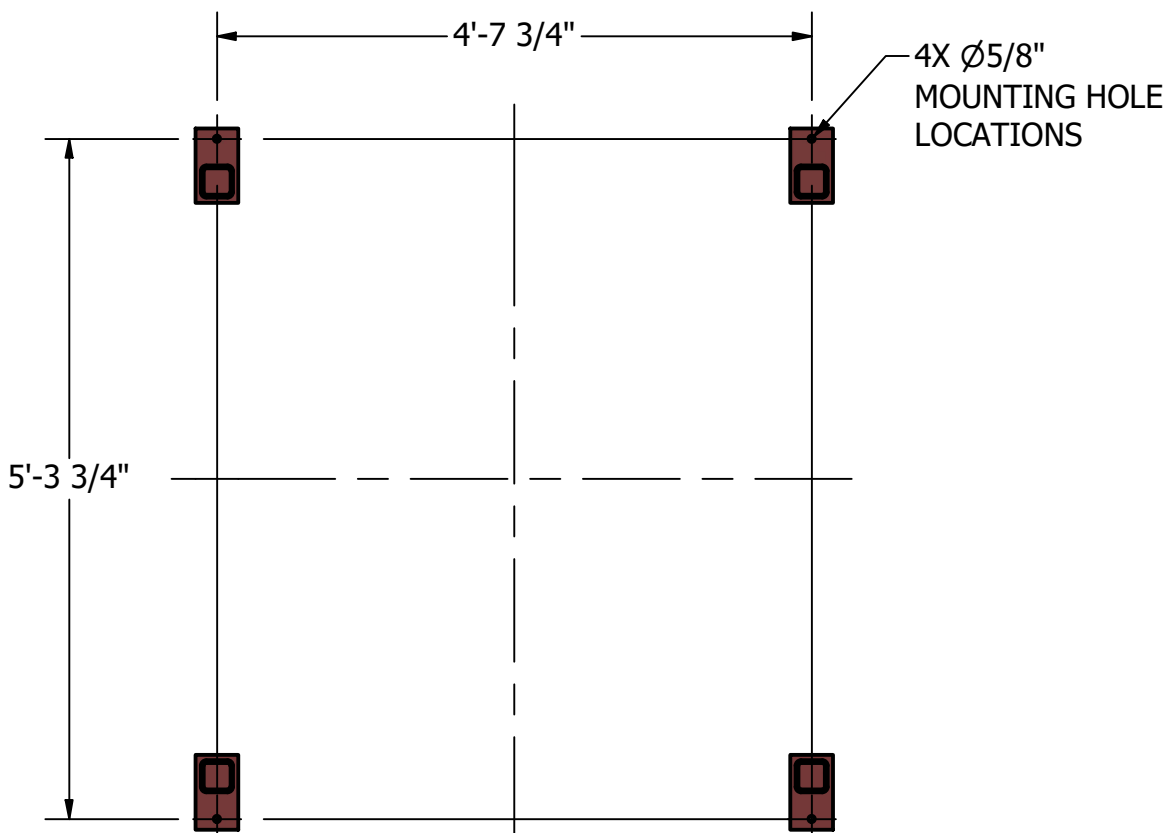

DESIGNS REPRESENTED ON THIS DRAWING ARE THE PROPERTY OF FUEL TECH. ALL RIGHTS RESERVED. ANY USE OTHER THAN THAT DESCRIBED IN THE CUSTOMER CONTRACT REQUIRES WRITTEN PERMISSION.

TOLERANCE LEGEND (UNLESS NOTED)						 FUEL TECH, INC. 27601 BELLA VISTA PKWY, WARRENVILLE, IL 60555	APPROVED BY: K.KRAUSE	
.XX = ± .03"							CHECKED BY: A. TOPACIO	
.XXX = ± .010"							DRAWN BY: D. GHILARDI	
FRACTIONS = ± 1/8"	1	1/3/23	ISSUE FOR FABRICATION	DG	AT	UC DAVIS MEDICAL CENTER	DATE: 8/16/22	
ANGLES = ± 3°	0	8/16/22	ADDED LOAD TABLE	DG	AT		SCALE: NONE SIZE: D	
CUSTOMER TIE - INS = ± 1/4"	NO.	DATE	REVISIONS	DRAWN BY	CHECKED BY	ULTRA SYSTEM DECOMPOSITION CHAMBER AND SUPPORT STRUCTURE GENERAL ARRANGEMENT	DRAWING NO. 1294P-M04-10-GA-R1	